

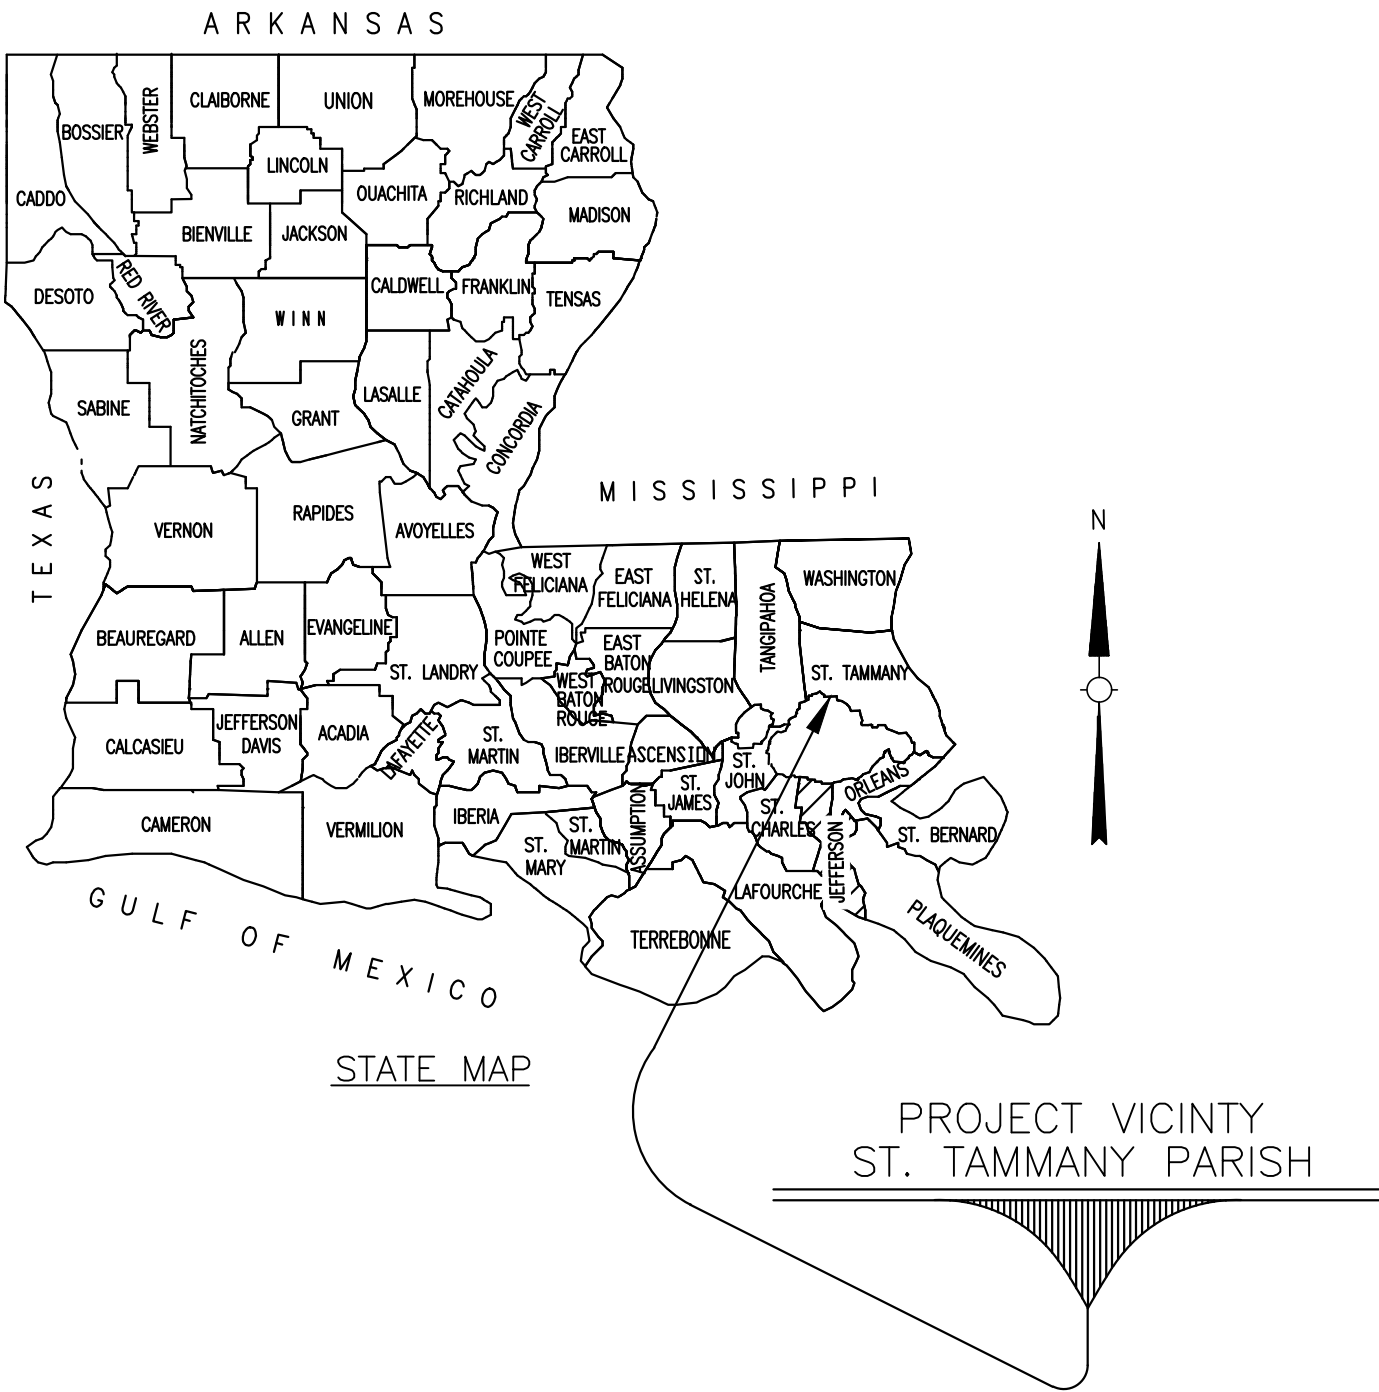
INDEX TO SHEETS

| SHEET NO. | DESCRIPTION                                                |
|-----------|------------------------------------------------------------|
| 1         | TITLE SHEET AND LAYOUT MAP                                 |
| 2         | GENERAL NOTES                                              |
| 3-7       | PLAN SHEETS                                                |
| 8-9       | REPAIR DETAILS TYPE A (SPLASH BLOCK)                       |
| 10-11     | REPAIR DETAILS TYPE B (CONCRETE BULKHEAD)                  |
| 12        | REPAIR DETAILS TYPE C (STEP REPAIRS)                       |
| 13        | REPAIR DETAILS TYPE D (SHEET PILE AT BULKHEAD EXP. JOINTS) |
| 14        | REPAIR DETAILS TYPE E (SHEET PILE SECTION LOSS)            |
| 15        | REPAIR DETAILS TYPE F (SHEET PILE JOINT REPAIR)            |
| 16        | CATHODIC PROTECTION - GENERAL NOTES & B.O.M.               |
| 17        | CATHODIC PROTECTION - LAYOUT AND DETAILS                   |
| 18        | CATHODIC PROTECTION - DETAILS                              |

| AS-BUILTS                         | REV. DATE |
|-----------------------------------|-----------|
| REPLACEMENT OF MANDEVILLE SEAWALL | 4-5-94    |



MANDEVILLE SEAWALL REPAIRS PROJECT  
SEGMENT 1  
THE CITY OF MANDEVILLE, LOUISIANA  
COM PROJ. NO. 100.21.019  
January 2025



TOTAL SHEETS = 44

BEGIN PROJECT  
APPROX.  
STA. 41+44.67



END PROJECT  
STA. 83+25.09

CITY OF MANDEVILLE

MAYOR  
CLAY MADDEN

 
CITY COUNCIL MEMBERS

RICK DANIELSON  
JASON ZUCKERMAN  
REBECCA BUSH  
DR. J. SKELLY KRELLER  
JILL MCGUIRE

TYPE OF CONSTRUCTION

REHABILITATION OF STEEL SHEET PILE SEAWALL  
AND STAIRS, REPLACEMENT OF CONCRETE CAP  
AND SPLASH BLOCKS, AND INSTALLATION OF  
CATHODIC PROTECTION.

LAYOUT MAP



PLANS PREPARED BY:



PLANS PREPARED AND RECOMMENDED FOR APPROVAL BY:

BURK-KLEINPETER, INC.

DATE: 1-8-2025

APPROVED BY:

KEITH LAGRANGE  
PUBLIC WORKS DIRECTOR, MANDEVILLE

DATE: 1-09-2025



1/7/2025

P:\NO.24.XXX\NO.24-007 OLD MANDEVILLE SEAWALL REPAIR SEGMENT 102\_DESIGN\02 CIVIL\01 DRAWING\02\_GENERAL NOTES\_01

GENERAL NOTES:

1.

CONTRACTOR SHALL COMPLETE A FIELD SURVEY PRIOR TO CONSTRUCTION TO ESTABLISH EXISTING SEAWALL CAP ELEVATIONS. FINAL CONSTRUCTION SHALL MATCH ALL EXISTING ELEVATIONS.
2.

DIMENSIONS AND/OR ELEVATIONS MARKED (N.T.S.) ARE NOT SHOWN TO SCALE.
3.

DRAWINGS ARE GENERALLY TO SCALE, BUT SHOULD NOT BE SCALED. N.T.S. IS SHOWN ONLY WHERE DRAWING IS OBVIOUSLY OUT OF SCALE.
4.

ALL STATIONING SHOWN IS APPROXIMATE BASED ON THE AS-BUILT PLANS. TRUE LOCATIONS SHALL BE VERIFIED BY THE CONTRACTOR IN THE FIELD. ALL STATIONING IS MEASURED ALONG THE WALL LINE ALONG THE LAKE SIDE FACE OF THE CAP AS SHOWN IN THE AS-BUILT PLANS.
5.

DIMENSIONS AND/OR ELEVATIONS MARKED (±) ARE APPROXIMATE. CONTRACTOR SHALL VERIFY ACTUAL DIMENSIONS IN THE FIELD.
6.

ALL ELEVATIONS SHOWN ARE IN FEET AND REFER TO N.G.V.D. (1969 EPOCH). CONTRACTOR SHALL PROVIDE A DATUM FROM N.G.V.D. TO NAVD88 GEOID 12B AND GEOID 18 DATUMS.
7.

ALL REPAIRS LISTED IN THE PLANS WERE DETERMINED FROM AN IN DEPTH INSPECTION. ALL REASONABLE EFFORTS WERE MADE TO PROVIDE THE CONTRACTOR WITH ACCURATE QUANTITIES AND LOCATIONS FOR REPAIRS. IF THE CONTRACTOR DISCOVERS ADDITIONAL DEFECTS WHICH REQUIRE REPAIR, HE SHALL BRING THOSE DEFECTS TO THE ATTENTION OF THE ENGINEER WHEN DISCOVERED. THE ENGINEER WILL ASSESS EACH LOCATION ON A CASE BY CASE BASIS AND WILL HAVE THE FINAL DECISION WHETHER AN ADDITIONAL REPAIR WILL BE REQUIRED. PAYMENT FOR ADDITIONAL REPAIRS WILL BE MADE UNDER THE ASSOCIATED PAY ITEM. INDIRECT COSTS ASSOCIATED WITH DELAYS TO THE SCHEDULE, ETC. AS A RESULT OF ADDITIONAL REQUIRED REPAIRS SHALL BE CONSIDERED INCIDENTAL TO THE ASSOCIATED REPAIR ITEM AND WILL NOT BE SUBJECT TO ADDITIONAL COMPENSATION.
8.

CONDITIONS AND DIMENSIONS SHOWN ON THE DRAWINGS WHICH REFER TO EXISTING CONSTRUCTION HAVE GENERALLY BEEN DEVELOPED FROM AS-BUILT DRAWINGS OF THE EXISTING STRUCTURES AND SITEWORK. IT IS THE RESPONSIBILITY OF THE CONTRACTOR TO FIELD VERIFY, BEFORE COMMENCING CONSTRUCTION, ALL SUCH CONDITIONS AND DIMENSIONS WHICH PERTAIN TO AND ARE AFFECTED BY THE NEW WORK. IF CONDITIONS AND DIMENSION VARY FROM THOSE SHOWN ON THE DRAWINGS, THE CONTRACTOR SHALL NOTIFY THE ENGINEER IMMEDIATELY.
9.

DUMPSTER RESTRICTIONS AND DEBRIS REMOVAL:

A.

ALL CONSTRUCTION DEBRIS SHALL BE STORED IN AND REMOVED FROM THE SITE IN COMMERCIALY APPROVED DUMPSTER OR EQUAL AS APPROVED BY THE ENGINEER.

B.

DUMPSTER LOCATION FOR CONSTRUCTION DEBRIS MUST BE LOCATED SO AS NOT TO OBSTRUCT VEHICULAR TRAFFIC.

C.

DUMPSTER LOCATIONS SHALL BE SUBJECT TO ENGINEER APPROVAL. ONCE A DUMPSTER IS FILLED, IT SHALL BE REMOVED FROM THE WORK SITE WITHIN 24 HOURS.
10.

HORTICULTURAL REQUIREMENTS:

A.

THE CONTRACTOR SHALL COMPLY WITH ALL "HORTICULTURAL REQUIREMENTS" SPECIFIED BY THE DEPARTMENT OF PUBLIC WORKS. HORTICULTURE CONSTRUCTION CONFLICTS OBSERVED DURING CONSTRUCTION LAYOUT SHALL BE PROVIDED TO THE ENGINEER OF RECORD TO ASSESS PROJECT IMPACT. CONTRACTOR SHALL SUBMIT A REQUEST FOR INFORMATION, WITH JUSTIFICATION FOR PROPOSED CHANGE.

B.

ALL BRANCH PRUNING OR ROOT CUTTING SHALL BE PERFORMED BY A LICENSED ARBORIST, APPROVED BY THE DEPARTMENT OF PUBLIC WORKS.

C.

ALL EXISTING TREES, SHRUBS, AND VEGETATION DISTURBED BY THE CONTRACTOR'S OPERATION SHALL BE REPLACED IN-KIND OR REPAIRED AT NO DIRECT PAY.

D.

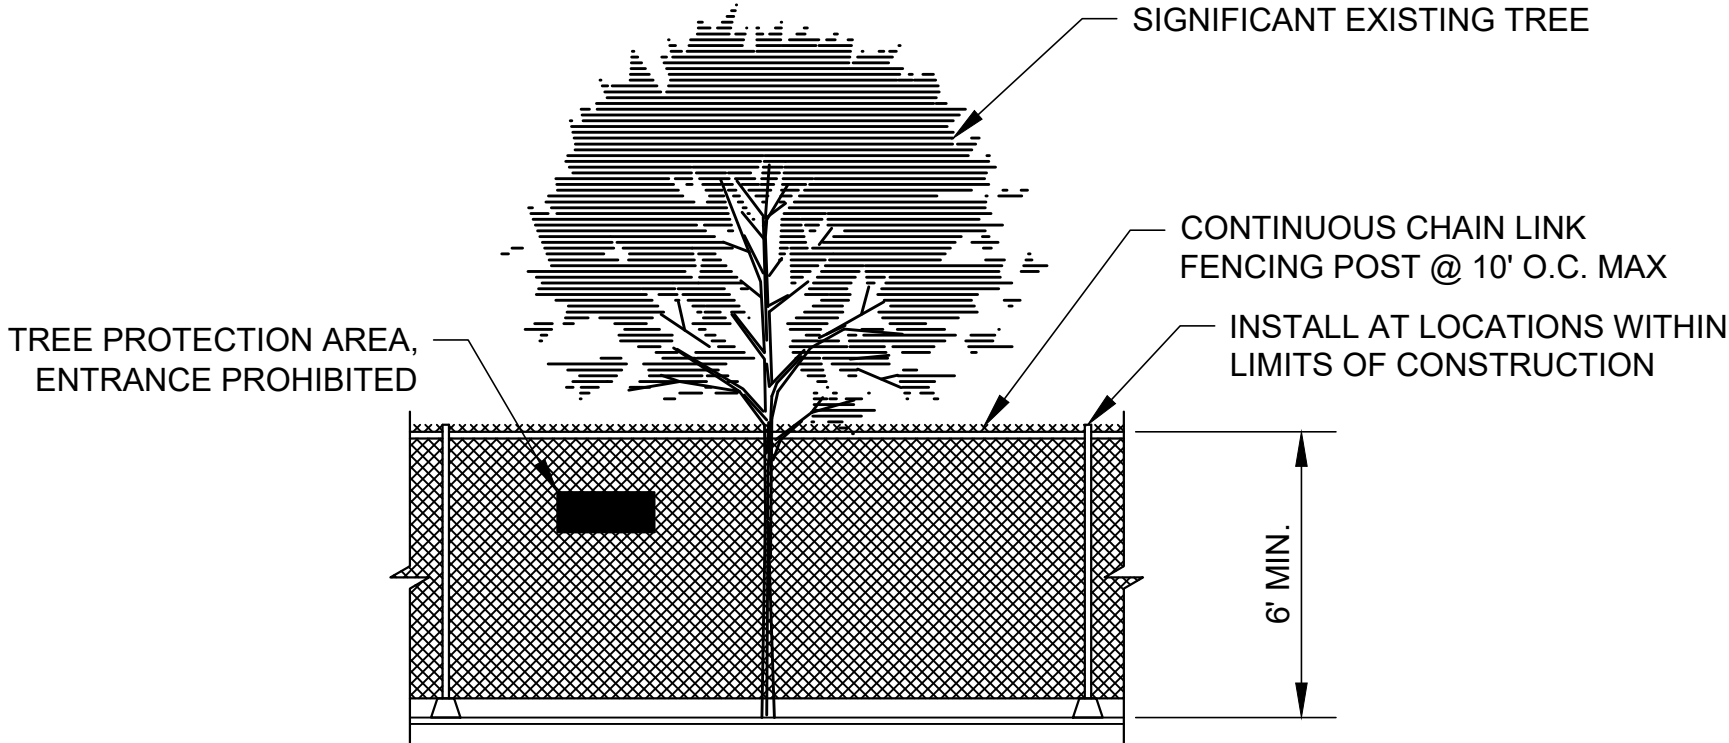
THE CONTRACTOR SHALL NOTIFY THE DEPARTMENT OF PUBLIC WORKS PRIOR TO TRIMMING ANY TREES.

E.

THE CONTRACTOR SHALL BE REQUIRED TO RESTORE ALL GREEN SPACES THAT ARE DISTURBED BY CONSTRUCTION TO ITS PRE-EXISTING CONDITIONS AT NO DIRECT PAYMENT. SEEDING AND SODDING SHALL COMPLY WITH THE REQUIREMENTS OF THE STANDARD SPECIFICATIONS.

F.

HARD PROTECTION OF ANY OAK TREE, INCLUDING THE CANOPY, WITHIN THE LIMITS OF CONSTRUCTION IS REQUIRED AS SHOWN IN THE DETAIL BELOW:



- G.

MINIMUM 6' HIGH TEMPORARY CHAIN LINK FENCE SHALL BE PLACED AT THE CRITICAL ROOT ZONE OR DESIGNATED LIMIT OF DISTURBANCE OF THE TREE TO BE SAVED. FENCE SHALL COMPLETELY ENCIRCLE THE TREE(S). INSTALL FENCE POSTS USING PIER BLOCK ONLY, AVOID STAKES OR POSTS IN MAJOR ROOTS. MODIFICATIONS TO FENCING MATERIAL AND LOCATION MUST BE APPROVED BY THE DEPARTMENT OF PUBLIC WORKS.
- H.

NO STOCKPILING OF MATERIALS, VEHICULAR TRAFFIC, OR STORAGE OF EQUIPMENT OR MACHINERY SHALL BE ALLOWED WITHIN THE LIMIT OF FENCING. FENCING SHALL NOT BE MOVED OR REMOVED UNLESS APPROVED BY THE DEPARTMENT OF PUBLIC WORKS. WORK WITHIN THE PROTECTION FENCE SHALL BE DONE MANUALLY UNDER THE SUPERVISION OF THE ON-SITE ARBORIST AND WITH PRIOR APPROVAL BY THE DEPARTMENT OF PUBLIC WORKS.
- I.

FENCING SIGNAGE AS DETAILED ABOVE MUST BE POSTED EVERY 15 FEET ALONG THE FENCE.
- J.

THE CONTRACTOR SHALL NOT STAGE ANY EQUIPMENT OR MATERIAL WITHIN THE DRIP-LINE OF ANY TREE WITHOUT COORDINATING IN ADVANCE WITH THE CITY PLANNING & ZONING DEPARTMENT.
11.

NO CONTRACTOR OR SUBCONTRACTOR SHALL ENGAGE WITH THE PUBLIC, ONLY THE CITY REPRESENTATIVE OR THE RESIDENT INSPECTOR.
12.

THE CONTRACTOR SHALL COORDINATE WITH THE CITY AND SCHEDULE WORK ACTIVITIES AROUND SCHEDULED EVENTS IN AND AROUND THE LAKEFRONT AREA.
13.

CONTRACTOR SHALL DELIVER REMOVED SHEET PILE SECTIONS TO PUBLIC WORKS FACILITY AT 100 MANDEVILLE HIGH BLVD.
14.

ALLOWABLE CONSTRUCTION ACCESS LOCATIONS HAVE BEEN SHOWN ON THE PLAN SHEETS. CONTRACTOR SHALL COORDINATE EXACT NUMBER AND LOCATIONS WITH THE CITY.
15.

A CHAIN LINK FENCE SHALL BE PLACED AROUND THE WORK AREA AT ALL TIMES TO LIMIT PUBLIC ACCESS TO THE CONSTRUCTION SITE.

STRUCTURAL NOTES:

DESIGN CRITERIA:

1.

STRUCTURAL DESIGN IS IN ACCORDANCE WITH THE FOLLOWING DOCUMENTS.  
INTERNATIONAL BUILDING CODE-2018  
AMERICAN SOCIETY OF CIVIL ENGINEERS ASCE 7-22  
AMERICAN CONCRETE INSTITUTE ACI 318-19 (22) (CONCRETE DESIGN)  
AMERICAN INSTITUTE OF STEEL CONSTRUCTION MANUAL 16th EDITION

CONSTRUCTION SPECIFICATIONS:

1.

CONSTRUCTION SHALL BE IN ACCORDANCE WITH THE SPECIFICATIONS FOR "MANDEVILLE SEAWALL REPAIRS PROJECT SEGMENT I."

DIMENSIONS:

1.

ALL DIMENSIONS ARE HORIZONTAL UNLESS OTHERWISE NOTED ON PLANS, AND MEASURED AT NORMAL TEMPERATURE (68°F). CONTRACTOR TO VERIFY ALL CONDITIONS AND DIMENSIONS IN THE FIELD.

STRUCTURAL METALWORK:

1.

UNLESS OTHERWISE INDICATED IN THE PLANS, STRUCTURAL STEEL MATERIALS SHALL CONFORM TO THE FOLLOWING ASTM STANDARDS.

|             |                         |
|-------------|-------------------------|
| PLATES      | A572 GR. 50             |
| ANCHOR RODS | F1554 GR. 55 (WELDABLE) |
| ELECTRODES  | E-70 XX                 |

ANY NECESSARY SUBSTITUTION MUST HAVE PRIOR APPROVAL OF THE PROJECT ENGINEER.

WELDING:

1.

WELDING OF ALL STRUCTURAL STEEL SHALL CONFORM TO AWS PUBLICATION D1.1 "STRUCTURAL WELDING CODE". ALL WELDS THAT ARE TO BE MADE ON ANY STRUCTURAL STEEL MEMBERS SHALL BE ONLY AS SHOWN IN THE STRUCTURAL DRAWINGS, AND SUBJECT TO REVIEW BY THE DESIGN ENGINEER. "ALL WELDS" IS DEFINED AS ANY WELD PLACED FROM INITIATION OF FABRICATION TO FINAL ACCEPTANCE INCLUDING FABRICATION, TRANSPORTATION, ERECTION AND CONSTRUCTION. ALL WELDS SHALL BE CONTINUOUS, UNLESS NOTED OTHERWISE. ALL WELDS SHALL BE MADE WITH E70 ELECTRODES.

REINFORCING STEEL:

1.

ALL REINFORCING STEEL SHALL BE ASTM A 615, GRADE 60. DIMENSIONS RELATING TO REINFORCING STEEL FABRICATION ARE OUT TO OUT OF BAR UNLESS OTHERWISE NOTED. DIMENSIONS RELATING TO REINFORCING STEEL SPACING ARE CENTER TO CENTER OF BAR. THE MINIMUM COVERING FROM THE SURFACE OF THE CONCRETE TO THE FACE OF ANY DEFORMED REINFORCING BAR SHALL NOT BE LESS THAN 3" UNLESS OTHERWISE NOTED. ALL LAP SPLICES SHALL BE CLASS "B" SPLICES.

DEV. LENGTH & LAP SPLICE TABLE

| BAR SIZE | LAP CLASS | UNCOATED |       |
|----------|-----------|----------|-------|
|          |           | TOP      | OTHER |
| #5       | A         | 31       | 24    |
|          | B         | 40       | 31    |
| #6       | A         | 37       | 28    |
|          | B         | 48       | 37    |
| #7       | A         | 54       | 42    |
|          | B         | 70       | 54    |
| #8       | A         | 62       | 47    |
|          | B         | 80       | 62    |
| #9       | A         | 70       | 54    |
|          | B         | 90       | 70    |
| #10      | A         | 78       | 60    |
|          | B         | 102      | 78    |
| #11      | A         | 87       | 67    |
|          | B         | 113      | 87    |

1.

LAP SPLICE LENGTHS ARE MULTIPLIER OF TENSION DEVELOPMENT LENGTHS; CLASS A =  $L_d$  AND CLASS B =  $(1.3)L_d$
2.

TOP BARS ARE HORIZONTAL BARS WITH MORE THAN 12 in. OF CONCRETE CAST BELOW THE BARS.


CONCRETE:

1.

CONCRETE SHALL HAVE A MINIMUM COMPRESSION STRENGTH ( F'c) OF 4000 PSI AT 28 DAYS. CHAMFER ALL EXPOSED EDGES OF CONCRETE ¾". A MINIMUM OF 6" COVER SHALL BE PROVIDED OVER SHEET PILING AT ALL POINTS.

ABBREVIATIONS

|         |                         |
|---------|-------------------------|
| APPROX. | = APPROXIMATE           |
| BOT.    | = BOTTOM                |
| BT.     | = BENT                  |
| CONC.   | = CONCRETE              |
| EF.     | = EACH FACE             |
| EXIST.  | = EXISTING              |
| EXP.    | = EXPANSION             |
| JT.     | = JOINT                 |
| L.O.C.  | = LIMIT OF CONSTRUCTION |
| MAX.    | = MAXIMUM               |
| MIN.    | = MINIMUM               |
| STA.    | = STATION               |
| W/L     | = WALL LINE             |
| VERT.   | = VERTICAL              |

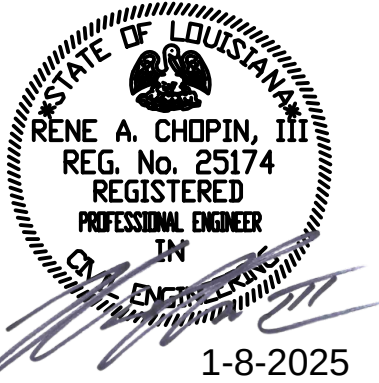

02

SHEET NUMBER

BY

REVISION DESCRIPTION

DATE

NO.

BKJ BURK-KLEINPETER, INC.

ENGINEERING PLANNING ENVIRONMENTAL

BKJUSA.COM

COM PROJ. NO. 100.21.019

BKJ # : NO.24-007

DESIGNED R/C

CHECKED RACIII

DATE

SHEET

DETAILED SG

CHECKED R/C

January, 2025

1 of 1

MANDEVILLE SEAWALL REPAIRS PROJECT

SEGMENT 1

GENERAL NOTES

STATE OF LOUISIANA

RENE A. CHOPIN, III

REG. No. 25174

REGISTERED

 
PROFESSIONAL ENGINEER

IN

LOUISIANA

1-8-2025






1. ALL REPAIR LOCATION STATIONS ARE APPROXIMATE BASED ON AS-BUILT W/L. CONTRACTOR SHALL VERIFY ALL LOCATIONS IN THE FIELD.
2. THE L.O.C SHALL BE LOCATED 10' BEHIND THE BACK OF THE SPLASH BLOCK.

30' 20' 10' 0 30' 60'



1"=30'

 [illegible]






- PLAN  
SCALE: 1" = 30'

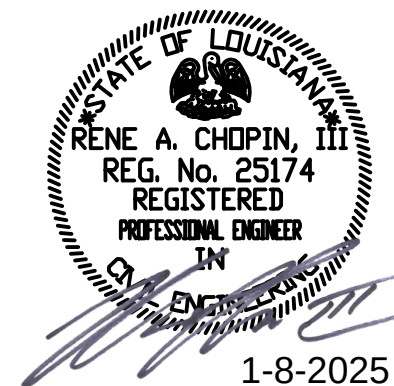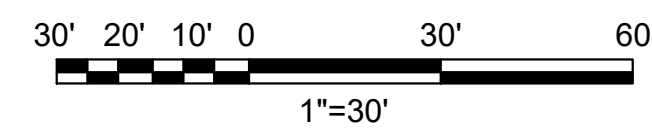


|          |               |
|----------|---------------|
| DESIGNED | RJC           |
| CHECKED  | RACIII        |
| DETAILED | SG            |
| CHECKED  | RJC           |
| DATE     | January, 2025 |
| SHEET    | 2 OF 5        |

 [illegible]





- PLAN  
SCALE: 1" = 30'

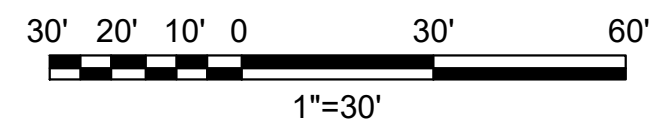
[illegible]



NOTE:

- ALL REPAIR LOCATION STATIONS ARE APPROXIMATE BASED ON AS-BUILT W/L. CONTRACTOR SHALL VERIFY ALL LOCATIONS IN THE FIELD.
- THE L.O.C SHALL BE LOCATED 10' BEHIND THE BACK OF THE SPLASH BLOCK.

 PLAN  
SCALE: 1" = 30'



MANDENVILLE SEAWALL REPAIRS PROJECT

SEGMENT 1  
PLAN SHEET

|          |               |
|----------|---------------|
| DESIGNED | R/C           |
| CHECKED  | RACIII        |
| DETAILED | SG            |
| CHECKED  | R/C           |
| DATE     | January, 2025 |
| SHEET    | 4 of 5        |

**BURK-KLEINPETER, INC.**

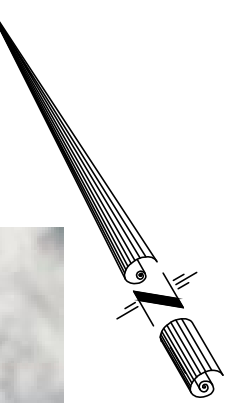
ENGINEERINGPLANNINGENVIRONMENTAL

BKUSA.COM

COM PROJ. NO. 100.21.019BKI #: NO.24.007

|              |  |
|--------------|--|
| 06           |  |
| SHEET NUMBER |  |
|              |  |
|              |  |
1. ALL REPAIR LOCATION STATIONS ARE APPROXIMATE BASED ON AS-BUILT W/L. CONTRACTOR SHALL VERIFY ALL LOCATIONS IN THE FIELD.
2. THE L.O.C SHALL BE LOCATED 10' BEHIND THE BACK OF THE SPLASH BLOCK.

30' 20' 10' 0 30' 60'

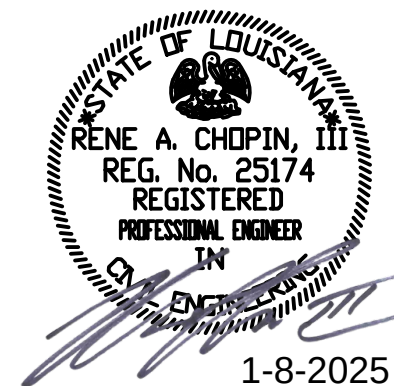
1"=30'

[illegible]



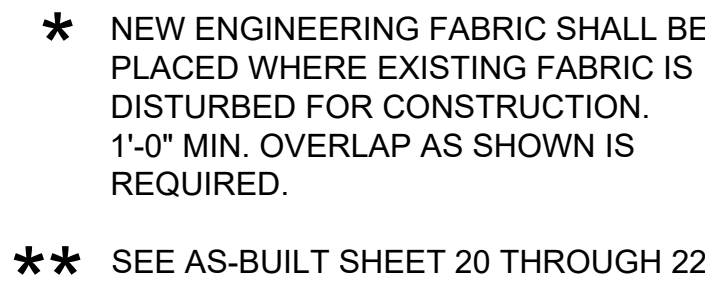


SCALE: 1" = 1

 


1. REMOVE EXIST. SPLASH BLOCK.
2. INSTALL CATHODIC PROTECTION, SEE CATHODIC PROTECTION DETAILS.
3. INSTALL NEW SPLASH BLOCK. WITHIN SIMILAR LIMITS OF THE EXISTING SPLASH BLOCK.
4. GRADE EMBANKMENT TO DRAIN.

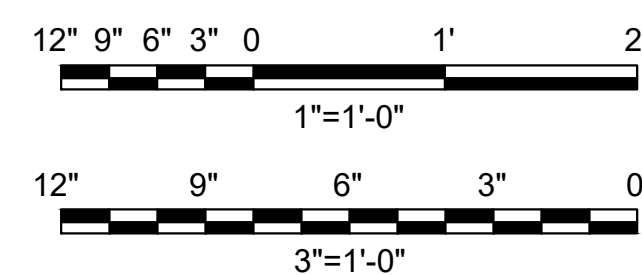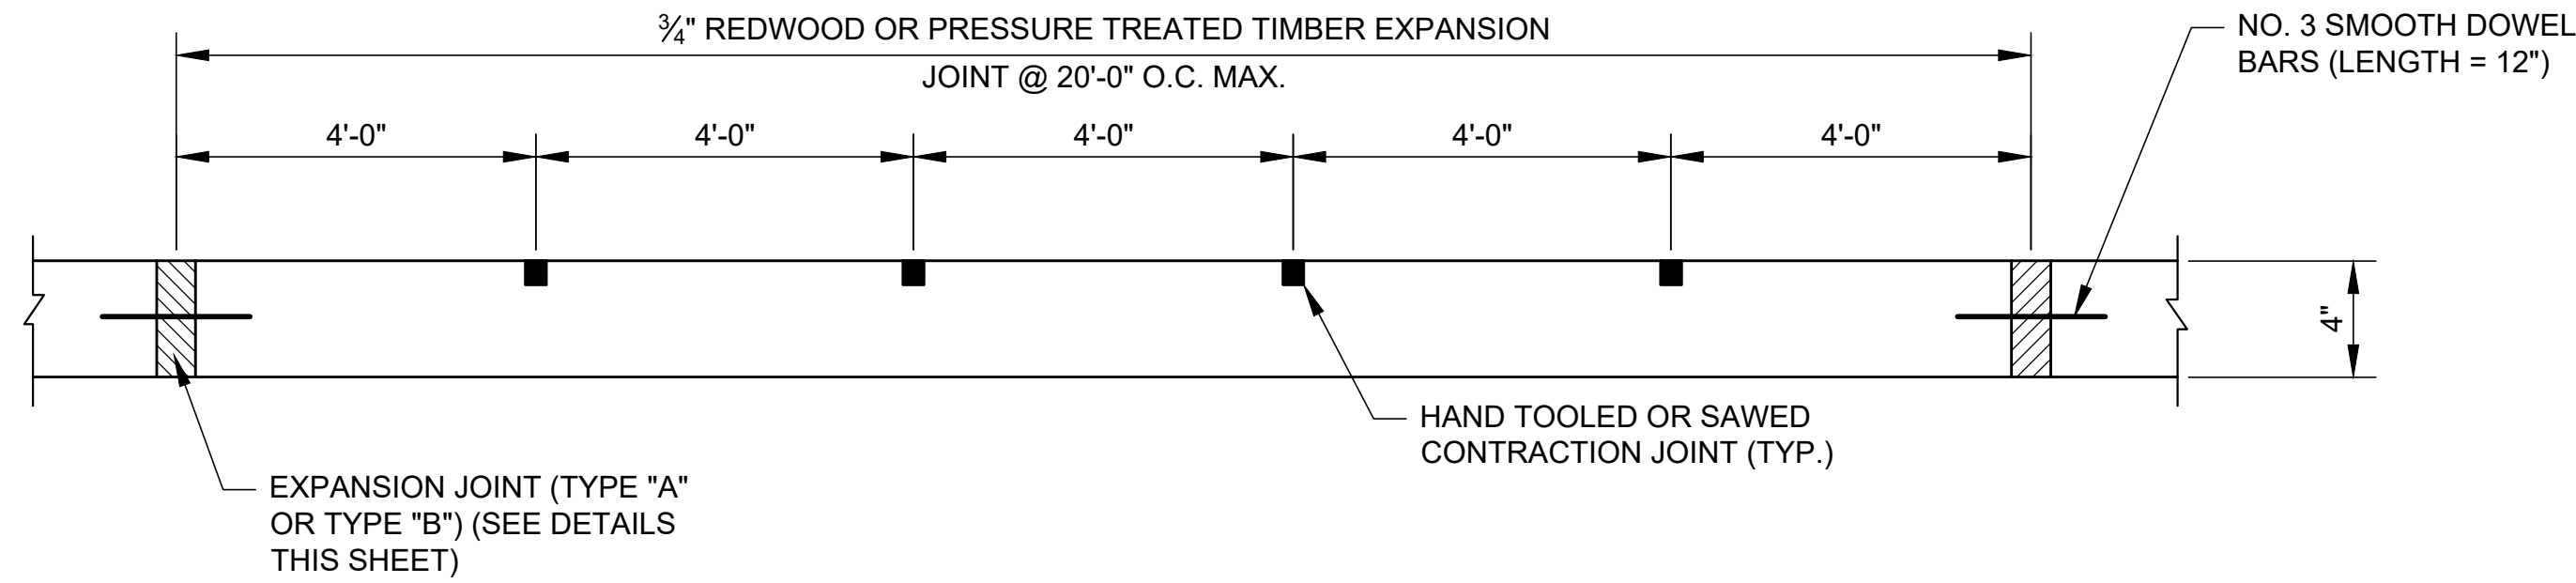
1. REMOVE SPLASH BLOCK TO NEAREST JOINT ALONG PATH AT APPROXIMATE STATION 81+33.25, AS DIRECTED BY THE PROJECT ENGINEER. REPLACE SPLASH BLOCK TO THE SAME LIMITS WITHIN THIS VICINITY, INCLUDING THE CURBED SECTION.
2. AT APPROXIMATE STATION 81+33.25 TO 81+86.37, REMOVE AND REPLACE THE SPLASH BLOCK LOCATED BEHIND THE CONCRETE BULKHEAD.









ELEVATION VIEW OF SPLASH BLOCK

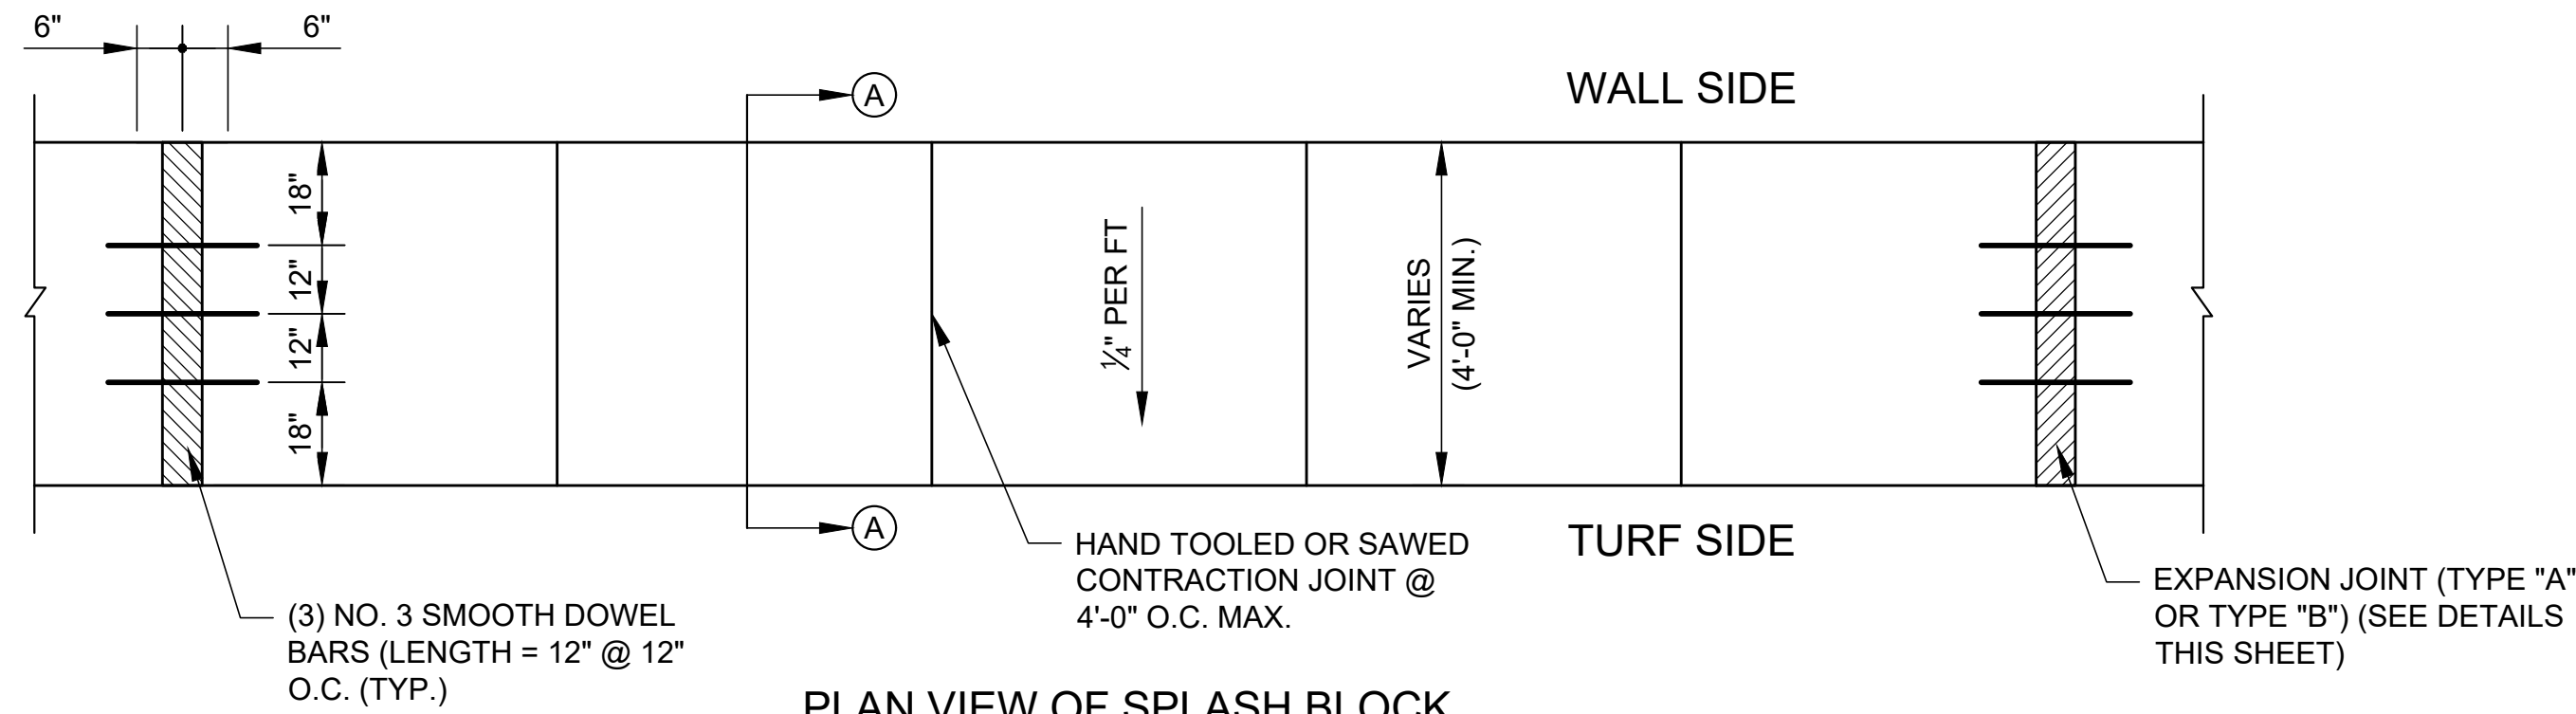


PLAN VIEW OF SPLASH BLOCK

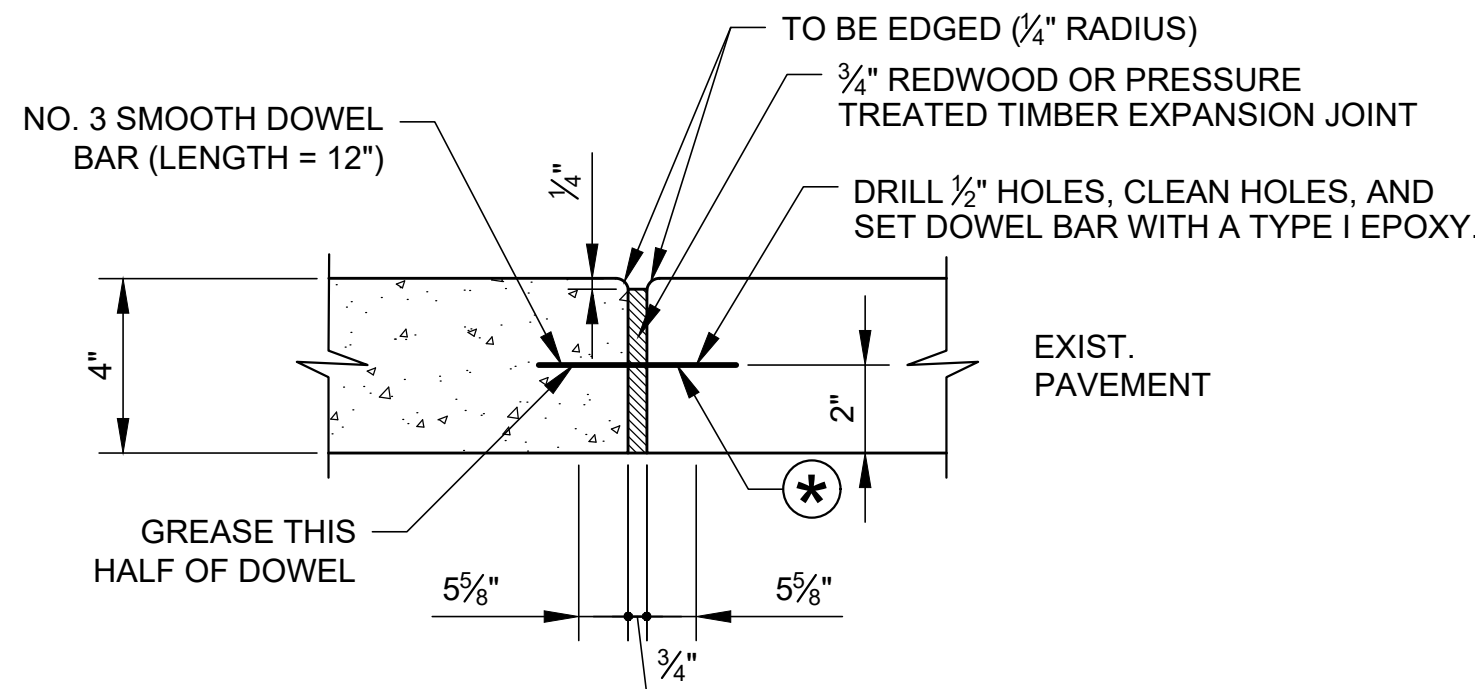

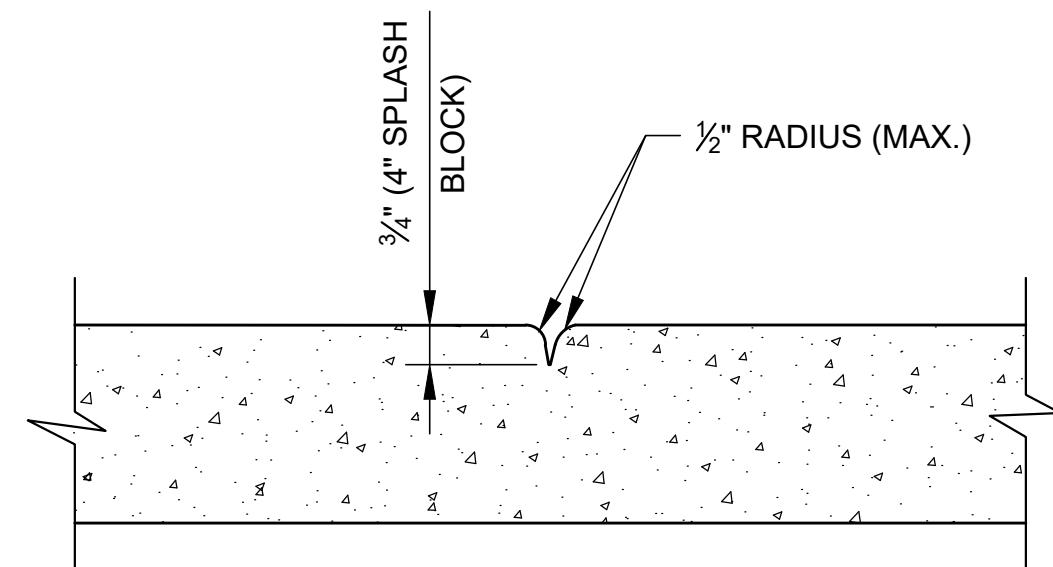EXPANSION JOINT (TYPE "B")  
(AT EXISTING PAVEMENT)  
(MAXIMUM SPACING = 20'-0")  
N.T.S.







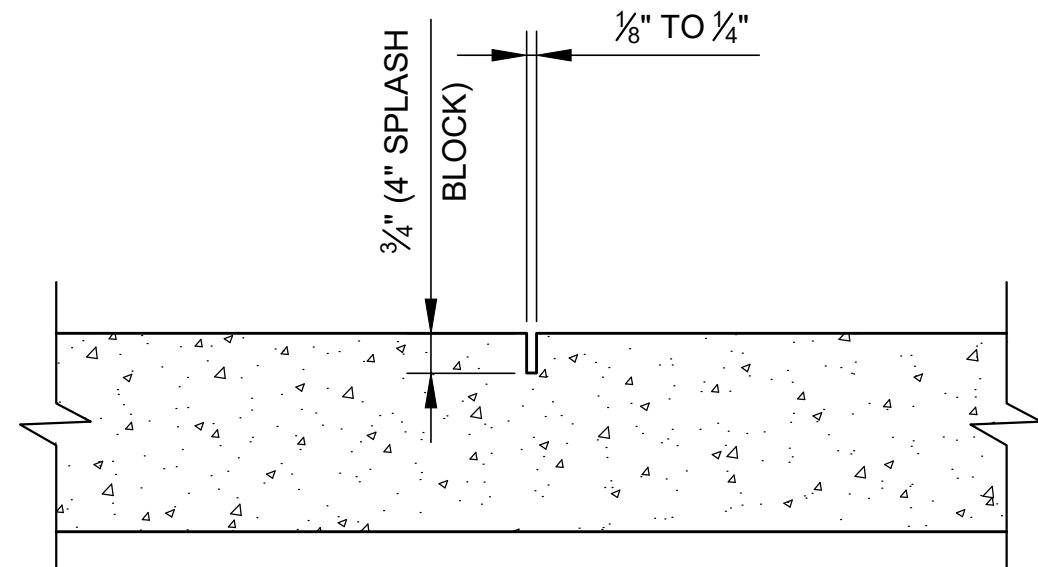HAND TOOLED CONTRACTION JOINT  
(MAXIMUM SPACING = 4'-0")  
N.T.S.







SAWED CONTRACTION JOINT  
(MAXIMUM SPACING = 4'-0")  
N.T.S.

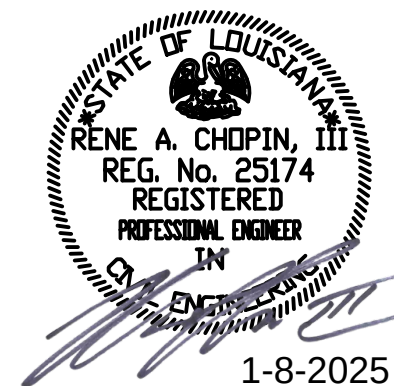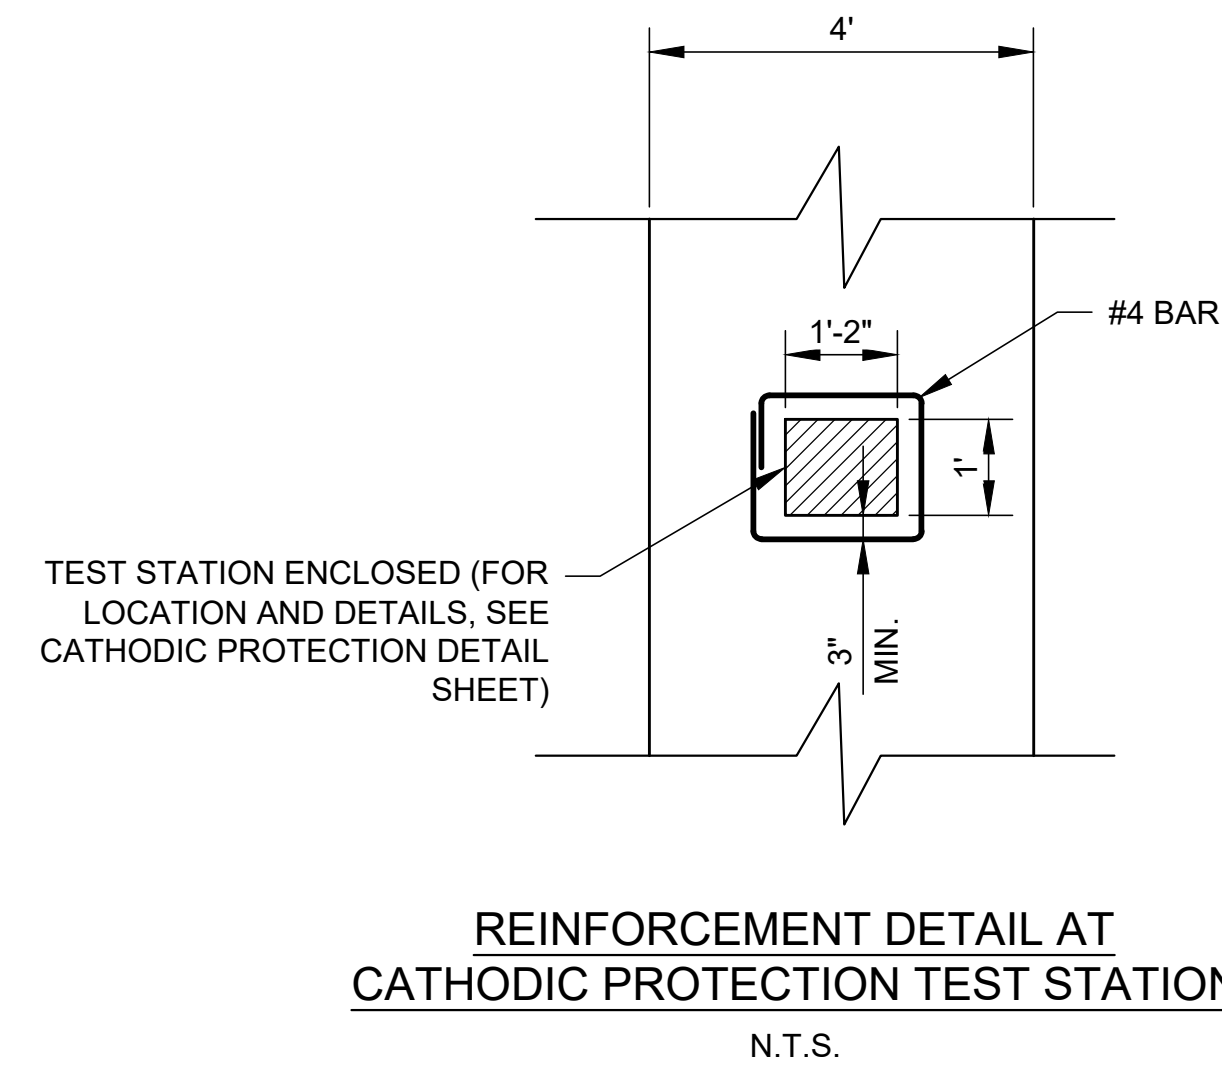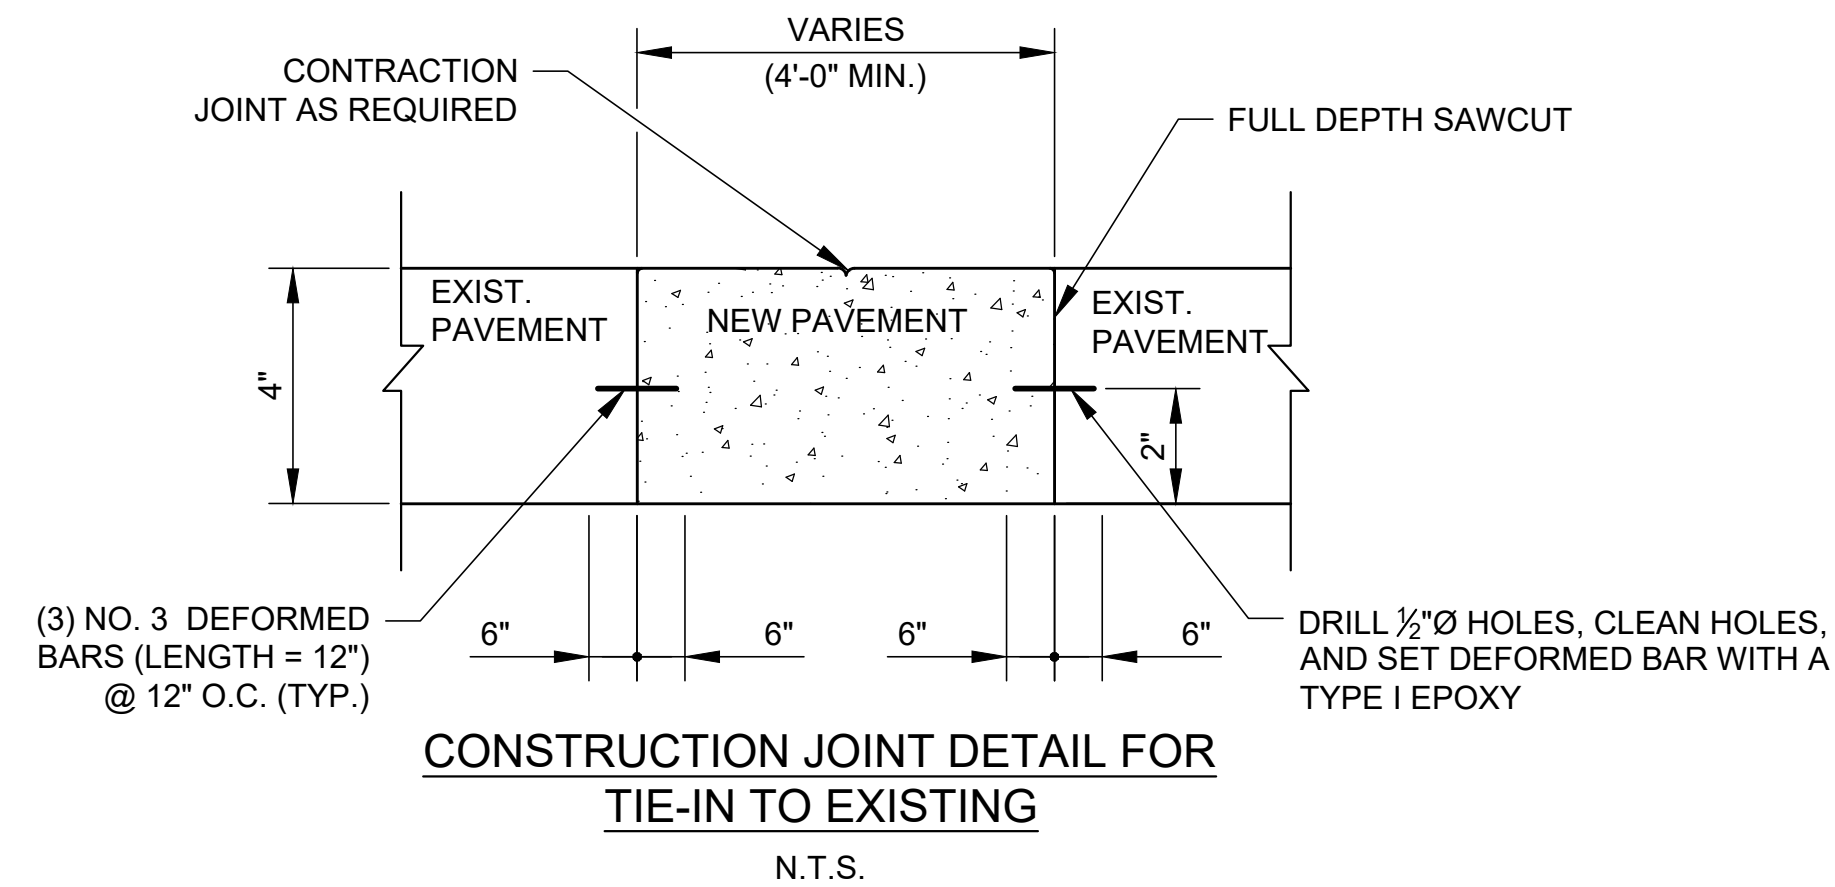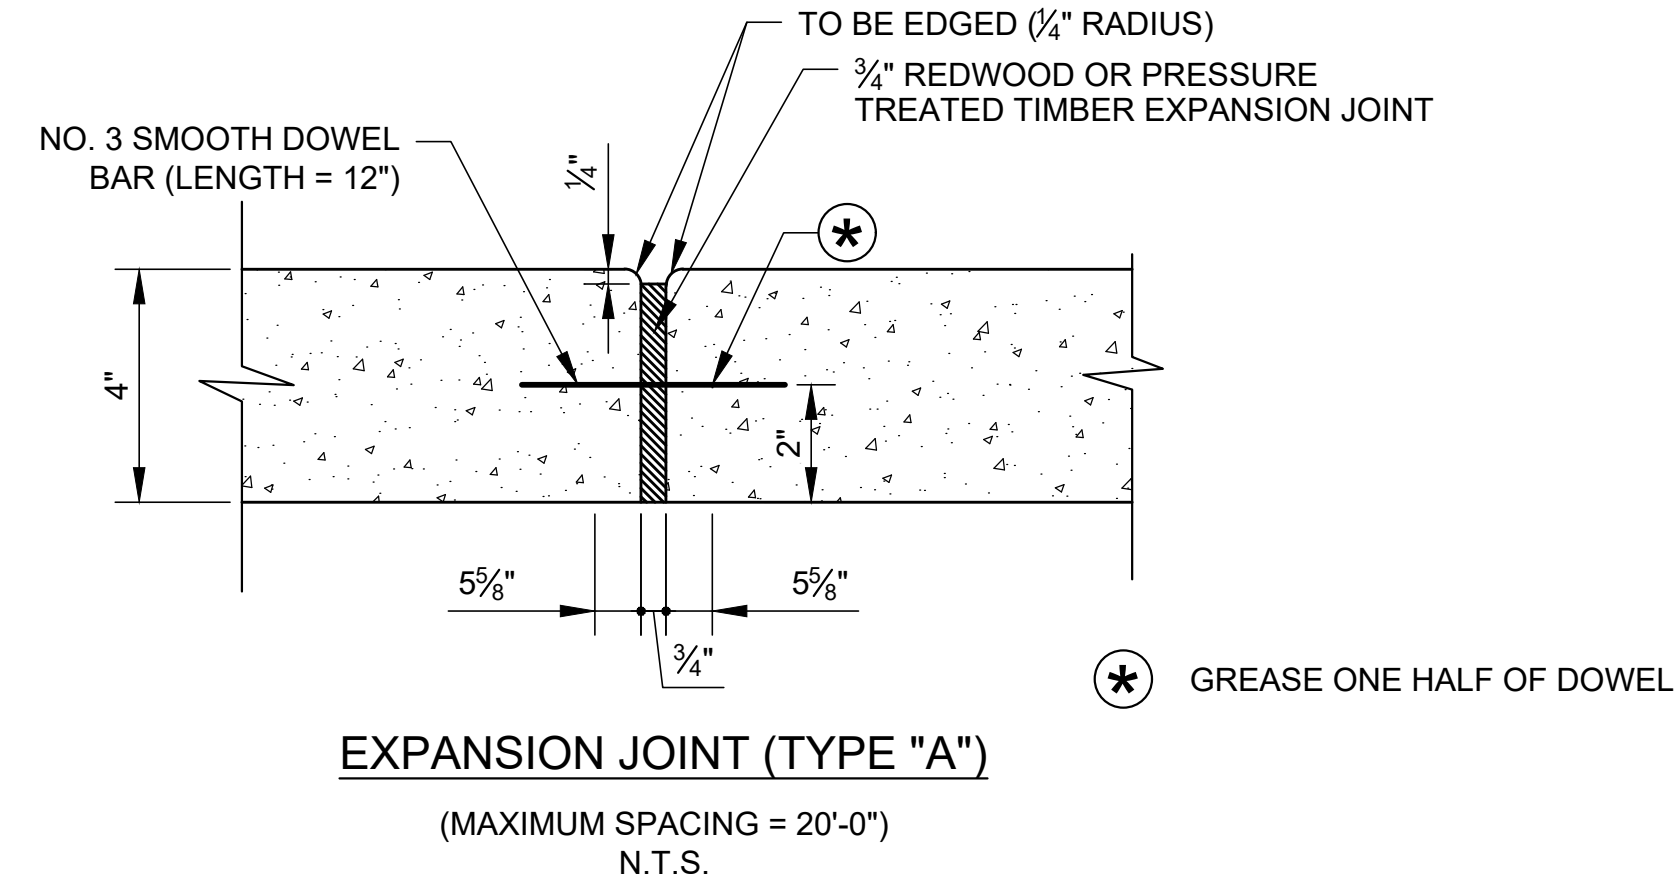CONCRETE SPECIFICATIONS:  
CONCRETE COMPRESSIVE STRENGTH = 4,000 PSI (MIN.) AT TWENTY-EIGHT (28) DAYS.  
MAXIMUM SLUMP = 5" AIR CONTENT = 5% ±2%  
EXPANSION MATERIAL MAY BE TREATED (ROT RESISTANT) TIMBER OR REDWOOD.




|                                                                                       |                         |
|---------------------------------------------------------------------------------------|-------------------------|
| 09                                                                                    |                         |
| SHEET NUMBER                                                                          |                         |
| BY                                                                                    |                         |
| REVISION DESCRIPTION                                                                  |                         |
| DATE                                                                                  |                         |
| NO.                                                                                   |                         |
| COM PROJ. NO. 100.21.019                                                              |                         |
| BK1 # : NO.24.007                                                                     |                         |
| BKI BURK-KLEINPETER, INC. ENGINEERING PLANNING ENVIRONMENTAL                          |                         |
| DESIGNED<br>CHECKED<br>RAC                                                            | SG                      |
| DATE<br>SHEET                                                                         | January, 2025<br>2 of 2 |
| MANDEVILLE SEAWALL REPAIRS PROJECT                                                    |                         |
| SEGMENT 1                                                                             |                         |
| REPAIR DETAILS TYPE A (SPLASH BLOCK)                                                  |                         |
|  |                         |



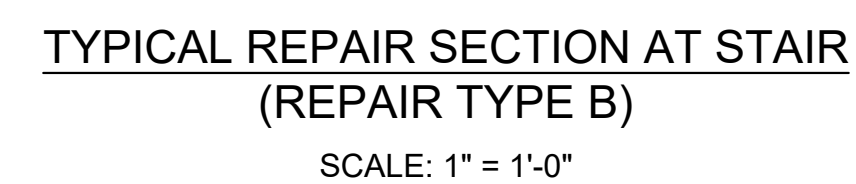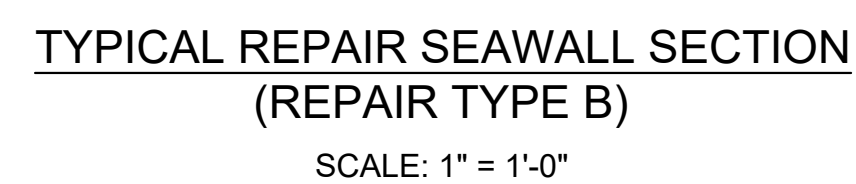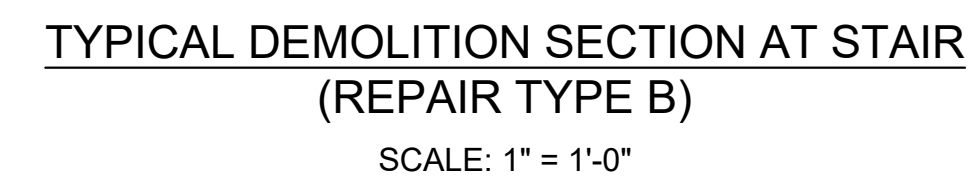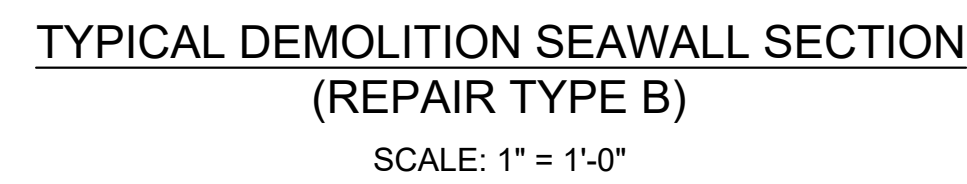

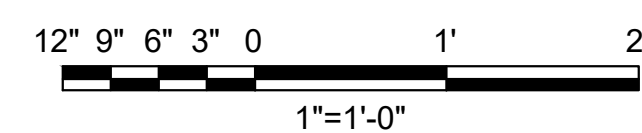
1. REMOVE EXISTING CONCRETE BULKHEAD. DURING REMOVAL, THE CONTRACTOR SHALL PROTECT EXIST. PZ-22 STEEL SHEET PILING FROM DAMAGE. THE CONTRACTOR SHALL BE RESPONSIBLE FOR THE REPAIR OF ANY DAMAGE TO THE SHEET PILING CAUSED BY THE REMOVAL OF THE CONCRETE CAP.
2. INSTALL NEW CONCRETE BULKHEAD CAP.
3. FINISH WITH CONCRETE SURFACE PROTECTIVE COATING, PER SPECIFICATION SECTION 03310.




STATE OF LOUISIANA  
RENE A. CHOPIN, III  
REG. No. 25174  
REGISTERED  
PROFESSIONAL ENGINEER  
IN  
CIVIL ENGINEERING  
1-8-2025

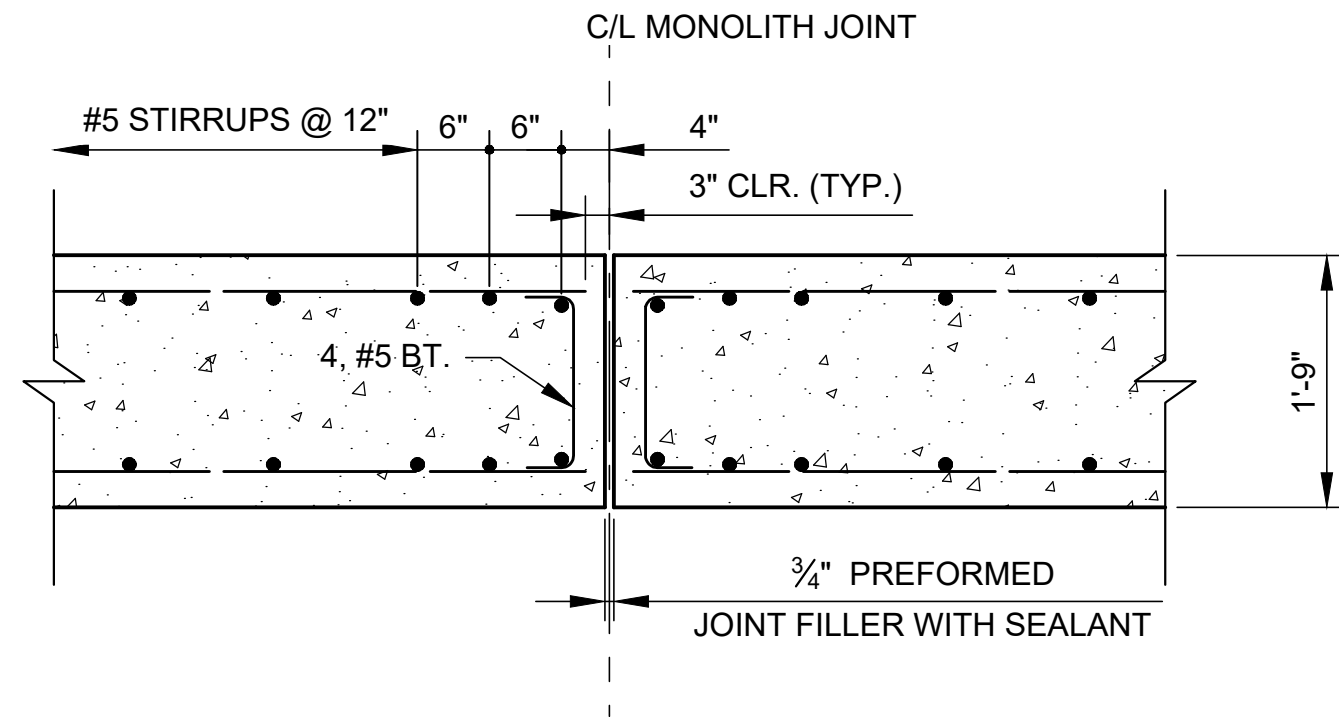[illegible]






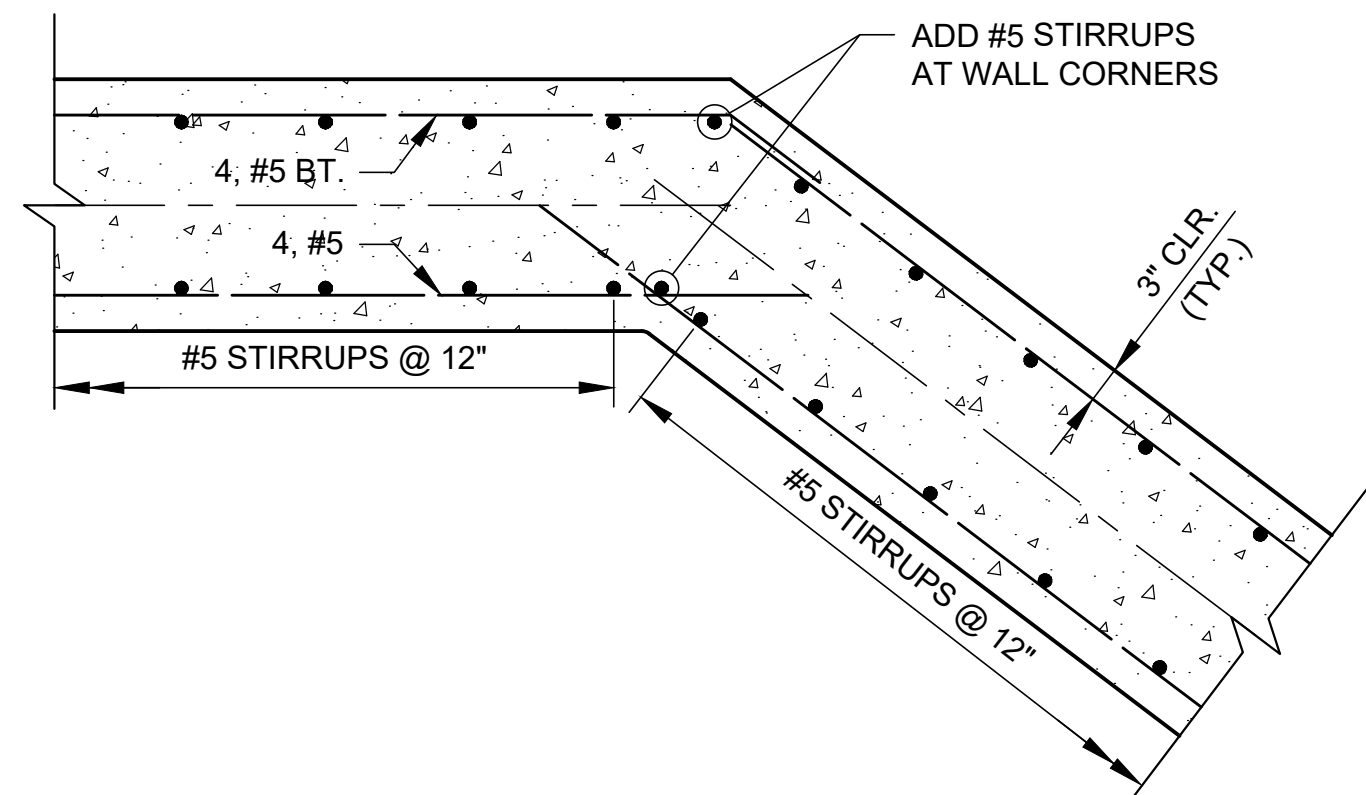
**TYPICAL REINFORCEMENT  
AT MONLITH JOINT**  
SCALE: 3/4" = 1'




LAND SIDE

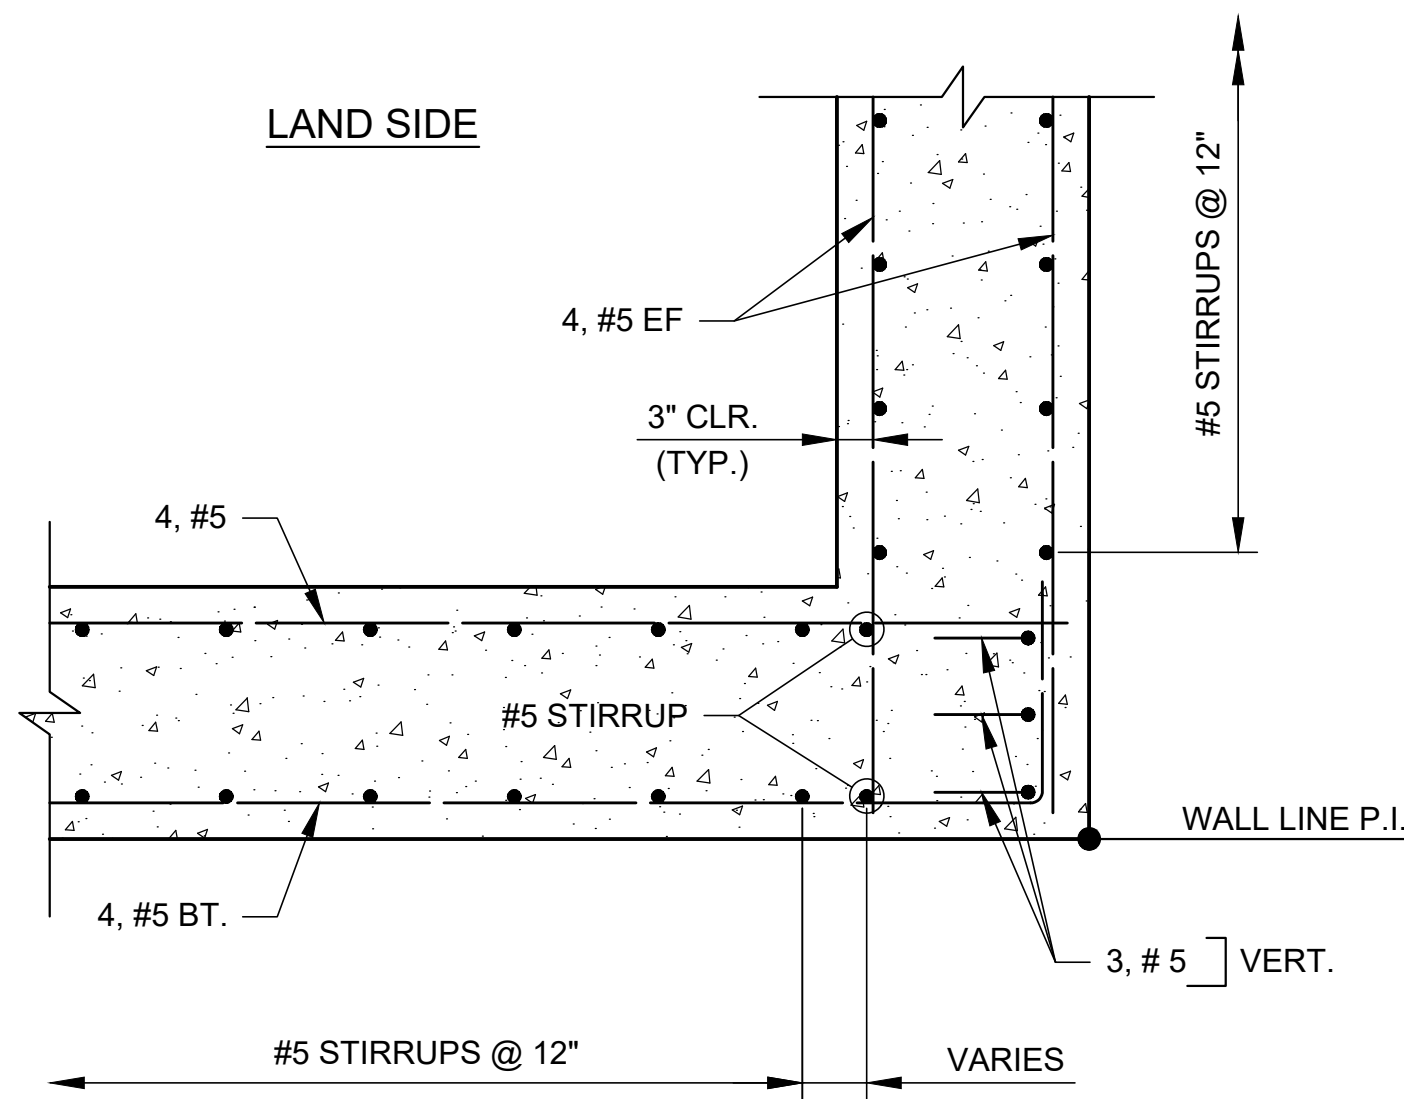

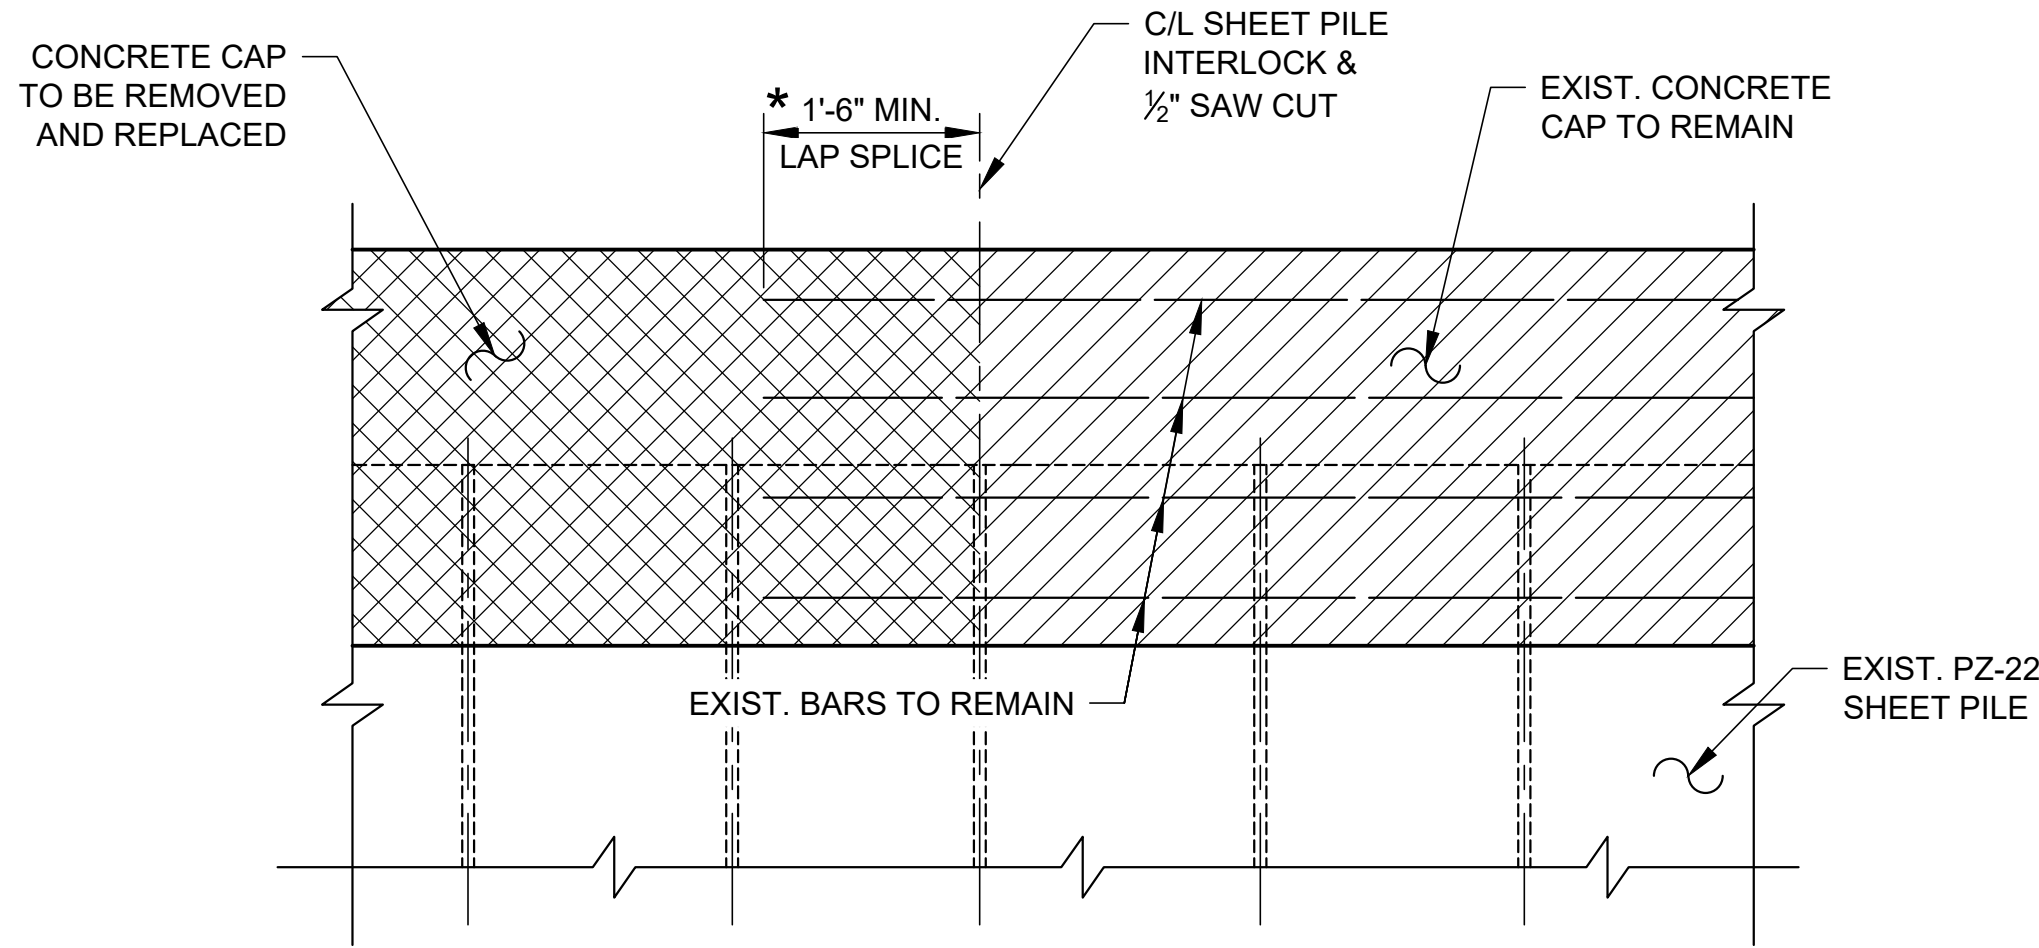**TYPICAL REINFORCEMENT PLAN  
AT POINTS OF INTERSECTION**  
SCALE: 3/4" = 1'



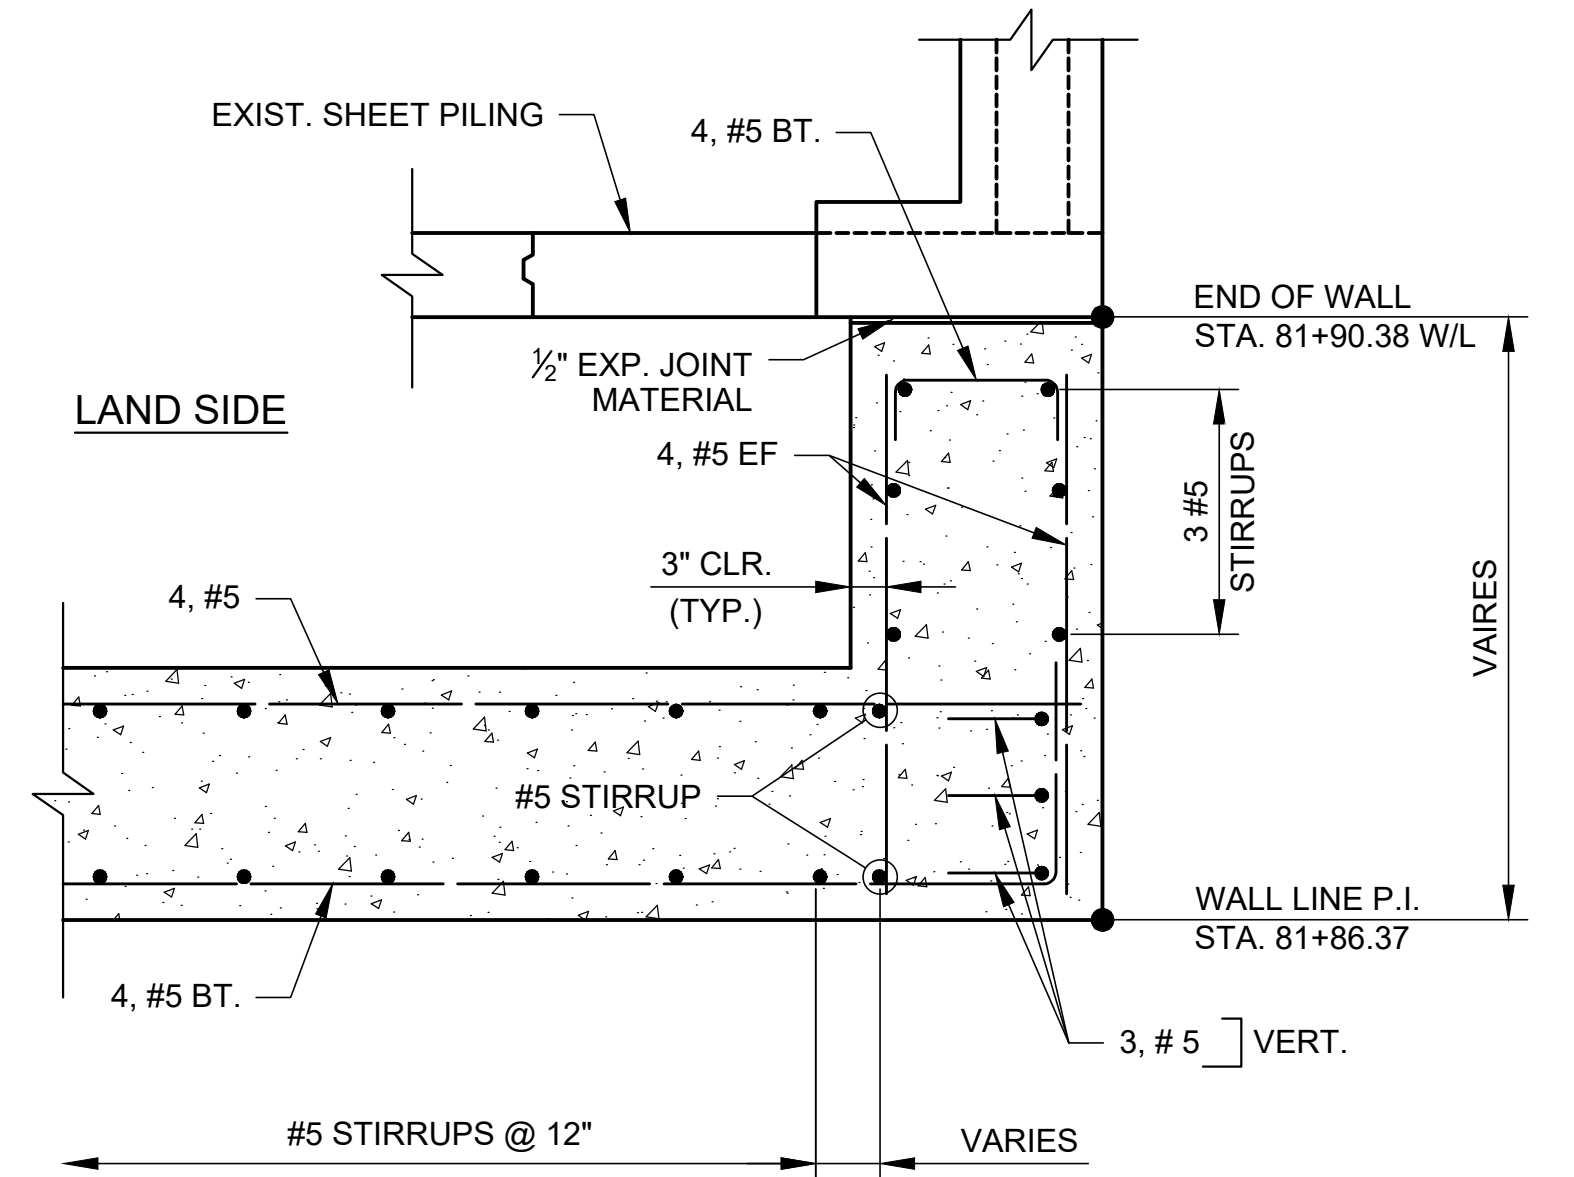
**TYPICAL REINFORCEMENT  
DETAIL AT APPROX. STA. 82+46.80**  
SCALE: 3/4" = 1'



**NOTE:**

1. STA. 82+37.79 W/L OPPOSITE HAND.

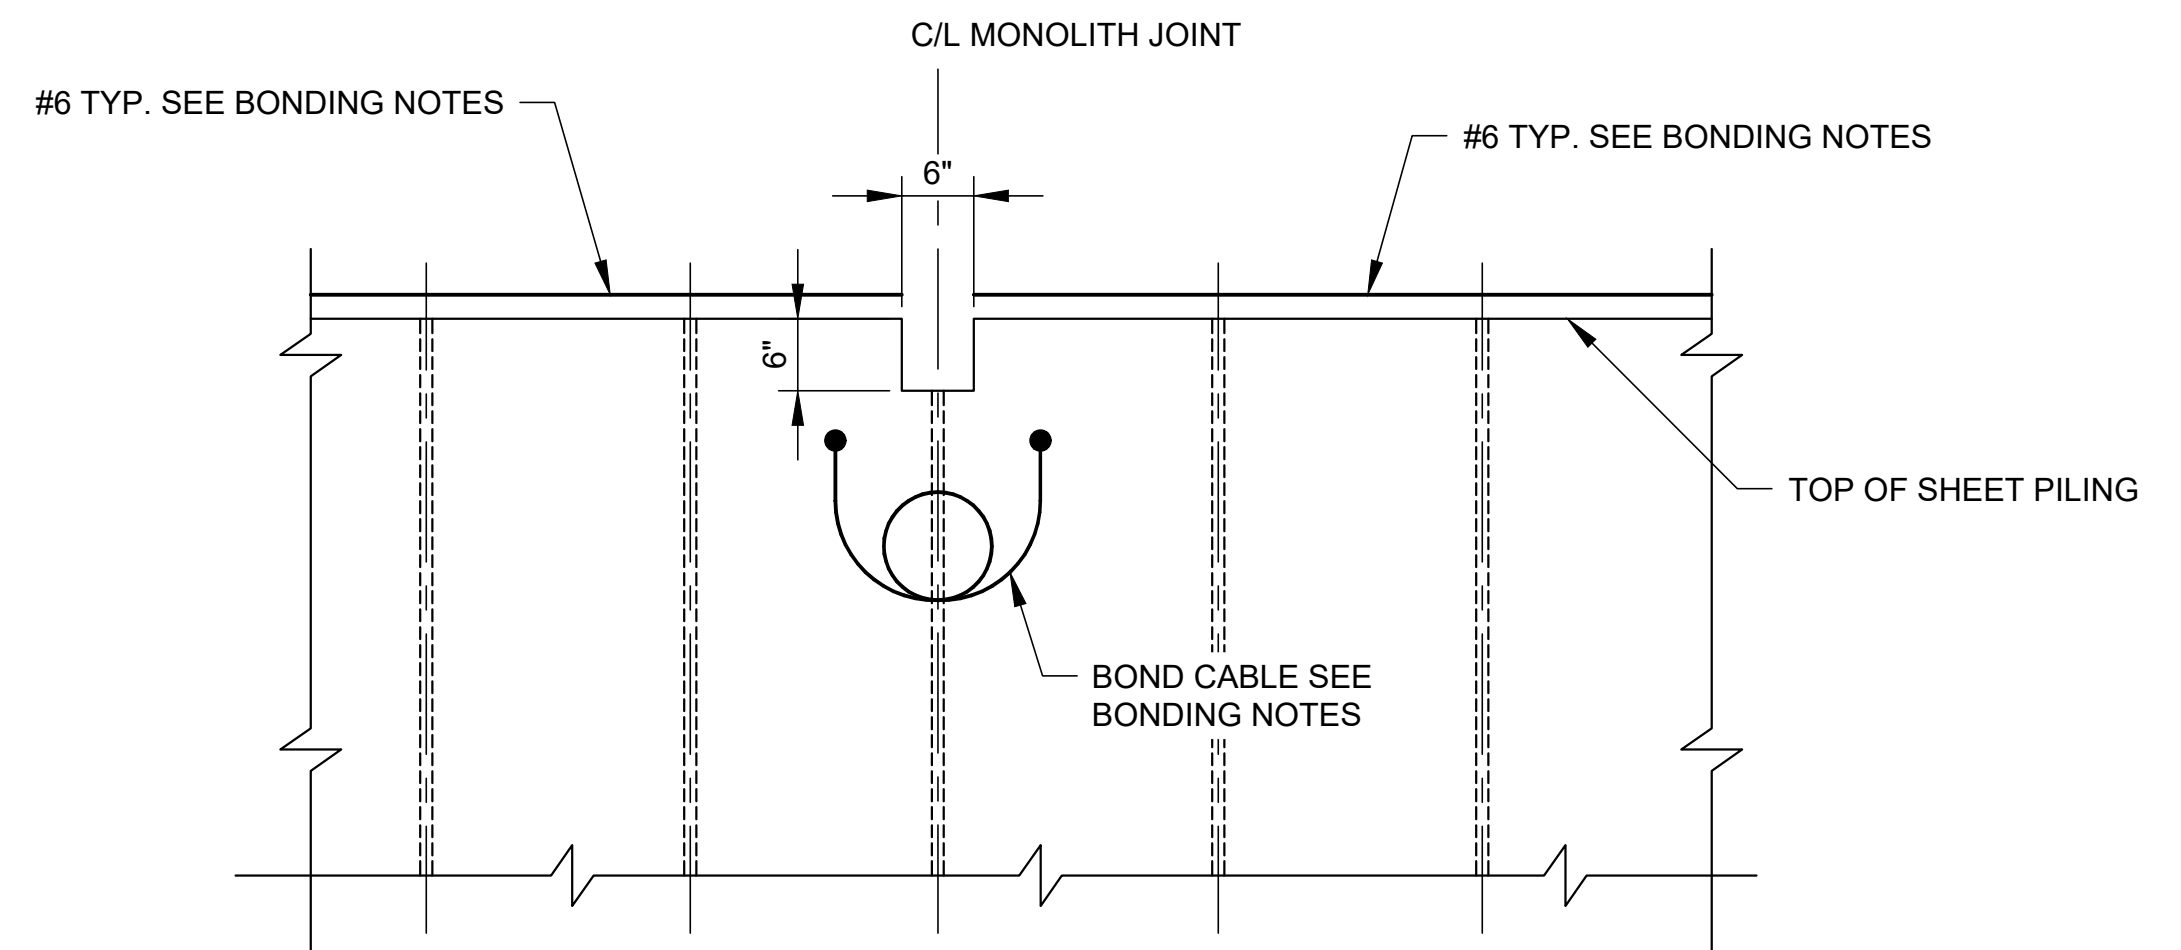**TYPICAL REINFORCEMENT PLAN  
AT WALL TERMINATIONS**  
SCALE: 3/4" = 1'




**LAND SIDE ELEVATION  
EXISTING SHEET PILING DETAILS  
SEAWALL MONOLITH JOINTS**  
SCALE: 3/4" = 1'

**BONDING NOTES:**

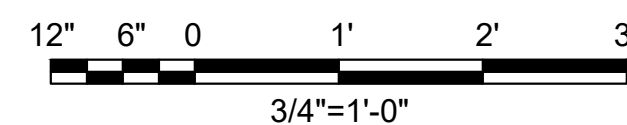1. CONTRACTOR SHALL INSPECT EXISTING BOND CABLES AND REPLACE AS REQUIRED.
2. ALL REQUIRED BONDING REPAIRS SHALL BE PAID FOR UNDER "REMOVAL OF STRUCTURAL CONCRETE (BULKHEAD)"


**NOTE:**

1. CONTRACTOR SHALL USE THE EXISTING HOLES THROUGH SHEET PILE FOR NEW STIRRUPS.
- ★ 2. CONTRACTOR TO CLEAN EXISTING REINFORCING BARS AND INSPECT BOND CABLE TO ENSURE IT'S INTEGRITY BEFORE POURING CONCRETE. ALL WORK ASSOCIATED WITH THIS REPAIR INCLUDING SAW CUTTING, CLEANING, AND PREPARATION OF EXISTING CONCRETE CAP AND REINFORCEMENT BARS SHALL BE PAID FOR UNDER "REMOVAL OF STRUCTURAL CONCRETE (BULKHEAD)".



|                                              |  |                       |  |
|----------------------------------------------|--|-----------------------|--|
| 11<br>SHEET NUMBER                           |  | BY                    |  |
| REVISION DESCRIPTION                         |  | DATE                  |  |
| NO.                                          |  | DATE                  |  |
| COM PROJ. NO. 100.21.019                     |  | BKI # : NO.24.007     |  |
| ENGINEERING                                  |  | ENVIRONMENTAL         |  |
| PLANNING                                     |  | ENVIRONMENTAL         |  |
| BKI                                          |  | BURK-KLEINPETER, INC. |  |
| DESIGNED<br>CHECKED<br>RACIII                |  | R/C                   |  |
| DETAILED<br>CHECKED<br>SG                    |  | S/G                   |  |
| DATE<br>JANUARY, 2025                        |  | 2 OF 2                |  |
| MANDEVILLE SEAWALL REPAIRS PROJECT           |  |                       |  |
| SEGMENT 1                                    |  |                       |  |
| REPAIR DETAILS TYPE B<br>(CONCRETE BULKHEAD) |  |                       |  |
|                                              |  |                       |  |




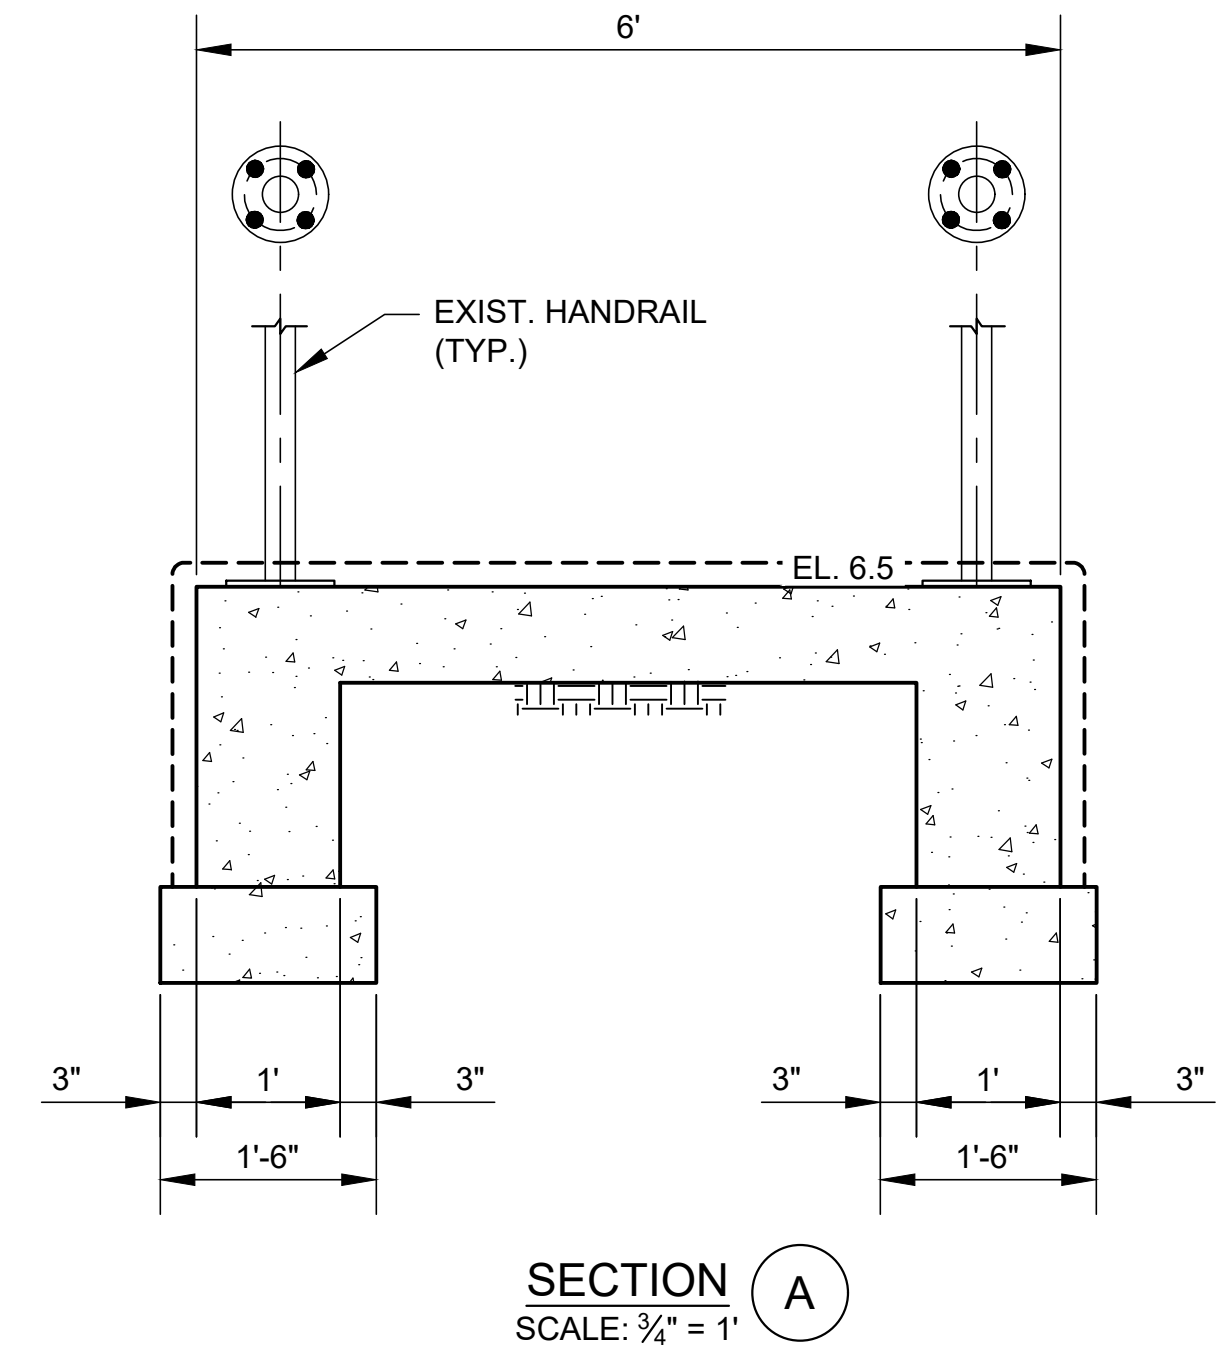

SECTION  
SCALE:  $\frac{3}{4}" = 1'$  (A)

----- LIMITS OF STEP REPAIRS AS REQUIRED PER  
CONSTRUCTION SEQUENCE NOTES.

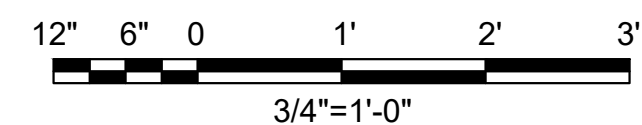1. RESET EXISTING LAND SIDE CONCRETE STAIRS TO ELEVATION 6.5.
2. FOR CRACKS GREATER THAN OR EQUAL TO  $\frac{1}{8}$ " , ROUTE A V-GROOVE ALONG THE ENTIRE LENGTH OF THE CRACK. DRILL  $\frac{1}{4}$ " DIAMETER X  $\frac{1}{2}$ " DEEP HOLES APPROXIMATELY 12" APART ALONG THE CRACK. INJECT EPOXY SEALANT PER THE MANUFACTURERS RECOMMENDATION TO SEAL THE CRACK.
3. FINISH WITH CONCRETE SURFACE PROTECTIVE COATING, PER SPECIFICATION SECTION 03311. COATING SHALL BE APPLIED TO WATERS EDGE ENSURING PROPER APPLICATION OF SURFACE PROTECTIVE COATING PER MANUFACTURERS RECOMMENDATIONS.

[illegible]



17/2025

P:\NO.24.XXX\NO.24-007 OLD MANDEVILLE SEAWALL REPAIR SEGMENT 1\02\_DESIGN\02 CIVIL\01 DRAWING\13\_REPAIR DETAILS\_06

CONSTRUCTION SEQUENCE NOTES:

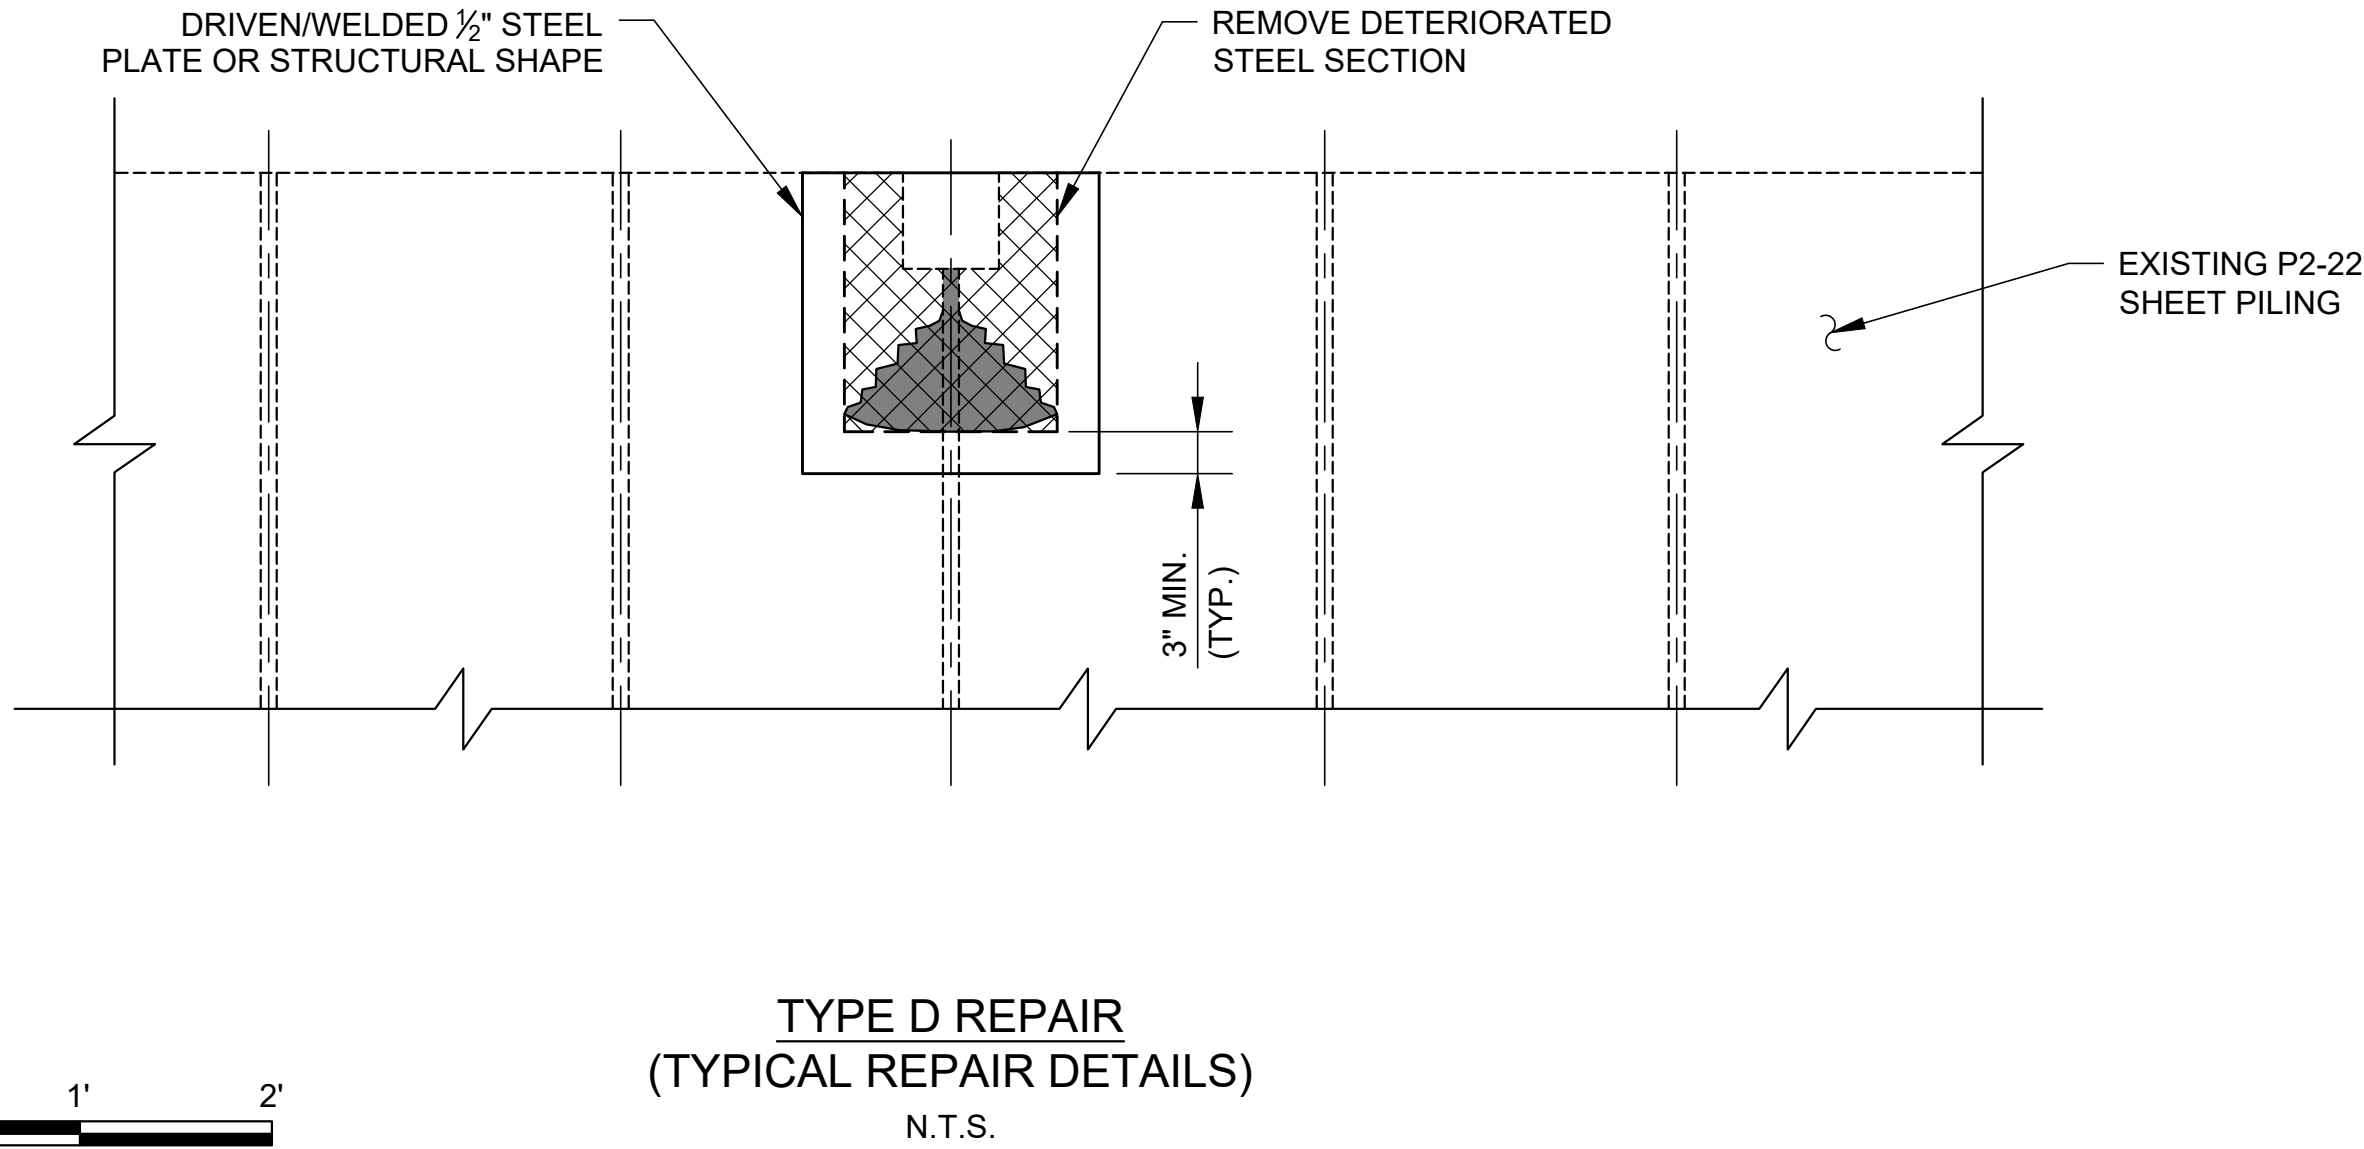
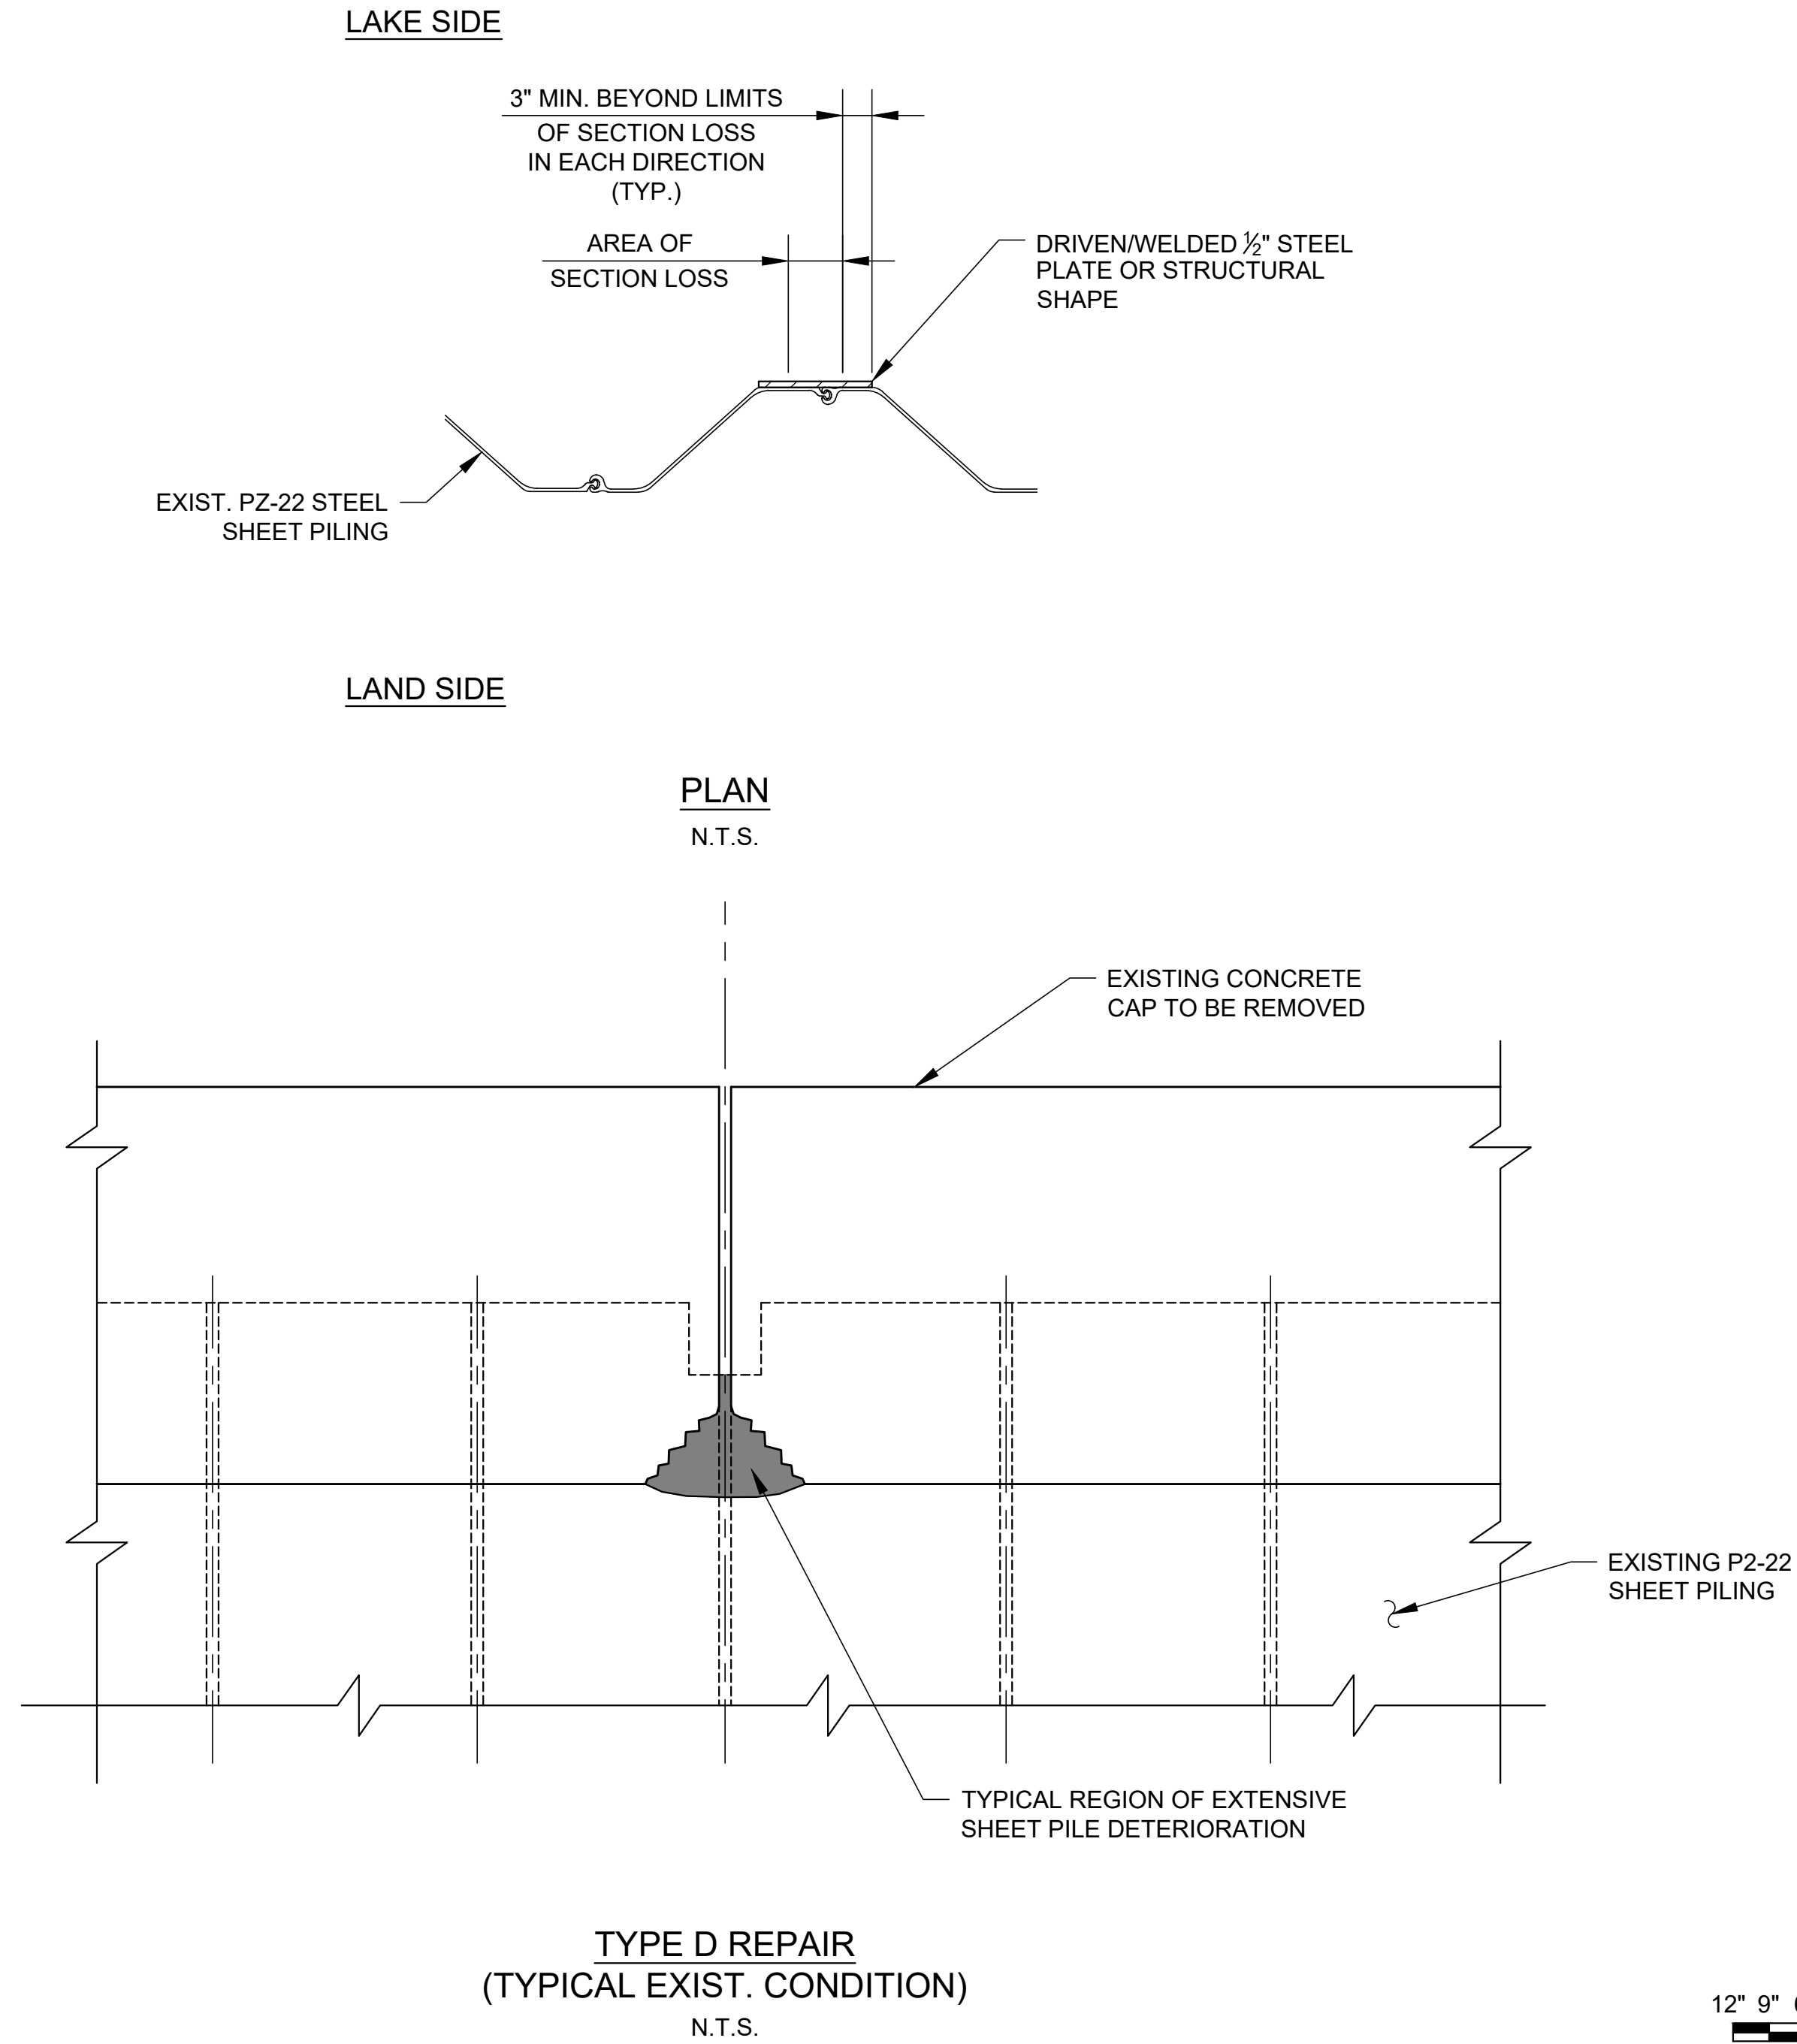
- AFTER CONCRETE BULKHEAD IS REMOVED, BEFORE IT IS REPLACED, CUT THE DETERIORATED STEEL SECTION AND BRIDGE THE OPENING BY WELDING STEEL PLATES OR STRUCTURAL SHAPES. EXTEND WELDING ALONG THE SEAMS TO SEAL THE OPENING.
- IF SECTION DETERIORATION EXTENDS OVER A LARGE SECTION OF THE WALL WITH NOTED LARGE WALL VOIDS, THEN BRIDGE THE DETERIORATED SECTION UTILIZING DRIVEN OR WELDED STEEL PLATES OR SHEET SECTIONS.
- RESTORE CONCRETE BULKHEAD SECTION AND BACKFILL AS REQUIRED.

NOTES:

- IN LATE 2022 AND EARLY 2023, THE CITY OF MANDEVILLE PERFORMED AN INSPECTION OF THE SEAWALL. THE ADJACENT TABLE IS A RESULT OF THE INSPECTION. THE CITY OF MANDEVILLE DOES NOT GUARANTEE THE CONDITIONS ARE THE SAME AT THIS DATE. THIS INFORMATION IS PROVIDED TO THE CONTRACTOR AS AN INDICATION OF THE TYPE AND AMOUNT OF REPAIRS THAT WERE PRESENT ON THAT DATE. THE TYPE AND AMOUNT OF REPAIRS IS SUBJECT TO CHANGE PER EXISTING FIELD CONDITIONS.

STEEL COATING NOTES:

- ALL STEEL REPAIRS WELDED OR DRIVEN, ABOVE OR BELOW WATER, SHALL BE COATED WITH COAL-TAR EPOXY.
- IF THE REPAIR IS TO BE WELDED, THE EDGES SHALL BE COAL-TAR EPOXY COATING FREE.
- AFTER WELDING, ALL EXPOSED STEEL AND WELDING MATERIAL SHALL BE COATED USING A SPLASH ZONE EPOXY MATERIAL.
- ALL COATING MATERIALS SHALL BE PLACED PER THE MANUFACTURERS SPECIFICATIONS.
- STEEL COATINGS FOR REPAIR TYPE D SHALL BE PAID FOR UNDER "STEEL REPAIR TYPE D."



QUANTITIES REFLECT  
SURVEY CONDITIONS AS OF DECEMBER 2022  
AND JANUARY 2023  
FOR REFERENCE ONLY

| REPAIR TYPE D |                                      |                                 |                                |                                     |
|---------------|--------------------------------------|---------------------------------|--------------------------------|-------------------------------------|
| APPROX. STA.  | APPROX. SIZE OF DETERIORATED SECTION | LOCATION                        | LOCATION RELATIVE TO WATERLINE | LOCATION RELATIVE TO NATURAL BOTTOM |
| 42+05.00      | 1'-4" X 1'-0"                        | BULKHEAD EXP. JT.               | ABOVE                          | ABOVE                               |
| 43+69.00      | 4'-5" X 1'-10"                       | BULKHEAD EXP. JT.               | ABOVE                          | ABOVE                               |
| 44+98.00      | 0'-11" X 0'-5"                       | BULKHEAD EXP. JT.               | ABOVE                          | ABOVE                               |
| 47+86.00      | 0'-11" X 0'-7"                       | BULKHEAD EXP. JT.               | ABOVE                          | ABOVE                               |
| 51+98.00      | 2'-6" X 1'-5"                        | BULKHEAD EXP. JT.               | ABOVE                          | ABOVE                               |
| 52+57.00      | 3'-4" X 1'-3"                        | BULKHEAD EXP. JT.               | ABOVE                          | ABOVE                               |
| 53+16.00      | 0'-5" X 0'-1/4"                      | SHEET PILE KNUCKLE BELOW CAP    | ABOVE                          | ABOVE                               |
| 53+85.00      | 1'-0" X 0'-10"                       | BULKHEAD EXP. JT.               | ABOVE                          | ABOVE                               |
| 54+36.00      | 3'-10" X 2'-0"                       | BULKHEAD EXP. JT.               | ABOVE                          | ABOVE                               |
| 54+94.00      | 3'-11" X 1'-4"                       | BULKHEAD EXP. JT.               | ABOVE                          | ABOVE                               |
| 55+50.00      | 1'-5" X 0'-7"                        | BOT. OF BULKHEAD, NEAR EXP. JT. | ABOVE                          | ABOVE                               |
| 56+11.00      | 3'-0" X 1'-10"                       | BULKHEAD EXP. JT.               | ABOVE                          | ABOVE                               |
| 56+70.00      | 2'-8" X 1'-6"                        | BULKHEAD EXP. JT.               | ABOVE                          | ABOVE                               |
| 57+27.00      | 1'-6" X 1'-0"                        | BULKHEAD EXP. JT.               | ABOVE                          | ABOVE                               |
| 57+86.00      | 2'-0" X 1'-0"                        | BULKHEAD EXP. JT.               | ABOVE                          | ABOVE                               |
| 58+46.00      | 1'-8" X 1'-7"                        | BULKHEAD EXP. JT.               | ABOVE                          | ABOVE                               |
| 59+05.00      | 2'-0" X 1'-2"                        | BULKHEAD EXP. JT.               | ABOVE                          | ABOVE                               |
| 59+63.00      | 1'-9" X 1'-7"                        | BULKHEAD EXP. JT.               | ABOVE                          | ABOVE                               |
| 60+80.00      | 3'-6" X 2'-0"                        | BULKHEAD EXP. JT.               | ABOVE                          | ABOVE                               |
| 61+38.00      | 3'-3" X 2'-0"                        | BULKHEAD EXP. JT.               | ABOVE                          | ABOVE                               |
| 61+98.00      | 3'-5" X 2'-0"                        | BULKHEAD EXP. JT.               | ABOVE                          | ABOVE                               |
| 62+56.00      | 1'-10" X 1'-4"                       | BULKHEAD EXP. JT.               | ABOVE                          | ABOVE                               |
| 63+15.00      | 3'-0" X 2'-4"                        | BULKHEAD EXP. JT.               | ABOVE                          | ABOVE                               |
| 63+74.00      | 1'-8" X 1'-7"                        | BULKHEAD EXP. JT.               | ABOVE                          | ABOVE                               |
| 64+31.00      | 4'-3" X 1'-7"                        | BULKHEAD EXP. JT.               | ABOVE                          | ABOVE                               |
| 64+90.00      | 2'-4" X 2'-0"                        | BULKHEAD EXP. JT.               | ABOVE                          | ABOVE                               |
| 65+49.00      | 1'-8" X 1'-4"                        | BULKHEAD EXP. JT.               | ABOVE                          | ABOVE                               |
| 67+77.00      | 1'-8" X 0'-10"                       | BULKHEAD EXP. JT.               | ABOVE                          | ABOVE                               |
| 70+09.00      | 1'-8" X 0'-10"                       | BULKHEAD EXP. JT.               | ABOVE                          | ABOVE                               |
| 70+68.00      | 3'-2" X 2'-0"                        | BULKHEAD EXP. JT.               | ABOVE                          | ABOVE                               |
| 71+27.00      | 2'-4" X 1'-9"                        | BULKHEAD EXP. JT.               | ABOVE                          | ABOVE                               |
| 71+86.00      | 1'-9" X 0'-10"                       | BULKHEAD EXP. JT.               | ABOVE                          | ABOVE                               |
| 73+07.00      | 2'-4" X 1'-9"                        | BULKHEAD EXP. JT.               | ABOVE                          | ABOVE                               |
| 73+65.00      | 3'-5" X 1'-7"                        | BULKHEAD EXP. JT.               | ABOVE                          | ABOVE                               |
| 74+21.00      | 2'-5" X 1'-8"                        | BULKHEAD EXP. JT.               | ABOVE                          | ABOVE                               |
| 74+81.00      | 2'-7" X 2'-0"                        | BULKHEAD EXP. JT.               | ABOVE                          | ABOVE                               |
| 75+91.00      | 2'-5" X 2'-0"                        | BULKHEAD EXP. JT.               | ABOVE                          | ABOVE                               |
| 78+21.00      | 3'-0" X 1'-6"                        | BULKHEAD EXP. JT.               | ABOVE                          | ABOVE                               |

13

SHEET NUMBER

BY

REVISION DESCRIPTION

DATE

NO.

BKIBURK-KLEINPETER, INC.

ENGINEERING

PLANNING

ENVIRONMENTAL

BKIBUSA.COM

COM PROJ. NO. 100.21.019

BK # : NO.24.007

DESIGNED  
CHECKED  
R/C  
RACIII

DATE  
SHEET

1  
1

January, 2025

of

1

MANDEVILLE SEAWALL REPAIRS PROJECT

SEGMENT 1

REPAIR DETAILS TYPE D

(SHEET PILE AT BULKHEAD EXP. JOINTS)

STATE OF LOUISIANA

RENE A. CHOPIN, III

REG. No. 25174

REGISTERED

PROFESSIONAL ENGINEER

IN

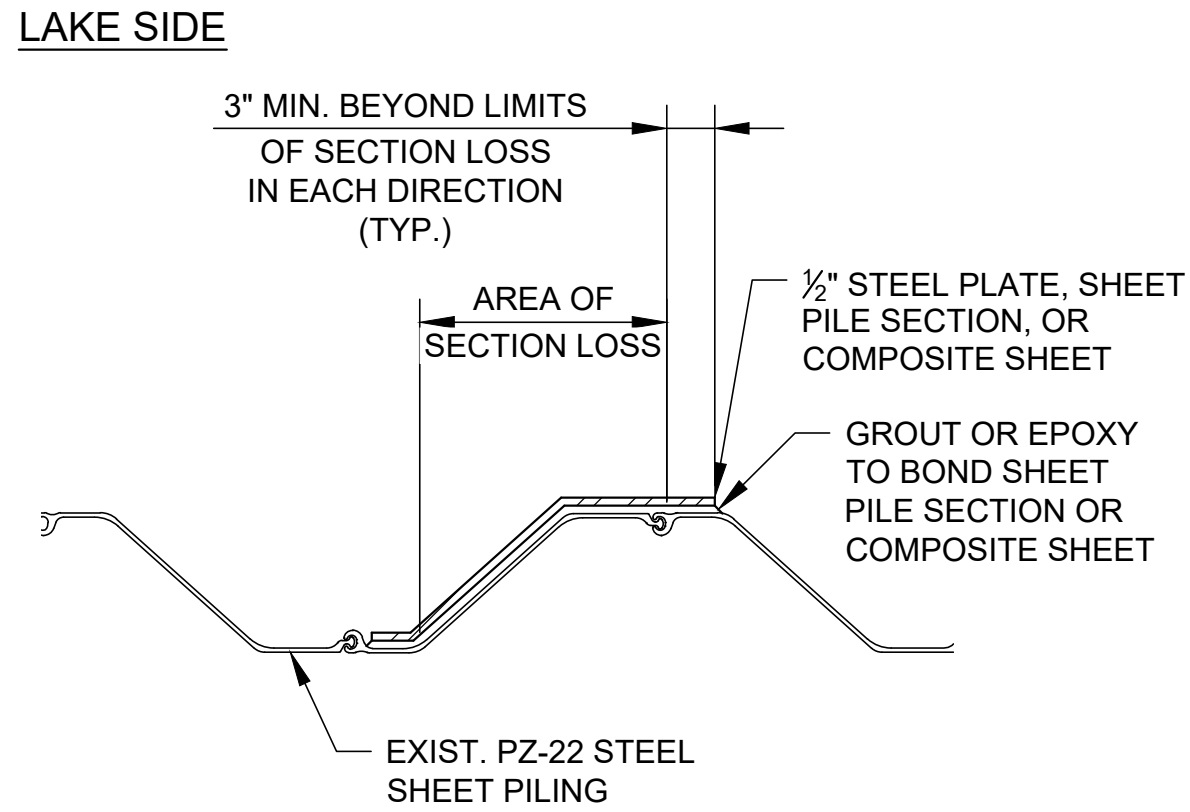
ENGINEERING

1-8-2025



1/7/2025


P:\NO.24.XXX\NO.24-007 OLD MANDEVILLE SEAWALL REPAIR SEGMENT 102\_DESIGN\02 CIVIL\01 DRAWINGS\14\_REPAIR DETAILS\_07



LAND SIDE

PLAN

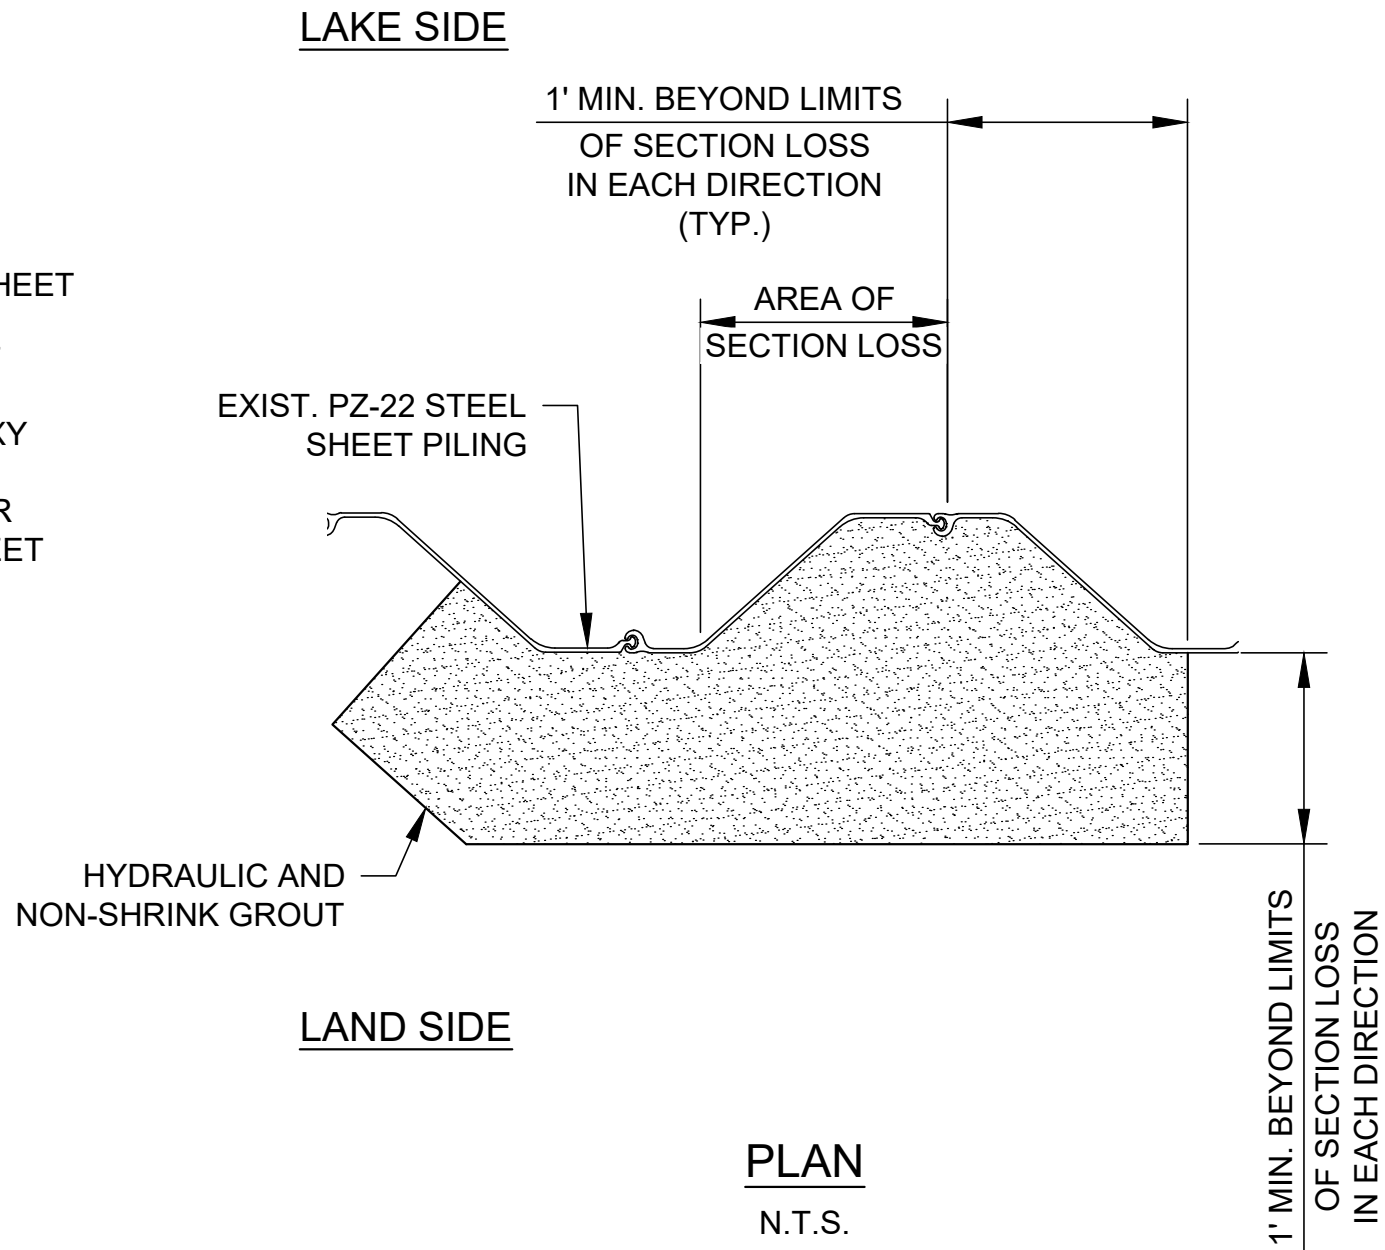
N.T.S.



LAND SIDE

PLAN

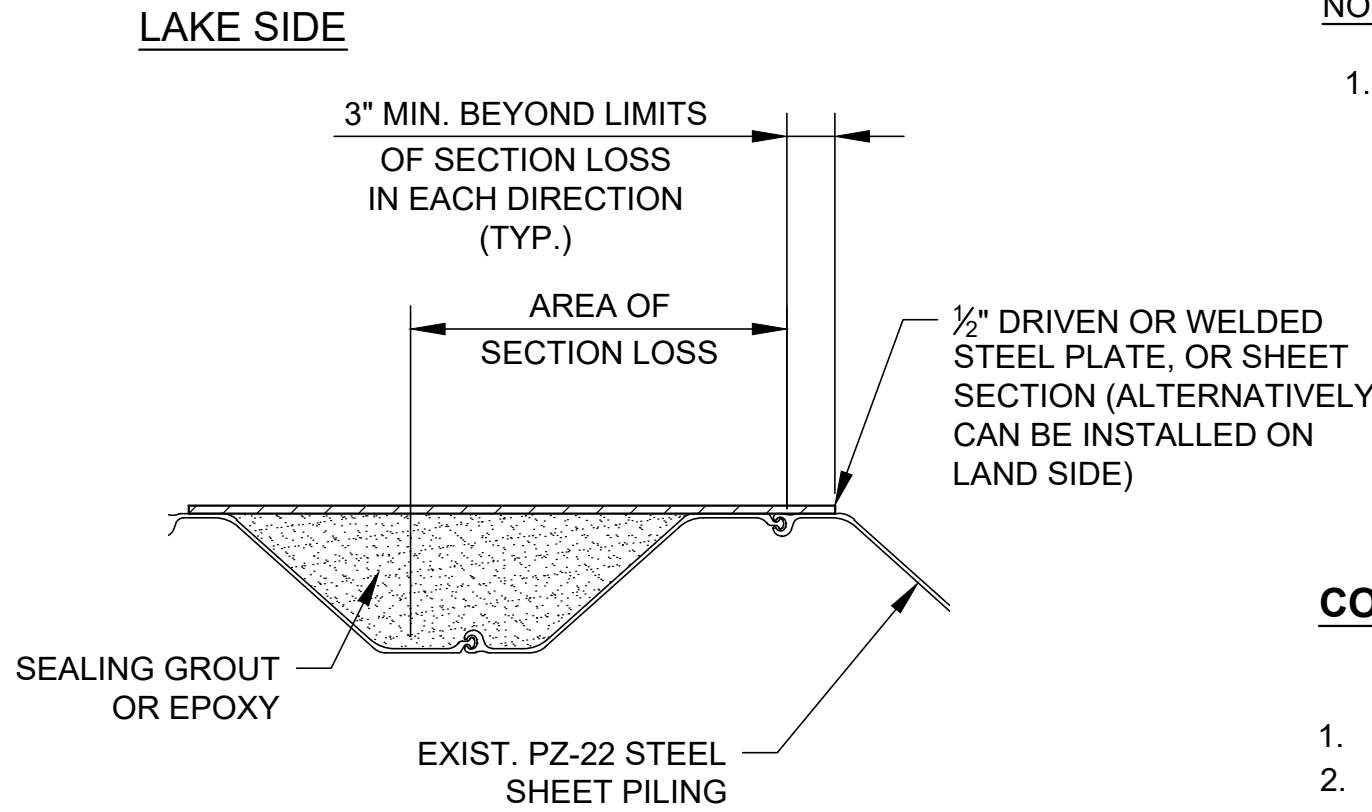N.T.S.



LAND SIDE

PLAN

N.T.S.

NOTE:

1. IN LATE 2022 AND EARLY 2023, THE CITY OF MANDEVILLE PERFORMED AN INSPECTION OF THE SEAWALL. THE ADJACENT TABLE IS A RESULT OF THE INSPECTION. THE CITY OF MANDEVILLE DOES NOT GUARANTEE THE CONDITIONS ARE THE SAME AT THIS DATE. THIS INFORMATION IS PROVIDED TO THE CONTRACTOR AS AN INDICATION OF THE TYPE AND AMOUNT OF REPAIRS THAT WERE PRESENT ON THAT DATE. THE TYPE AND AMOUNT OF REPAIRS IS SUBJECT TO CHANGE PER EXISTING FIELD CONDITIONS.

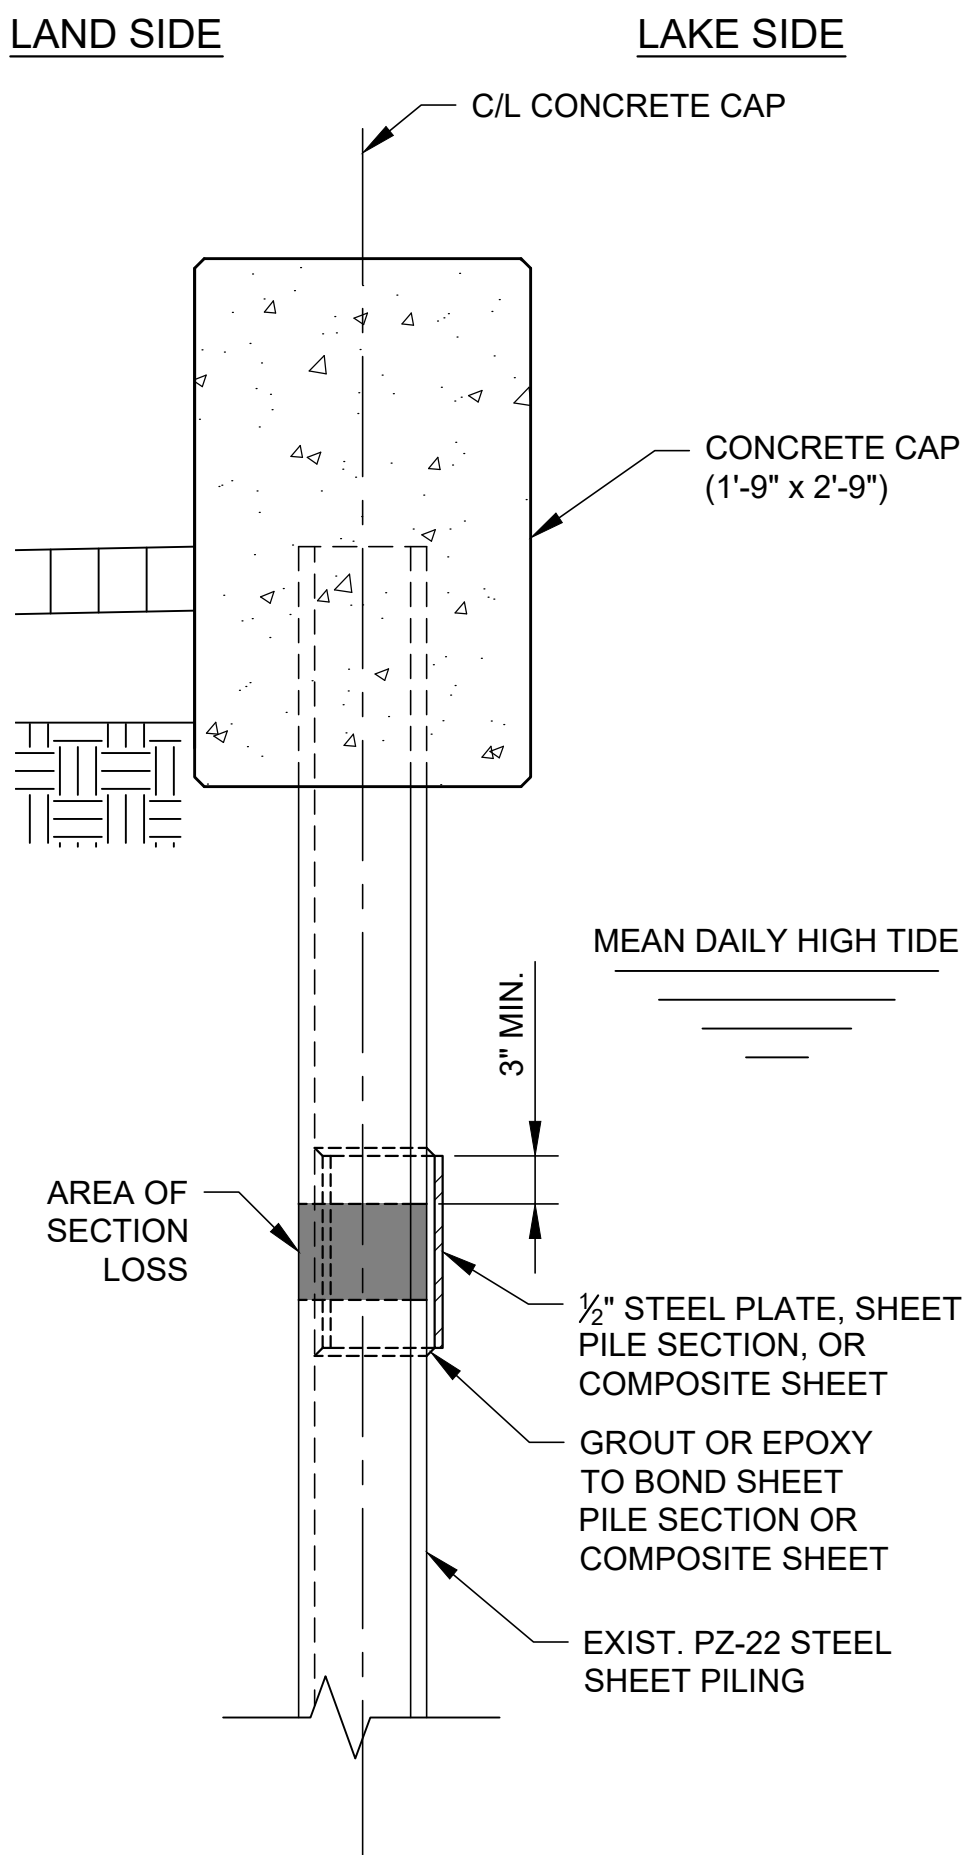
CONSTRUCTION SEQUENCE NOTES:

SHEET PILE SECTION LOSS > 25% AND < 50% BELOW WATER:

1. INSTALL SHEET PILE SECTION (OR STEEL PLATE OR COMPOSITE SHEET) IN FRONT OF DETERIORATED SECTION.
2. FILL THE CAVITY UTILIZING SPECIALTY GROUT OR EPOXY TO STRUCTURALLY BOND THE TWO SECTIONS.
3. SECTION CAN BE EXTENDED TO INCLUDE THE DETERIORATED SECTION AREAS ABOVE THE WATER LINE.
4. WELDED STEEL SECTIONS MAY BE UTILIZED IN LIEU OF BONDED SECTIONS.


SHEET PILE SECTION LOSS > 50% WITH BACKFILL EROSION BELOW WATERLINE:

1. IF SECTION DETERIORATION IS CONFINED INTO SMALL PATCHES, PATCH THE AREA BY INJECTING HYDRAULIC AND NON - SHRINKING GROUT CEMENT BEHIND THE WALL TO SEAL THE OPENING IN SHEET PILING AND BACKFILL AS NEEDED.
2. IF SECTION DETERIORATION EXTENDS OVER A LARGE SECTION OF THE WALL WITH NOTED LARGE WALL VOIDS, THEN BRIDGE THE DETERIORATED SECTION UTILIZING DRIVEN OR WELDED STEEL PLATES OR SHEET SECTION PLACED IN FRONT OR BEHIND THE EXISTING SHEET PILING. WATER - PROOF THE REPAIR AREA BY INJECTING SEALING GROUT OR EPOXY INTO THE REPAIR CAVITY AND BACKFILL AS NEEDED.




SHEET PILE SECTION LOSS > 25% & < 50%

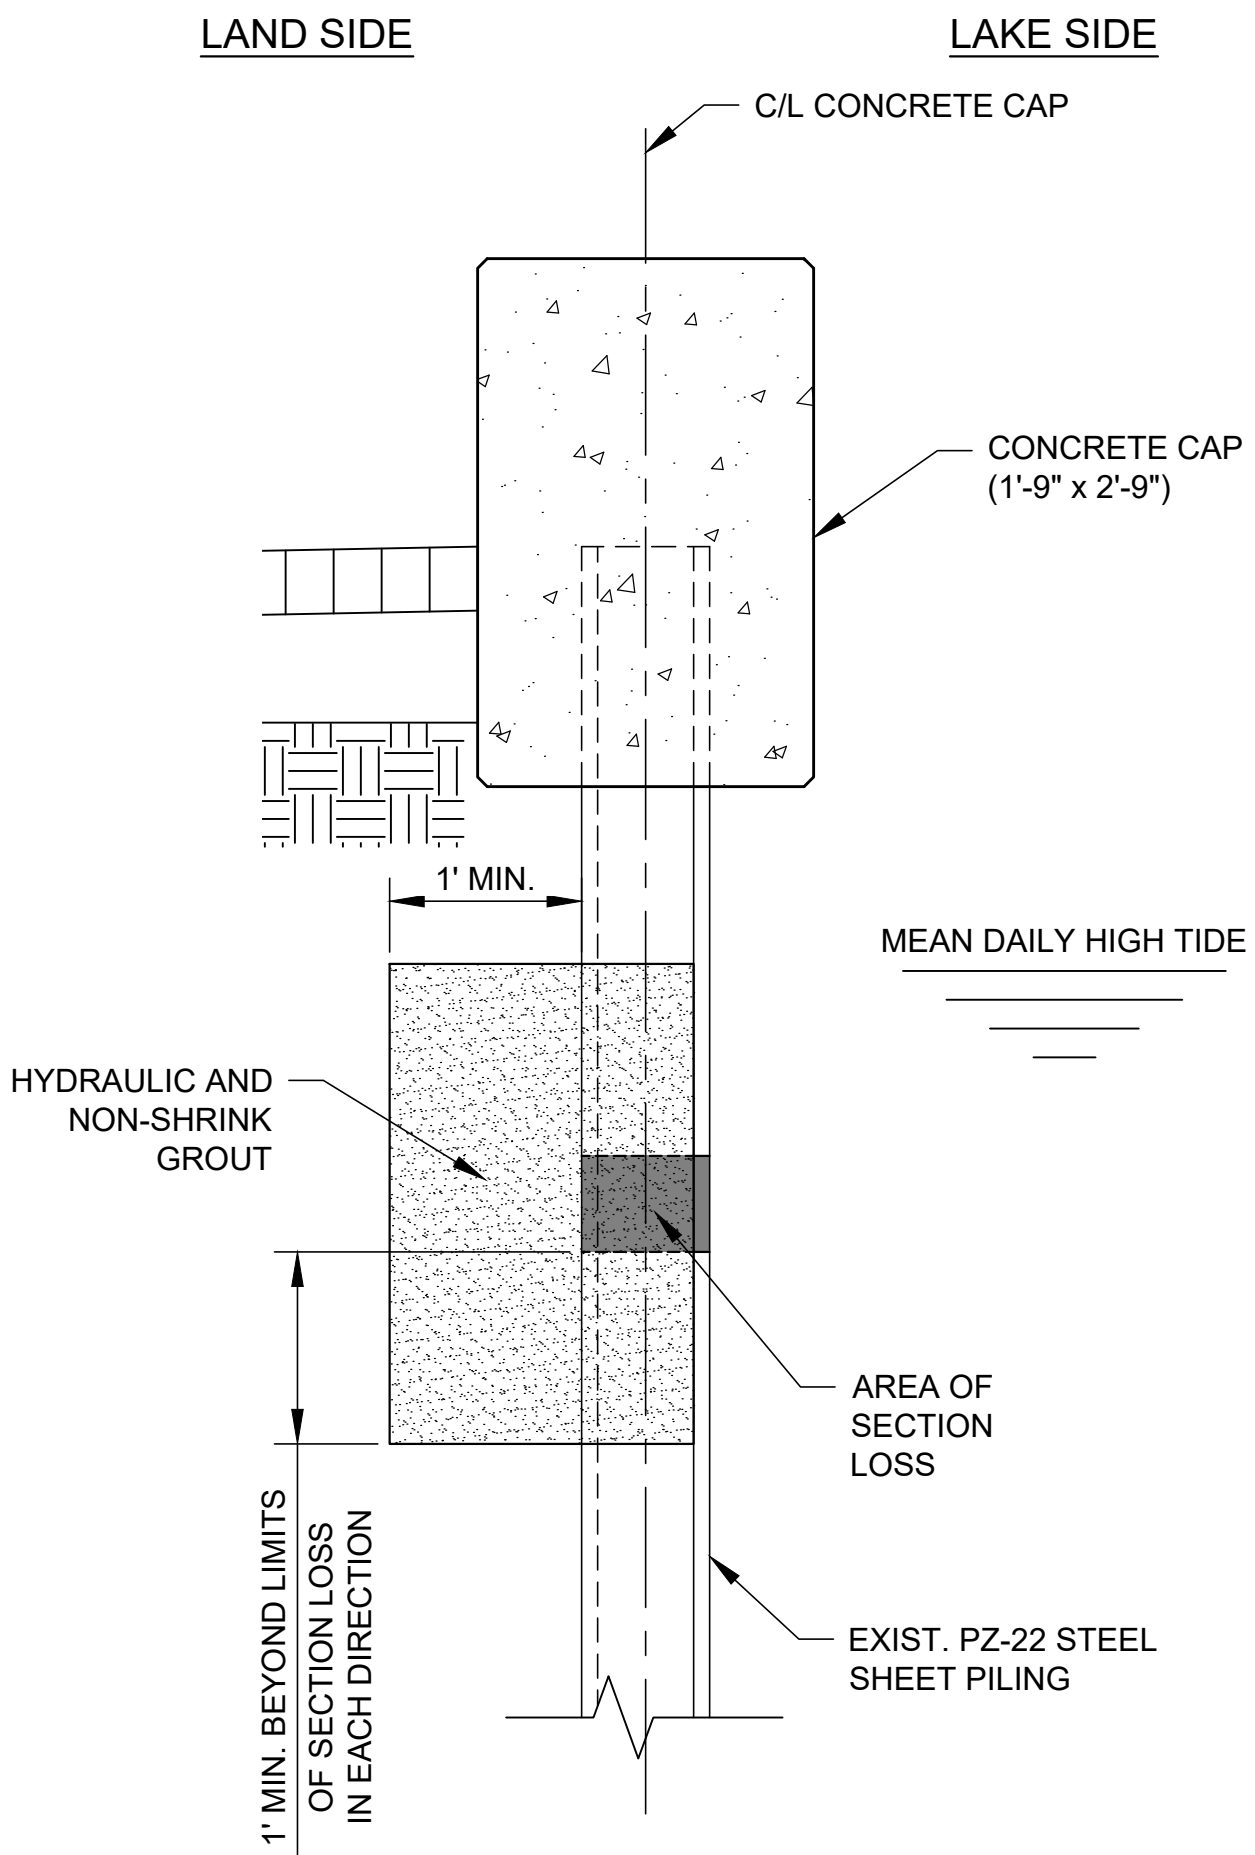N.T.S.



SHEET PILE SECTION LOSS > 50%  
SMALL PATCHES

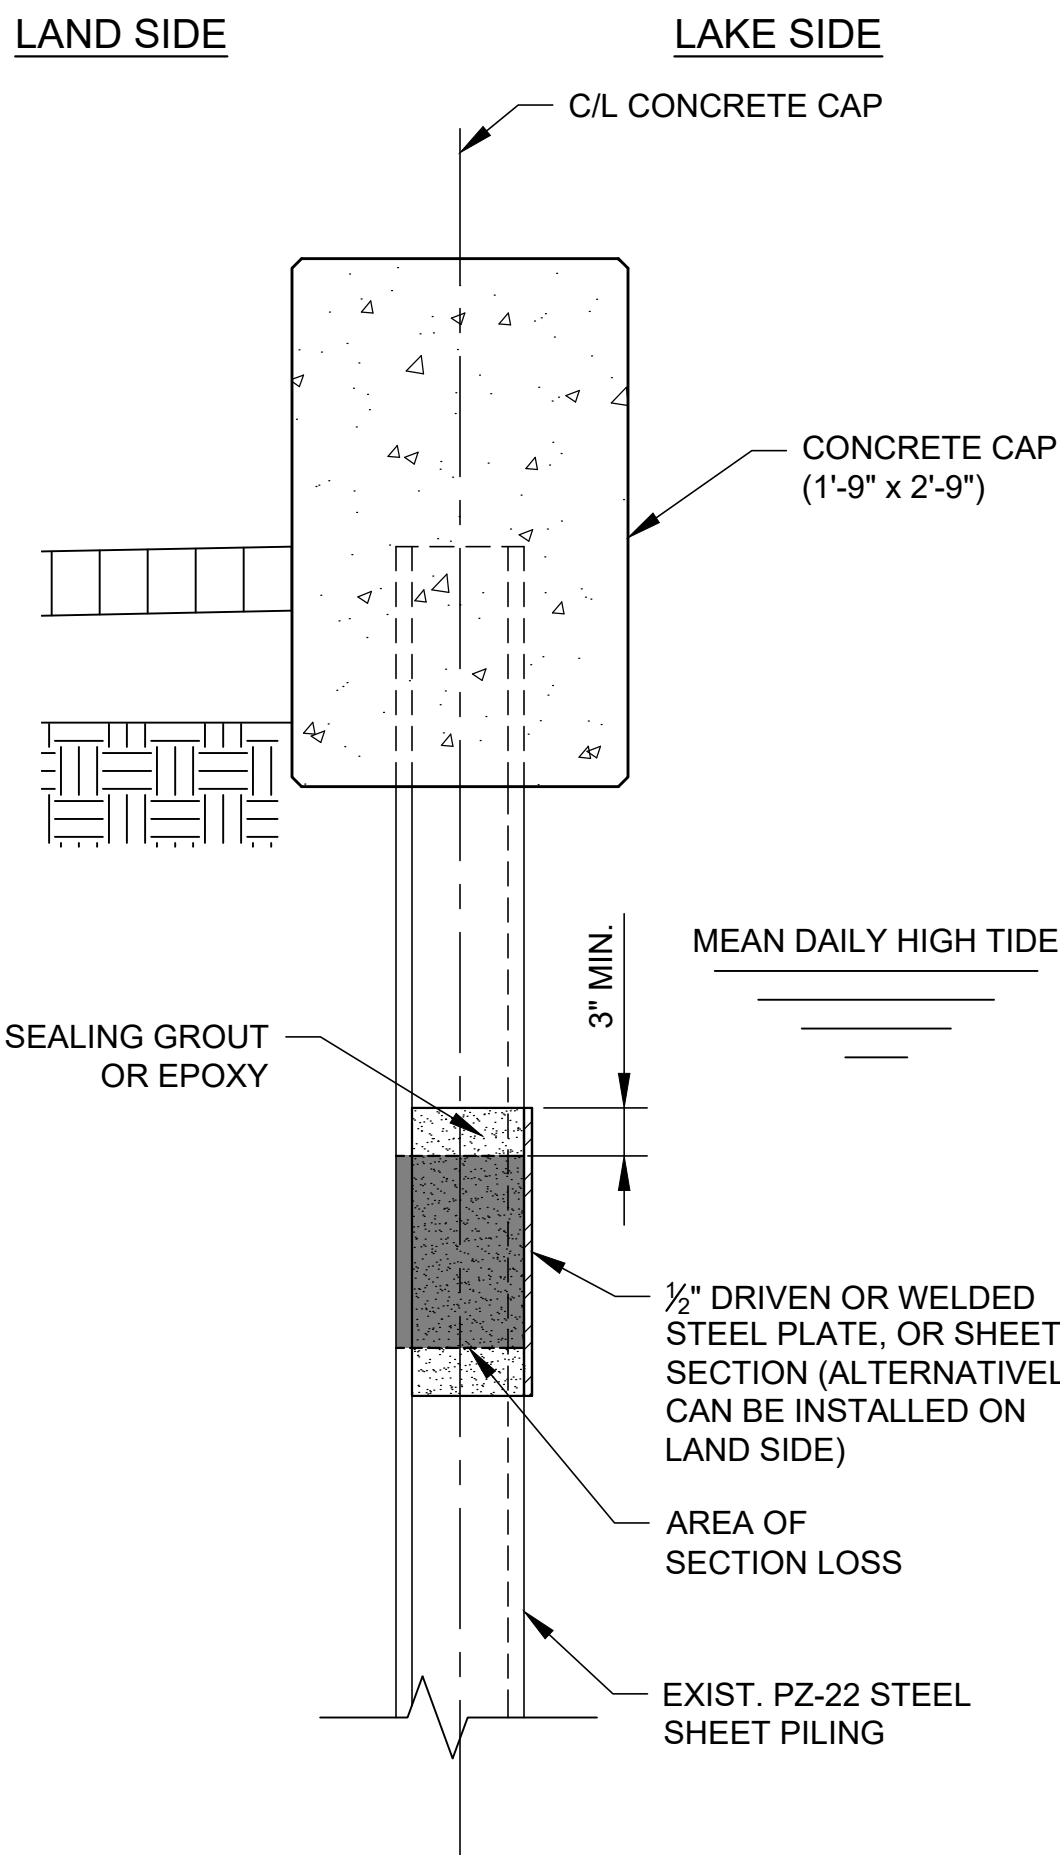N.T.S.



SHEET PILE SECTION LOSS > 50%  
LARGE WALL VOIDS



N.T.S.

| REPAIR TYPE E |                                      |                    |                                |                                     |
|---------------|--------------------------------------|--------------------|--------------------------------|-------------------------------------|
| APPROX. STA.  | APPROX. SIZE OF DETERIORATED SECTION | LOCATION           | LOCATION RELATIVE TO WATERLINE | LOCATION RELATIVE TO NATURAL BOTTOM |
| 46+00.00      | 3'-0" X 0'-8"                        | SHEET PILE WALL    | BELOW                          | AT                                  |
| 54+70.00      | 0'-7" X 0'-7"                        | LEFT OF BREAKWALL  | BELOW                          | ABOVE                               |
| 54+70.00      | 0'-9" X 0'-8"                        | RIGHT OF BREAKWALL | BELOW                          | ABOVE                               |
| 57+83.00      | 0'-9" X 0'-4"                        | NEAR DRAIN PIPE    | BELOW                          | ABOVE                               |
| 57+83.00      | 0'-4" X 0'-4"                        | NEAR DRAIN PIPE    | BELOW                          | ABOVE                               |
| 57+83.00      | 1'-2" X 0'-4"                        | NEAR DRAIN PIPE    | BELOW                          | ABOVE                               |
| 64+79.00      | 1'-3" X 0'-8"                        | BEHIND BREAKWALL   | BELOW                          | BELOW                               |
| 69+07.00      | 0'-8" X 0'-3"                        | SHEET PILE WALL    | BELOW                          | AT                                  |

QUANTITIES REFLECT SURVEY CONDITIONS AS OF DECEMBER 2022 AND JANUARY 2023 FOR REFERENCE ONLY

STEEL COATING NOTES:

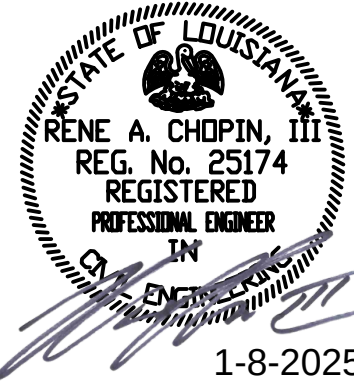 1. ALL STEEL REPAIRS WELDED OR DRIVEN, ABOVE OR BELOW WATER, SHALL BE COATED WITH COAL-TAR EPOXY.
2. IF THE REPAIR IS TO BE WELDED, THE EDGES SHALL BE COAL-TAR EPOXY COATING FREE.
3. AFTER WELDING, ALL EXPOSED STEEL AND WELDING MATERIAL SHALL BE COATED USING A SPLASH ZONE EPOXY MATERIAL.
4. ALL COATING MATERIALS SHALL BE PLACED PER THE MANUFACTURERS SPECIFICATIONS.
5. STEEL COATINGS FOR REPAIR TYPE E SHALL BE PAID FOR UNDER "STEEL REPAIR TYPE E."



14  
SHEET NUMBER

BY

REVISION DESCRIPTION

DATE

NO.

BKIBURK-KLEINPETER, INC.

ENGINEERING

PLANNING

ENVIRONMENTAL

COM PROJ. NO. 100.21.019

BK# : NO.24-007

DESIGNED  
CHECKED  
RACIII

DETAILED  
CHECKED  
SG

DATE  
JANUARY, 2025

SHEET  
1 OF 1



MANDEVILLE SEAWALL REPAIRS PROJECT

SEGMENT 1

REPAIR DETAILS TYPE E

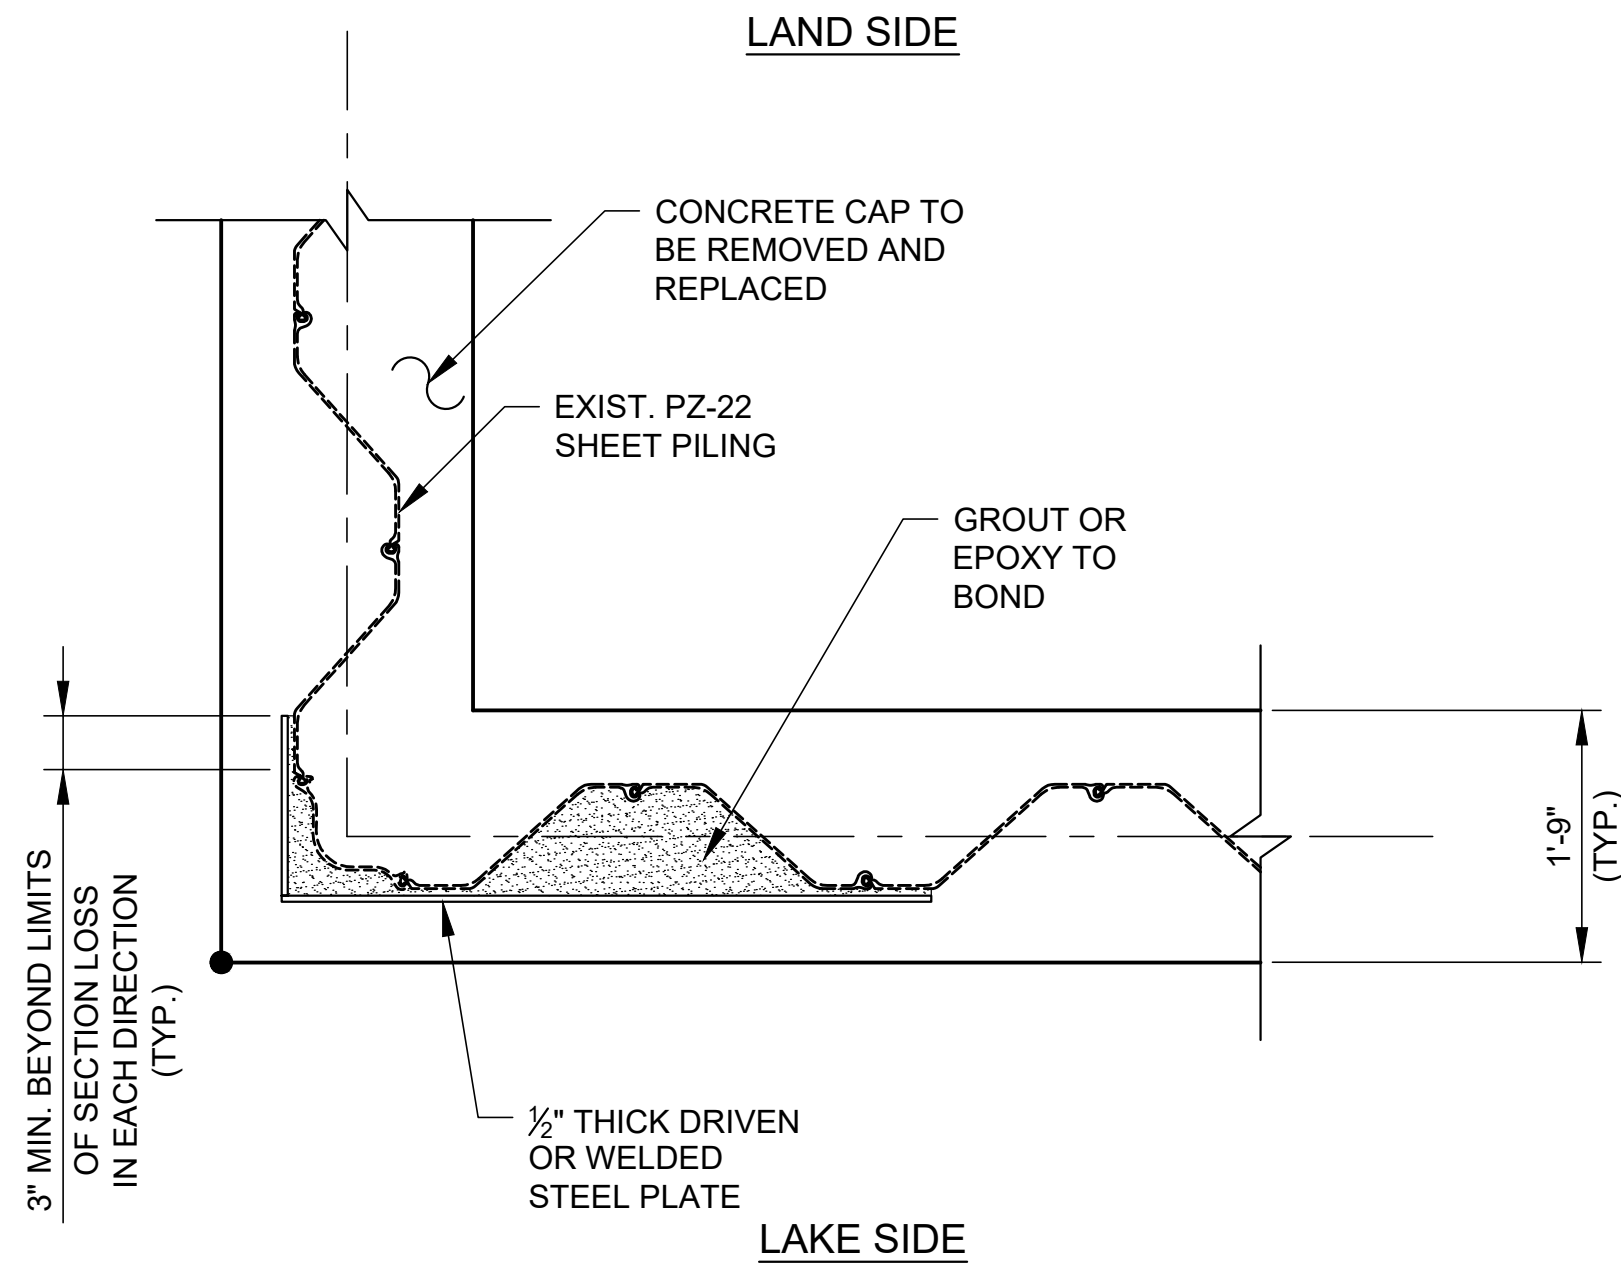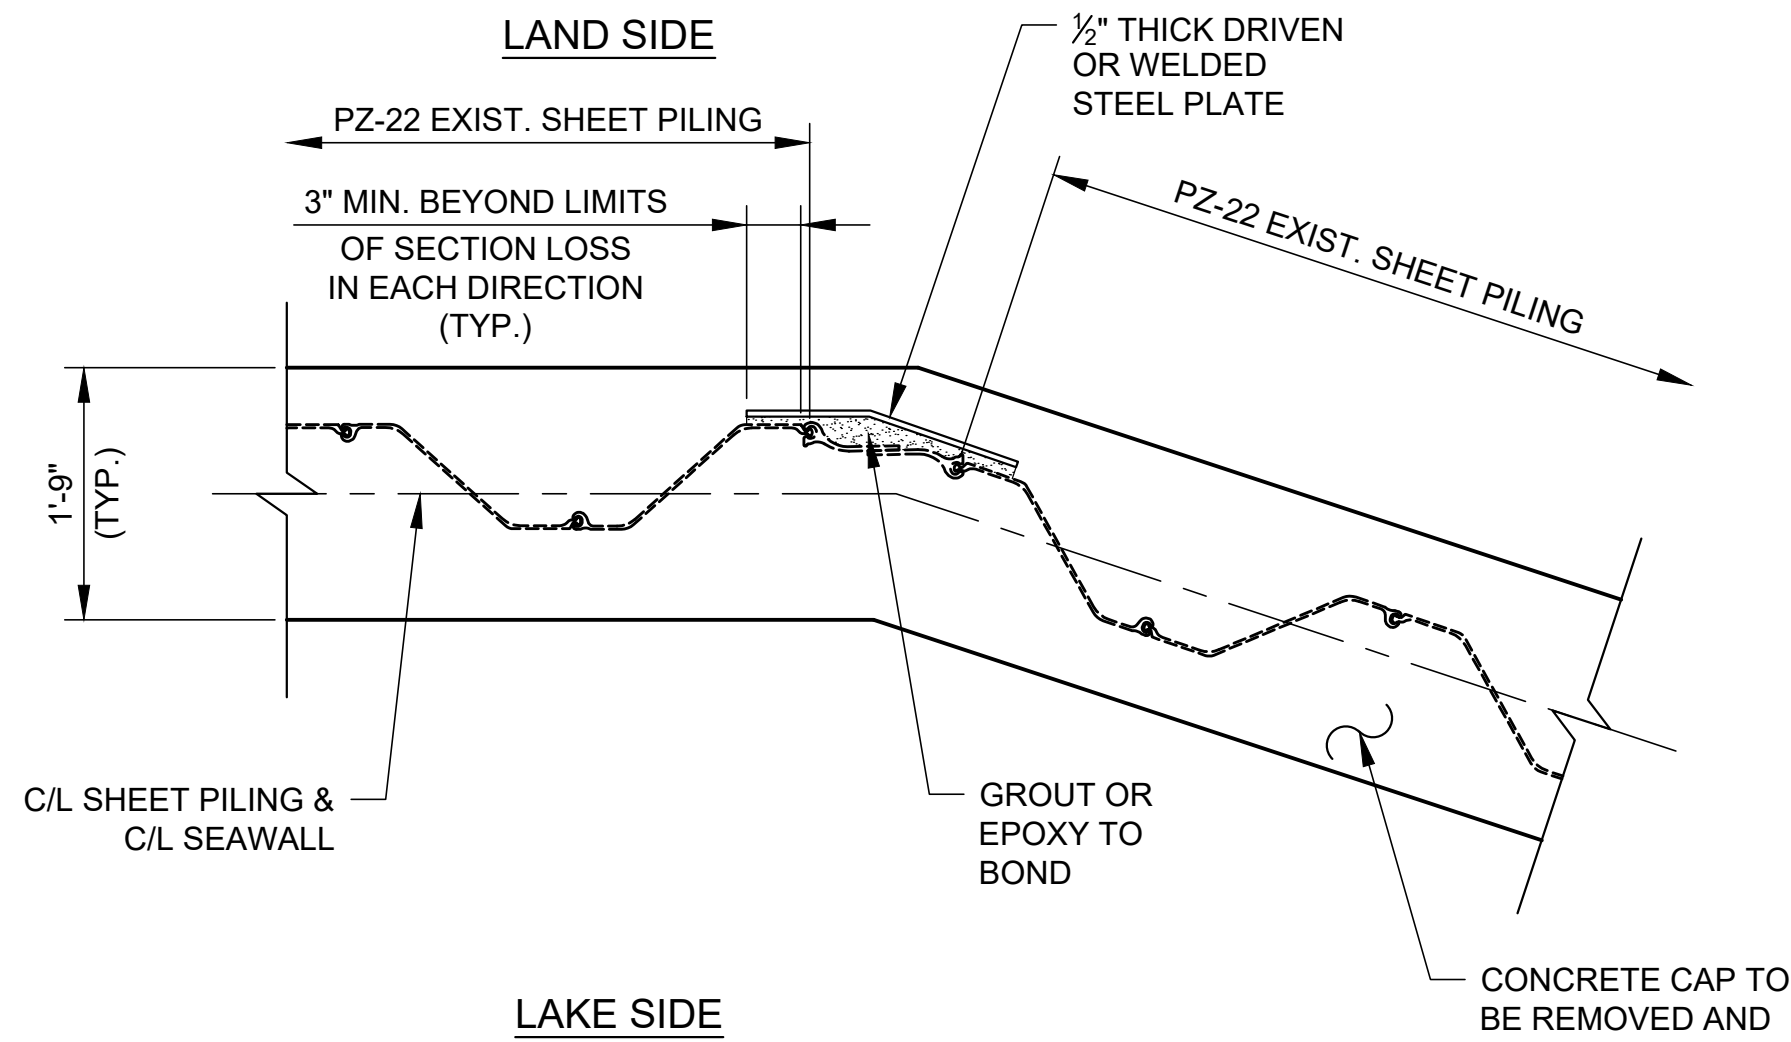(SHEET PILE AT SECTION LOSS)





TYPICAL SHEET PILING REPAIR TYPE F  
AT POINTS OF INTERSECTION

N.T.S.

NOTE:

1. IN LATE 2022 AND EARLY 2023, THE CITY OF MANDEVILLE PERFORMED AN INSPECTION OF THE SEAWALL. THE ADJACENT TABLE IS A RESULT OF THE INSPECTION. THE CITY OF MANDEVILLE DOES NOT GUARANTEE THE CONDITIONS ARE THE SAME AT THIS DATE. THIS INFORMATION IS PROVIDED TO THE CONTRACTOR AS AN INDICATION OF THE TYPE AND AMOUNT OF REPAIRS THAT WERE PRESENT ON THAT DATE. THE TYPE AND AMOUNT OF REPAIRS IS SUBJECT TO CHANGE PER EXISTING FIELD CONDITIONS.

CONSTRUCTION SEQUENCE NOTES:


1. REMOVE EXISTING CONCRETE CAP.
2. BRIDGE THE DETERIORATED SHEET PILE JOINT UTILIZING DRIVEN OR WELDED STEEL PLATES OR SHEET SECTION PLACED IN FRONT OF THE EXISTING SHEET PILING.
3. WATER PROOF AND STRUCTURALLY BOND THE THE REPAIR AREA BY INJECTING SEALING GROUT OR EPOXY PER THE MANUFACTURER INTO THE REPAIR CAVITY.

STEEL COATING NOTES:

1. ALL STEEL REPAIRS WELDED OR DRIVEN, ABOVE OR BELOW WATER, SHALL BE COATED WITH COAL-TAR EPOXY.
2. IF THE REPAIR IS TO BE WELDED, THE EDGES SHALL BE COAL-TAR EPOXY COATING FREE.
3. AFTER WELDING, ALL EXPOSED STEEL AND WELDING MATERIAL SHALL BE COATED USING A SPLASH ZONE EPOXY MATERIAL.
4. ALL COATING MATERIALS SHALL BE PLACED PER THE MANUFACTURERS SPECIFICATIONS.
5. STEEL COATINGS FOR REPAIR TYPE F SHALL BE PAID FOR UNDER "STEEL REPAIR TYPE F."

| REPAIR TYPE F |          |
|---------------|----------|
| APPROX. STA.  | LOCATION |
| 42+10.35      | W/L PI   |
| 42+15.19      | W/L PI   |
| 45+95.11      | W/L PI   |
| 46+00.71      | W/L PI   |
| 67+22.12      | W/L PI   |
| 67+26.76      | W/L PI   |
| 69+07.85      | W/L PI   |
| 69+12.98      | W/L PI   |
| 81+86.37      | W/L PI   |
| 81+90.38      | W/L PI   |
| 82+37.79      | W/L PI   |
| 82+41.80      | W/L PI   |

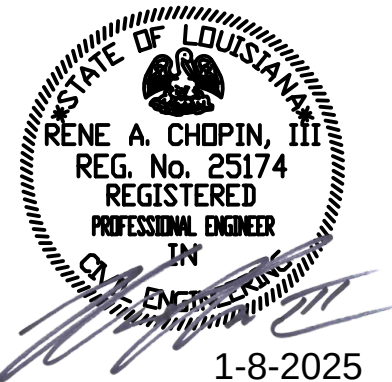QUANTITIES REFLECT  
SURVEY CONDITIONS AS OF DECEMBER 2022  
AND JANUARY 2023  
FOR REFERENCE ONLY



15  
SHEET NUMBER

BY  
DATE  
NO.

REVISION DESCRIPTION

**BKJ** BURK-KLEINPETER, INC.  
ENGINEERING PLANNING ENVIRONMENTAL  
BKJUSA.COM

COM PROJ. NO. 100.21.019  
BKJ # : NO.24.007

DESIGNED  
CHECKED  
R/C  
RACIII

DETAILED  
CHECKED  
SG  
R/C

DATE  
SHEET  
January, 2025  
1 of 1

MANDEVILLE SEAWALL REPAIRS PROJECT  
SEGMENT 1  
REPAIR DETAILS TYPE F  
(CONCRETE BULKHEAD)

1-8-2025



BILL OF MATERIALS

CATHODIC PROTECTION SYSTEM SCOPE & SUMMARY

| Anode Assemblies                    |                                                                                                                                                                                                                                                                                                                                                                   |      |      | Exothermic Welding for Cable Connections to Structure    |                                                                                                                                                                                                                                                                                                                                                           |      |     |
|-------------------------------------|-------------------------------------------------------------------------------------------------------------------------------------------------------------------------------------------------------------------------------------------------------------------------------------------------------------------------------------------------------------------|------|------|----------------------------------------------------------|-----------------------------------------------------------------------------------------------------------------------------------------------------------------------------------------------------------------------------------------------------------------------------------------------------------------------------------------------------------|------|-----|
| No.                                 | DESCRIPTION                                                                                                                                                                                                                                                                                                                                                       | UNIT | QTY  |                                                          |                                                                                                                                                                                                                                                                                                                                                           |      |     |
| 1                                   | Water Side Anode – Zinc alloy ASTM B418 Type I for seawater service; nominally 2” square cross section x 48” ingot length; 50 pounds of zinc; flat bar core protruding minimum 6” from each end, bent for surface welding; 1/4” minimum bar core thickness.                                                                                                       | EACH | 566  | 19                                                       | Exothermic Weld Mold: No. 14 to No. 10 solid, CAHAA–10 welder for horizontal pipe 4” diameter to flat surfaces. Must use copper for sleeve CAB–133–1K for attaching No. 10 stranded wire.                                                                                                                                                                 | EACH | 1   |
| 2                                   | Soil Side Packaged Anode – High potential magnesium alloy ASTM B843 Type M1C; nominal 2.75” x 3” cross section x 59.75” ingot length; 20 pounds of zinc; packaged in prepared backfill; nominally 5” diameter x 66” length; manufacturer connected lead wire No. 12 AWG solid copper with black type TW insulation 10 feet in length                              | EACH | 494  | 20                                                       | Exothermic Weld Charge: 15–gram weld charge for model CA15, 20 cartridges per box or equal                                                                                                                                                                                                                                                                | BOX  | 2   |
| 3                                   | Test Anode for Water Side – Zinc alloy ASTM B418 Type I for seawater service; nominally 2” square cross section x 48” ingot length; 50 pounds of zinc; including a factory connected No. 8AWG cable with a Halar/HMWPE dual extrusion black insulation, 50 feet in length.                                                                                        | EACH | 8    | 21                                                       | Flint Igniter for exothermic welder: model CAT320                                                                                                                                                                                                                                                                                                         | EACH | 2   |
| 4                                   | Mounting Assembly for Test Anodes – carbon steel eye–ring with PVC pipe liner. Two required per anode; field fabricated.                                                                                                                                                                                                                                          |      |      | Splicing                                                 |                                                                                                                                                                                                                                                                                                                                                           |      |     |
|                                     |                                                                                                                                                                                                                                                                                                                                                                   |      |      | 22                                                       | Part 1: Fill Putty: insulating putty fill; 3M Scotchfil 1 1/2” x 60” roll or equal                                                                                                                                                                                                                                                                        | ROLL | 50  |
|                                     |                                                                                                                                                                                                                                                                                                                                                                   |      |      | 23                                                       | Part 2: Rubber Splicing Tape: linerless rubber tape, self–bonding rated through 69kV, 3/4” wide x 30 ft roll, black. 3M model 130C                                                                                                                                                                                                                        | ROLL | 20  |
|                                     |                                                                                                                                                                                                                                                                                                                                                                   |      |      | 24                                                       | Part 3: Vinyl Electrical Tape: 8.5–mil thick vinyl, all weather, UV resistant, 600 Volts rating, 3/4” wide x 66 feet roll, black. 3M model Super 88                                                                                                                                                                                                       | ROLL | 20  |
|                                     |                                                                                                                                                                                                                                                                                                                                                                   |      |      | 25                                                       | Crimp Connector: Compression crimp connector for No. 12AWG solid copper anode cable (tap) to No. 10AWG stranded copper header (run) cable; Burndy Crimpit model YC10C10 (for use with U–238 die in Burndy Y–35 tool)                                                                                                                                      | EACH | 494 |
|                                     |                                                                                                                                                                                                                                                                                                                                                                   |      |      | 26                                                       | Barrel Crimp: Compression–type barrel crimp for inline connection of cables, 0.64” minimum length; 14AWG to 20AWG cables; Burndy YSV14BOX small terminal, uninsulated seamless compression butt splice or equal                                                                                                                                           | EACH | 20  |
|                                     |                                                                                                                                                                                                                                                                                                                                                                   |      |      | 27                                                       | Barrel Crimp: Compression–type barrel crimp for inline connection of cables, 0.64” minimum length; 12AWG to 10AWG cables; Burndy YSV10BBOX small terminal, uninsulated seamless compression butt splice or equal                                                                                                                                          | EACH | 20  |
| Test Stations & Monitoring Assembly |                                                                                                                                                                                                                                                                                                                                                                   |      |      | Conduit & Hardware Schedule for Water Side Test Assembly |                                                                                                                                                                                                                                                                                                                                                           |      |     |
| 5                                   | Flush Grade Test Station: nominally 20 3/4” x 19 1/4” x 12” reinforced concrete enclosure with concrete cover; rated for pedestrian traffic; friction compliance 0.6 ASTM 1028; custom marking ”CATHODIC PROTECTION TEST”; Oldcastle Christy model B24BOX with model B24D concrete lid or equal.                                                                  | EACH | 9    | 28                                                       | Mounting Bolt: 1/2”UNC–13 x 4 1/2” hex head cap screw; partial thread min. 1 1/4” length; 316 stainless steel                                                                                                                                                                                                                                             | EACH | 20  |
| 6                                   | Secondary Test Station Enclosure: nominally 14” x 12” x 6” FRP NEMA 6P enclosure with hinged locking cover; panel size nominally 12 1/4” x 10 1/4” non–metallic with approx. 2” stand–offs to accommodate all cables connections behind panel; Stahlin model J1412HPL or equal. All entrance fittings must be rated and installed for NEMA 6P (submersion rated). |      | 9    | 29                                                       | Lock Nut for Mounting Bolt: 1/2”UNC–13 hex nut; 316 stainless steel                                                                                                                                                                                                                                                                                       | EACH | 20  |
| 7                                   | Reference electrode & Coupon, <u>COPPER for SOIL SIDE</u> : copper–copper sulfate stationary device (body color code is yellow) with 10 square centimeter carbon steel coupon and 50 feet of No. 16–3 conductor tray cable wire; RHH–RHW black outer jacket; copper stranded wire. 30–Year life. Model Stelth 7 SRE–023–ND or equal.                              | EACH | 10   | 30                                                       | Beam Clamp: perpendicular mounting for standard 1 1/4” conduit size                                                                                                                                                                                                                                                                                       | EACH | 20  |
| 8                                   | Reference electrode & Coupon, <u>SILVER for WATER SIDE</u> : silver–silver chloride stationary device (body color code is blue) with 10 square centimeter carbon steel coupon and 50 feet of No. 16–3 conductor tray cable wire; RHH–RHW black outer jacket; copper stranded wire. 30–Year life. Model Stelth 7 SRE–026–ND or equal.                              | EACH | 8    | 31                                                       | LB Access Port: 90 fitting with push–in female connectors for 1 1/4” PVC conduit                                                                                                                                                                                                                                                                          | EACH | 10  |
| 9                                   | Ring terminal, No. 10 stranded cable: Burndy YAV10T3Box, for 1/4” stud                                                                                                                                                                                                                                                                                            | BOX  | 2    | 32                                                       | Male Adapter: male threaded fitting with push–in female connector for 1 1/4” PVC conduit                                                                                                                                                                                                                                                                  | EACH | 20  |
| 10                                  | Ring terminal, No. 16 stranded cable: Burndy YAV14T2Box for 1/4” stud                                                                                                                                                                                                                                                                                             | BOX  | 2    | 33                                                       | Bushing–Grommet: 1 1/4” NPSM female for medium– and thick–wall metal conduit                                                                                                                                                                                                                                                                              | EACH | 20  |
| 11                                  | Banana Plug: set screw type with plug & jack, black plastic insulation; McMaster–Carr item 6933K53                                                                                                                                                                                                                                                                | EACH | 20   | 34                                                       | Conduit: 1 1/4” Schedule 80 PVC sunlight resistant conduit                                                                                                                                                                                                                                                                                                | FEET | 100 |
| 12                                  | Test Lead Wire: No. 18 AWG stranded with black EPDM rubber insulation; McMaster–Carr item 7058K32                                                                                                                                                                                                                                                                 | FEET | 32   |                                                          | Platt part No. 0069137 or equal                                                                                                                                                                                                                                                                                                                           |      |     |
| Structure & Test Cables             |                                                                                                                                                                                                                                                                                                                                                                   |      |      | Remote Monitoring System                                 |                                                                                                                                                                                                                                                                                                                                                           |      |     |
| 13                                  | Structure Cables: No. 10AWG THHN/THWN–2 black insulation, stranded, soft–drawn, commercially pure copper, ASTM B8, Class B standard. Used for both soil side anode connections & test leads for soil and water side devices monitoring devices.                                                                                                                   | FEET | 750  | 35                                                       | Monitor/Transmitter Device: Integrated multimeter and transmitter designed for cathodic protection monitoring; traffic rated, sealed, and designed for below grade installation; maximum operating temperature not less that 140°F; battery life minimum 10 years; cellular or satellite communication capable. MOBILTEX CorTalk model RMU1–SUB or equal. | EACH | 2   |
| 14                                  | Land–Side Anode Header Cables: No. 10AWG THHN/THWN–2 red insulation, stranded, soft–drawn, commercially pure copper, ASTM B8, Class B standard                                                                                                                                                                                                                    | FEET | 9000 | 36                                                       | Valve Box Cover: White HDPE, AASHTO HS20 cover; MOBILTEX model H23390SUB02 or equal                                                                                                                                                                                                                                                                       | EACH | 2   |
| 15                                  | Caution Tape, ”CATHODIC PROTECTION CABLES BURIED BELOW” for protection of buried conductors where required, 3–inch width, non–metallic, 1000 feet per roll                                                                                                                                                                                                        | ROLL | 5    | 37                                                       | Programmer Kit: Universal programming kit for RMU1, RMU2, and RMU3 devices. Includes RMU1/2/3 base programmer (A1506033101), RMU1ADP (A1506033001), Lilon battery pack, soft case and USB stick with programming software; Bluetooth capable for phone, table or PC; MOBILTEX model RMU1/2/3–BT part No. A20A0333101                                      | EACH | 1   |
| Cable Connections to Structure      |                                                                                                                                                                                                                                                                                                                                                                   |      |      | 38                                                       | Communications Subscription: service and account established monitor and store data, and maintain website. Account exists between Owner and MOBILTEX.                                                                                                                                                                                                     | EACH | 2   |
| 16                                  | Heat shrink sleeve, heavy wall with adhesive lining for No. 10 THHN/THWN–2 cable, manufactured by 3M or approved equal. Manufacturer model number ITCSN–0400–BLACK. Use 2 inches minimum per cable connection.                                                                                                                                                    | FEET | 20   |                                                          |                                                                                                                                                                                                                                                                                                                                                           |      |     |
| 17                                  | Heat shrink sleeve, heavy wall with adhesive lining for No. 6 cable, manufactured by 3M or approved equal. Manufacturer model ITCSN–1500–BLACK. Use 2 inches minimum per cable connection.                                                                                                                                                                        | FEET | 2    |                                                          |                                                                                                                                                                                                                                                                                                                                                           |      |     |
| 18                                  | Exothermic Weld Cover: field–applied, prefabricated cover with elastomeric adhesive, plastic dome cover and integrated primer; 4–inch square shape. Model Handi Cap IP or Equal                                                                                                                                                                                   | EACH | 30   |                                                          |                                                                                                                                                                                                                                                                                                                                                           |      |     |

SYSTEM DESCRIPTION:

The cathodic protection system was designed to arrest corrosion of only those buried and submerged portions of the steel sheet pile wall subjected to high corrosion rates. The system uses an electrochemical circuit established between sacrificial magnesium and zinc anodes and the steel sheet pile structure. The system consists of buried and submerged sacrificial anodes, reference electrodes and coupons (testing & monitoring devices), cables, connections, testing enclosures and a remote monitoring system.

The remote monitoring system records operating data and reports output of the system and operating status via a web–based interface.

CONSTRUCTION NOTES

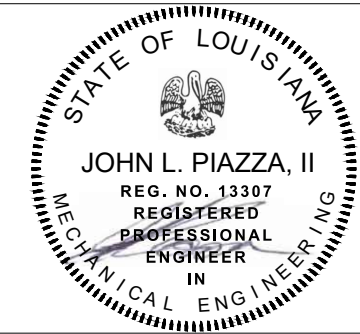
GENERAL CONSTRUCTION NOTES:

- In the event the requirements of this notes section conflicts with these plans or the specifications, notify the ENGINEER for determination of intent. The direction must be communicated in writing and made a part of the as–built record.
- Bill of material (BOM) quantities shown in the plans are minimum based on design. CONTRACTOR to verify actual quantity for installation. Contingency quantities and incidental materials were not included.
- Cable routes to be field verified prior to construction. Variation of length greater than 20% from specified must be approved by the ENGINEER in writing prior to construction.
- The cathodic protection system was designed based on information available. Construction variances may be necessary, but require written approval by the ENGINEER prior to execution. All variances shall be documented in the as–built records.
- Install above ground appurtenances generally where shown on the plans. Circumstances may require placement of such devices in locations better suited for property owners, protection of the enclosures and interference with adjacent equipment. All appurtenance relocations must be approved in writing by the ENGINEER prior to execution.
- Prior to any land–side excavation, utility locates are required in conformance with state, local and terminal call–before–digging laws and policies.

INSTALLATION:

- Water–Side Anode Installation
  - When lifting and handling the anodes, care must be taken to prevent damage. Anodes are subject to cracking if dropped or struck. Do not install cracked or significantly scroaped anodes.
  - Place anodes horizontally, as shown in the plans, with a maximum end to end spacing of 40 inches. Field adjustment may be required to accommodate changes of wall direction and fluctuating elevation of the bottom.
  - Install all anodes at a permanently–wet elevation, but above the mud line. Anodes do not function when exposed.
- Soil–Side Anode System
  - Care shall be taken to prevent anode lead damage. Do not lift the anodes by the cable.
  - The Contractor shall install the anodes in a horizontal position as shown on the drawings.
  - Remove paper shipping bag prior to anode installation.
  - When conducting the anode connection to the header cable, compress the copper crimp device with the manufacturer–specified tool and after completing the crimp pull the anode lead firmly to confirm the conductors were properly seated.
  - Center the packaged anode in the trench and backfill with clean soil materials in layers not exceeding 6”deep. Carefully tamp each layer to properly compact the backfill. When the backfill is level with the top of the anode, pour not less than five gallons of lake water onto each anode. The backfill material shall be completely saturated. Add additional backfilling material as necessary to compensate for soil shrinkage.
  - The anodes shall not be installed in gravel of any size.
  - Install anodes not closer than 2 feet to any foreign metallic structure, such as communications cables or metallic utilities. If such circumstances are unavoidable, notify the ENGINEER prior to installation and use dielectric shield material and methods in accordance with the plans. Include any such measures, location and extent of installed shielding in the as–built record.
  - Install all cables flat on the trench bottom without looping or kinks that cause the material to protrude from the bottom surface. Burial depth is critical for functionality – minimum 3 feet below finished grade.
  - Cover the anode trench with 6 to 12 inches with clean native backfill free of debris, rock and plant matter. Flood the trench with lake water to consolidate earth around the anode product and reduce circuit resistance. Allow the water to saturate the anodes and surrounding undisturbed earth before final trench backfilling.
- Structure Connections for Test Leads & Soil–Side Anode System
  - Read and observe all manufacturer instructions for safe and effective use of exothermic welding equipment and utilize all appropriate PPE.
  - Remove any structure coating and rust scale from an area of approximately 2–inch x 2–inch or smaller, as required. Clean area of steel for each

- connection, wire brush and file to obtain SA3 white metal surface preparation quality.
- After conducting and exothermic weld, test strength of connection by lightly tapping top of weld with one pound hammer.
- Remove all weld slag and splatter, sharp edges and burrs with metal file and wire brush.
- Wipe metal surface with clean, dry, oil free rags to remove any loose dust and ensure the surface is dry. Surface heating the metal substrate may be necessary prevent condensation of moisture.
- Install a section of high–shrink ratio heat shrink tubing not less than 2 inches in length for strain relief at the coating–cable interface.
- The welds shall be coated with a weld cover designed for the purpose. Install all products in strict accordance with the manufacturer’s instructions. Do not apply any coating repair product to moist surfaces (e.g., condensation, splash, rain, etc.) or surfaces below the application temperature of the weld cover product.
- Cables & Raceway
  - All conduit utilized shall be non–metallic, rated for sunlight exposure, and Schedule 80.
  - All metallic support hardware, strut channel and similar hardware shall be 316 stainless steel. Sections of strut channel shall be deburred for personnel protection.
  - Utilize clear primer and gray conduit adhesive for assembly to ensure aesthetic quality of the installations.
  - All land–side cables shall be buried in open–cut trenches to a depth not less than 3 feet from finished grade to the top of the shallowest cable in a cable run.
  - Backfill the first 12 inches of the cable trench with clean, rock and debris–free soil material.
  - Place non–metallic cable warning tape when backfilling all cable trenches. The product shall be marked ”Cathodic Protection Cable Buried Below” or similar, placed flat with the text facing up. Place the tape between 12 and 24 inches below finished grade.
- Splices
  - All unplanned splices must be approved by the ENGINEER prior to conducting the work. All splice locations shall be documented and made a part of the as–built record.
  - All splices shall be protected from moisture and electrically insulated for mechanical and corrosion protection.
  - Splices shall be conducted in accordance with the plans.
  - Cable end–to–end connections shall be made with a soldered–in–place mechanically–crimped copper connector, properly sized for the cable being spliced, utilizing a tool specified by the manufacturer for the crimp connector product utilized. Split bolts shall not be permitted for splicing.
  - All buried splices shall be buried with at least one full wire loop minimum 12 inches diameter containing the splice to reduce soil compaction tensile stresses exerted on the splices.
- Test Stations
  - Test station boxes shall be installed out of traffic ways near the locations shown, complete with silver/silver chloride reference electrodes and corrosion coupons, as specified. The final test station locations may be adjusted to accommodate field conditions.
- Coupons
  - Ensure all coupon surfaces are free of oil, protective films, etc. prior to installation.
- Reference Electrodes
  - The reference electrodes and coupons shall be backfilled with clean soil material and not separated greater than 6”. The coupon and reference cell should be installed not more than 3 inches from the wall without any direct contact. Carefully tamp to properly compact the backfill. When backfilling is complete pour not less than two gallons of water over the reference electrode. The backfill material shall be completely saturated with water. Add additional backfill material as necessary to compensate for soil shrinkage.
  - Reference electrodes and coupons shall not be installed closer than 4 feet from any anode.
- Test Lead & Cable Terminations
  - Lead wire connectors shall be installed using the proper crimping tools and in strict accordance with the manufacturer’s instructions.



Southern Cathodic Protection Company

ENGINEER: John L. Piazza, II  
LICENSE #: 0013307  
DATE: January 8, 2025



MANDEVILLE SEAWALL REPAIRS PROJECT

SEGMENT 1

CATHODIC PROTECTION – GENERAL NOTES & B.O.M.

IN ASSOCIATION WITH

**BKI** BURK KIEFER PETER, INC.  
CONSULTING, ENGINEERING, ARCHITECTURE, INTERIOR DESIGN, PROJECT MANAGEMENT, PROGRAM MANAGEMENT, SPECIALTY CONTRACTING  
2000 GOLF COURSE DRIVE, SUITE 100, FARMERS, MISSISSIPPI 39074  
601.733.1100

780 JOHNSON FERRY ROAD  
SUITE 225  
ATLANTA, GEORGIA 30342  
(404) 822-4444  
www.southerncathodic.com

**GOP** Southern Cathodic PROTECTION

|                     |              |
|---------------------|--------------|
| DESIGNED<br>CHECKED | CRM<br>TCH   |
| DETAILED<br>CHECKED | CRM<br>TCH   |
| DATE                | JANUARY 2025 |
| SHEET               | 1 OF 3       |




| 16<br>SHEET NUMBER |   |                         |                      |
|--------------------|---|-------------------------|----------------------|
|                    |   | CRM                     | BY                   |
|                    |   | Revised to final design |                      |
|                    | 2 | 8/23/24                 |                      |
|                    | 1 | 7/18/24                 |                      |
|                    |   | DATE                    | REVISION DESCRIPTION |
|                    |   | NO.                     |                      |


BK # : NO.24-007

COM PROJ. NO. 100.21.019






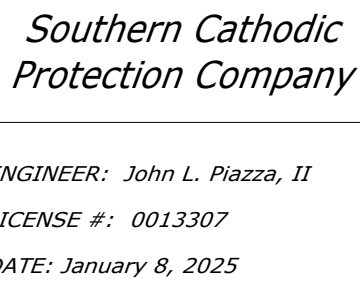 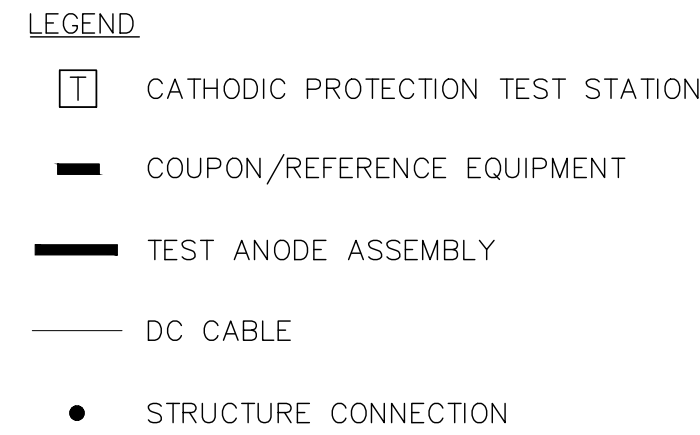 DRAWINGS-CATHODICPROTECTION-FINAL-MANDEVILLE-PHASE1-120624




|                                                                                                                                                                                                                                 |                                                        |                                                                                                                                                                                                                                                                                                                                                                                                                                                        |                                                       |                                                                  |                                               |
|---------------------------------------------------------------------------------------------------------------------------------------------------------------------------------------------------------------------------------|--------------------------------------------------------|--------------------------------------------------------------------------------------------------------------------------------------------------------------------------------------------------------------------------------------------------------------------------------------------------------------------------------------------------------------------------------------------------------------------------------------------------------|-------------------------------------------------------|------------------------------------------------------------------|-----------------------------------------------|
| <div><p><b>MANDEVILLE SEAWALL REPAIRS PROJECT</b></p><p><b>SEGMENT 1</b></p><p><b>CATHODIC PROTECTION - LAYOUT &amp; DETAILS</b></p></div> | <div>DESIGNED<br/>CHECKED</div> <div>CRM<br/>TCH</div> | <div><div><div><b>SEP</b></div><div><b>Southern Cathodic<br/>PROTECTION</b></div></div><div>780. JOHNSON FERRY ROAD<br/>SUITE 225<br/>ATLANTA, GEORGIA 30342<br/>(404) 252-4649<br/>www.cathodicprotection.com</div><div>IN ASSOCIATION WITH<br/><b>BK BURK-KLEINFETER, INC.</b><br/><small>AN ISO 9001:2015 CERTIFIED COMPANY</small><br/>10000 W. PARKWAY<br/>SUITE 100<br/>ATLANTA, GEORGIA 30342<br/>(404) 252-4649<br/>www.bkburk.com</div></div> | <div>DATE</div> <div>JANUARY 2025</div>               | <div>COM PROJ. NO. 100.21.019</div> <div>BKI # : NO.24.007</div> |                                               |
|                                                                                                                                                                                                                                 | <div>DETAILED<br/>CHECKED</div> <div>CRM<br/>TCH</div> |                                                                                                                                                                                                                                                                                                                                                                                                                                                        | <div>8/23/24</div> <div>Revised to final design</div> |                                                                  | <div>CRM</div>                                |
|                                                                                                                                                                                                                                 | <div>DATE</div> <div>7/18/24</div>                     |                                                                                                                                                                                                                                                                                                                                                                                                                                                        | <div>Revised to 90% design</div>                      |                                                                  | <div>CRM</div>                                |
|                                                                                                                                                                                                                                 | <div>SHEET</div> <div>2 OF 3</div>                     |                                                                                                                                                                                                                                                                                                                                                                                                                                                        | <div>DATE</div> <div>1</div>                          |                                                                  | <div>REVISION DESCRIPTION</div> <div>BY</div> |





   

| PURPOSE OF POST | COLOR  | POST QUANTITY PER BOX |
|-----------------|--------|-----------------------|
| STRUCTURE       | BLACK  | 1                     |
| COUPON          | GREEN  | 8                     |
| REF.            | YELLOW | 3                     |

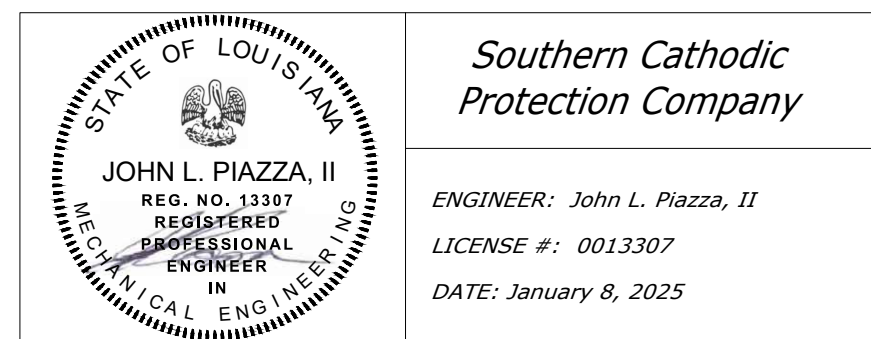



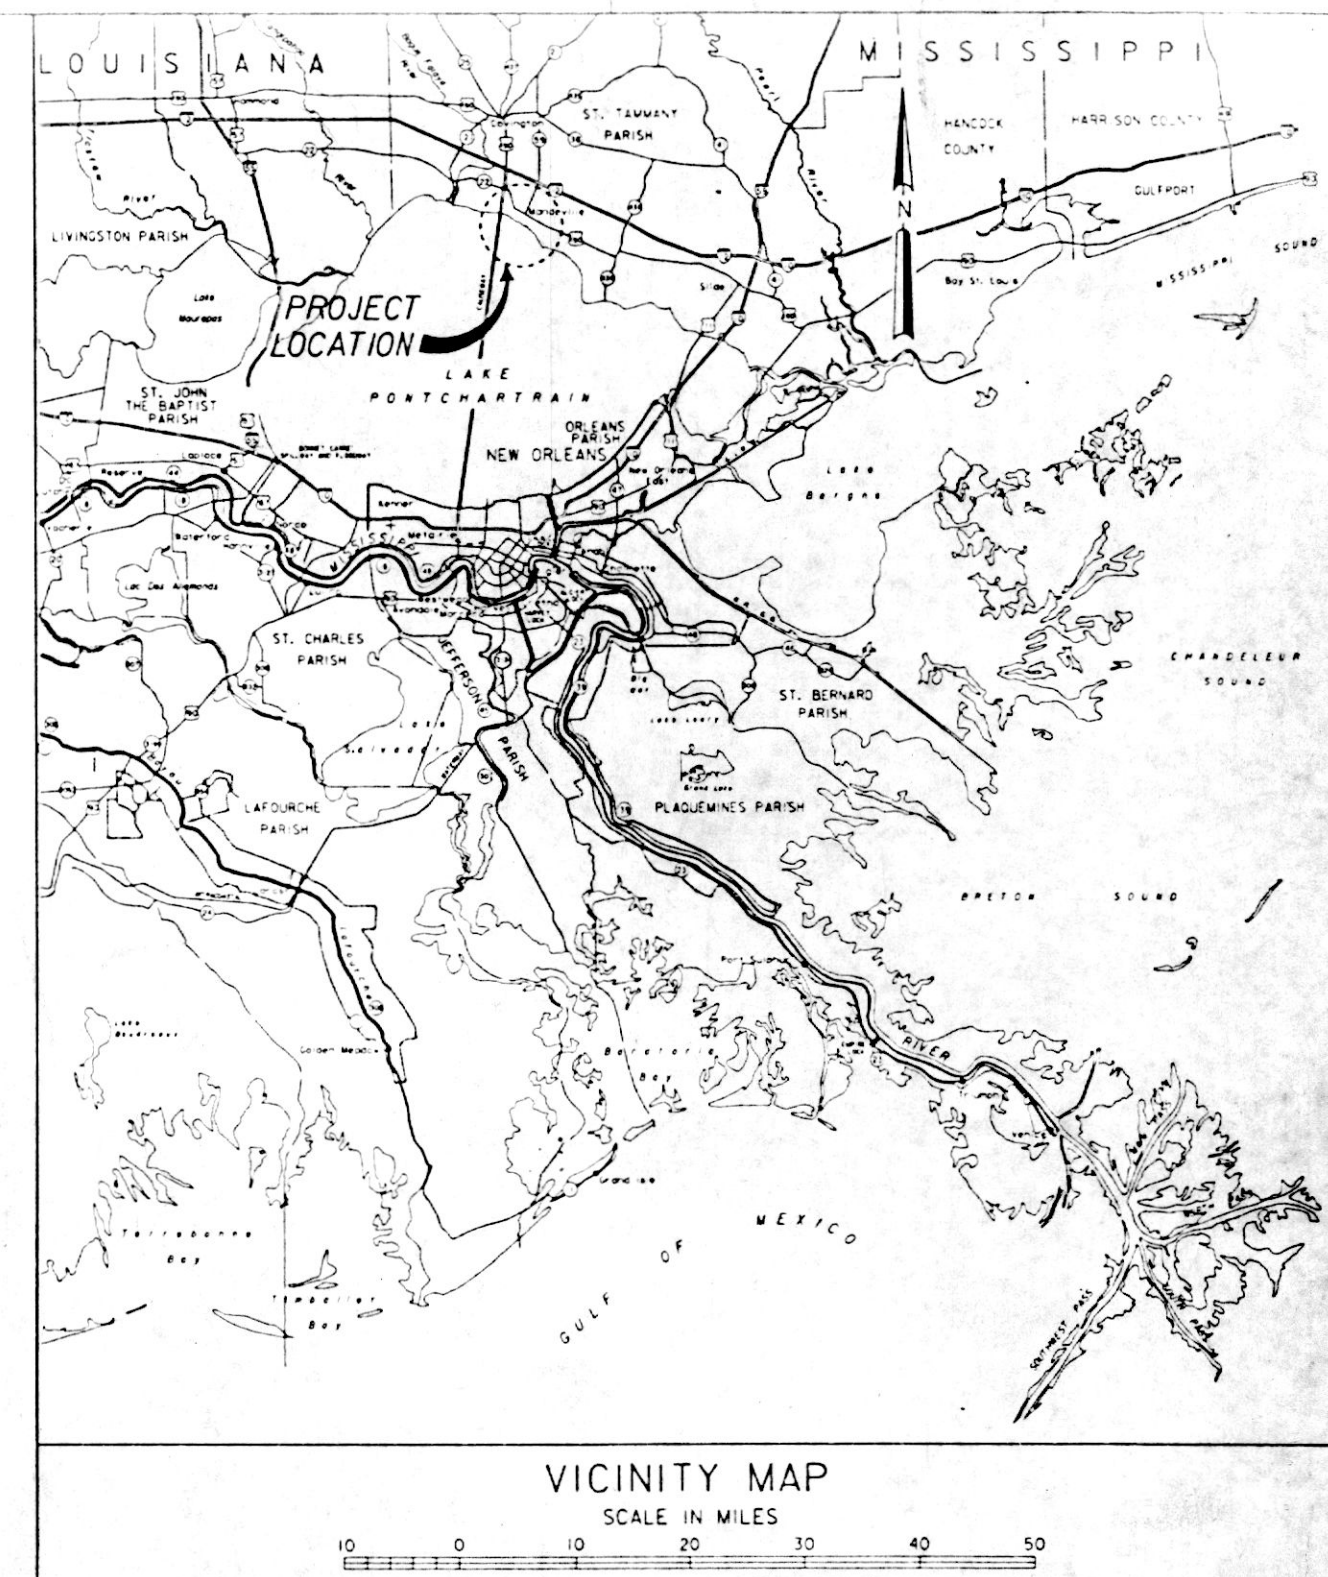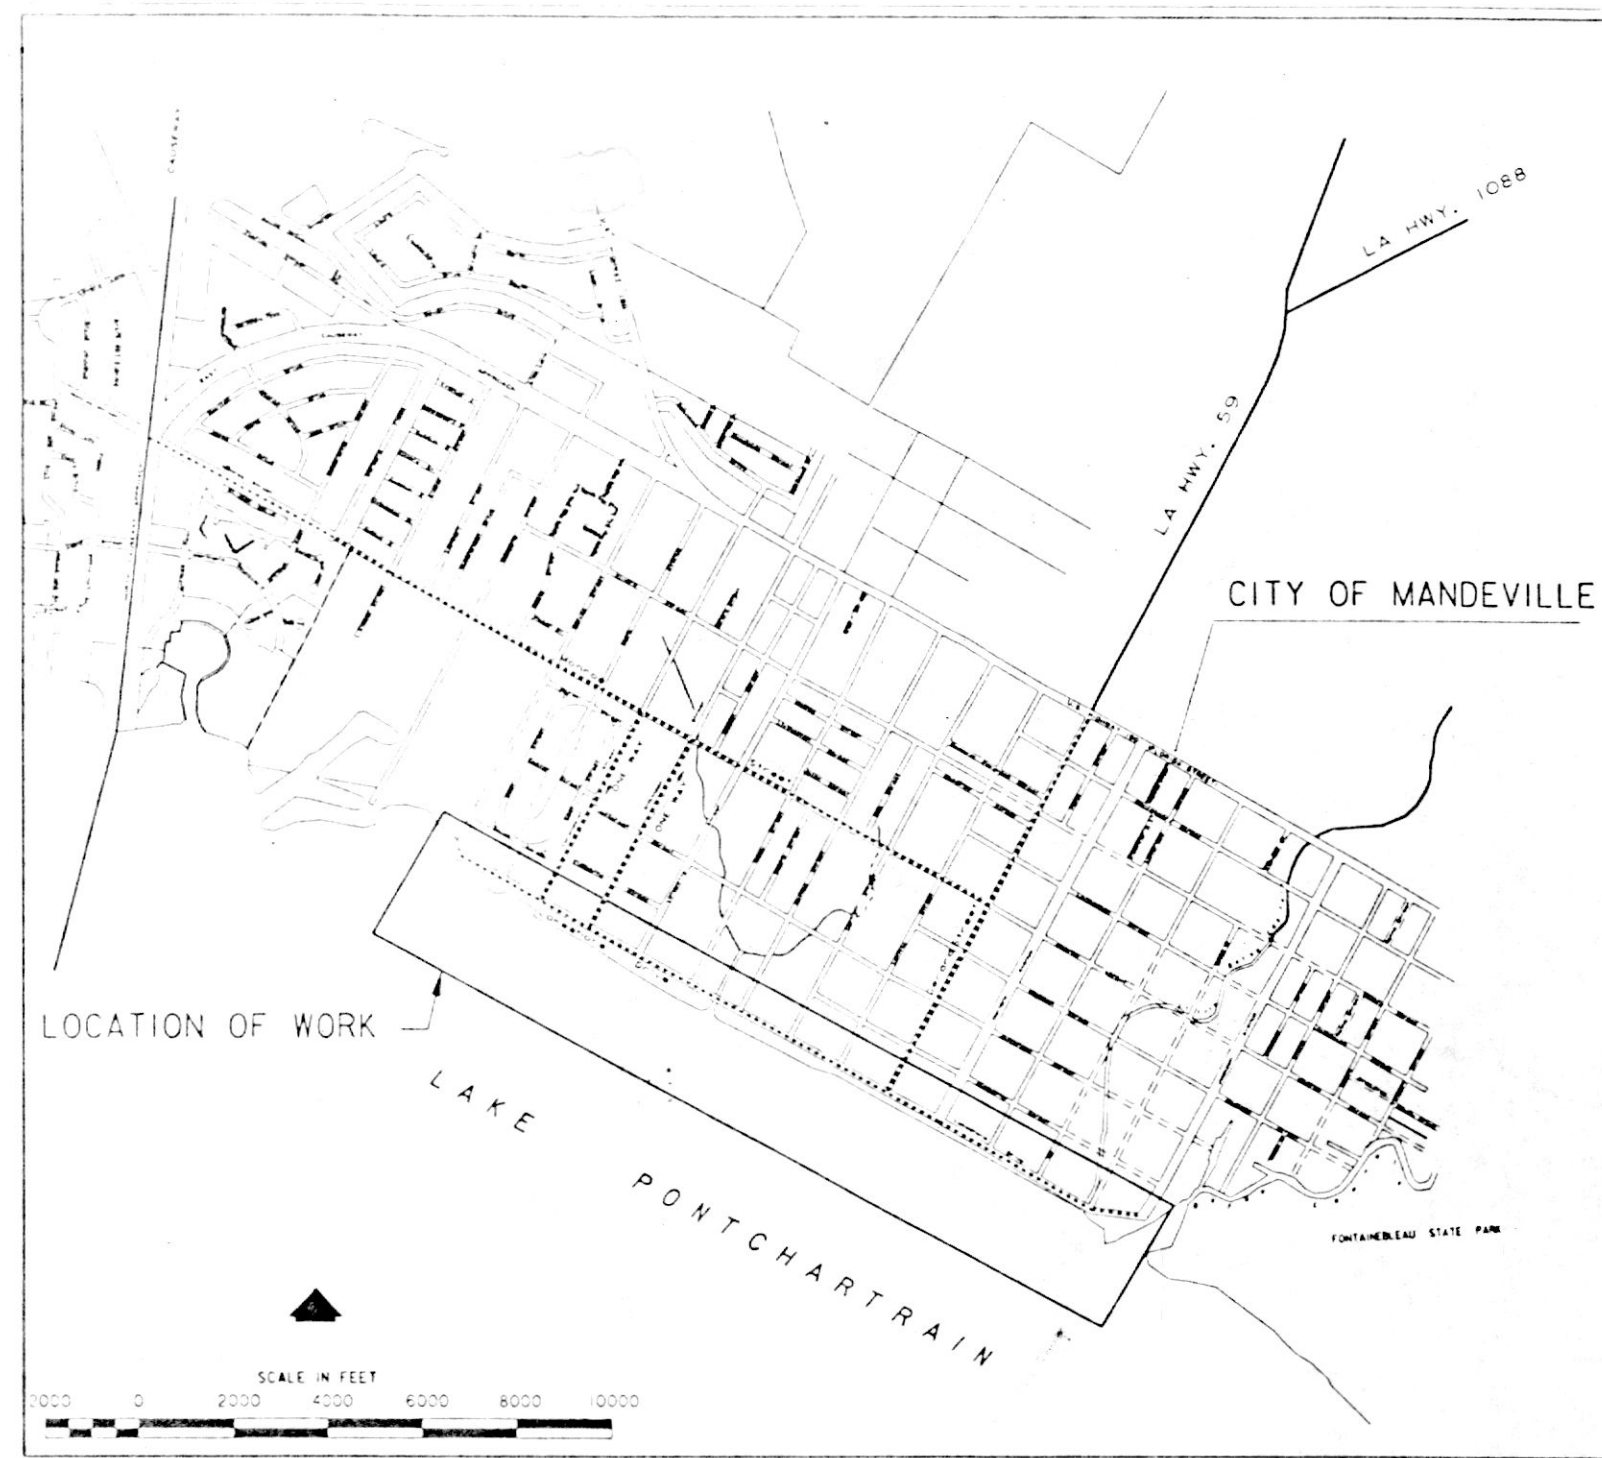

| INDEX TO DRAWINGS |                                                           |      |                                                     |
|-------------------|-----------------------------------------------------------|------|-----------------------------------------------------|
| DWG.              | TITLE                                                     | DWG. | TITLE                                               |
| 1                 | INDEX, LOCATION AND VICINITY MAP                          | 17   | TYPICAL SECTIONS - STA. 00+30 W/L TO STA. 10+00 W/L |
| 2                 | GENERAL NOTES                                             | 18   | TYPICAL SECTIONS - STA. 13+35 W/L TO STA. 26+50 W/L |
| 3                 | PLAN AND PROFILE - STA. 0+00 W/L TO STA. 6+36.74 W/L      | 19   | TYPICAL SECTIONS - STA. 33+30 W/L TO STA. 38+55 W/L |
| 4                 | PLAN AND PROFILE - STA. 6+36.74 W/L TO STA. 12+90.19 W/L  | 20   | TYPICAL SECTIONS - STA. 42+75 W/L TO STA. 55+10 W/L |
| 5                 | PLAN AND PROFILE - STA. 12+90.19 W/L TO STA. 18+78.71 W/L | 21   | TYPICAL SECTIONS - STA. 58+20 W/L TO STA. 66+50 W/L |
| 6                 | PLAN AND PROFILE - STA. 18+78.71 W/L TO STA. 24+70.98 W/L | 22   | TYPICAL SECTIONS - STA. 72+25 W/L TO STA. 82+85 W/L |
| 7                 | PLAN AND PROFILE - STA. 24+70.98 W/L TO STA. 31+17.61 W/L | 23   | STEEL SHEET PILE LAYOUT                             |
| 8                 | PLAN AND PROFILE - STA. 31+17.61 W/L TO STA. 39+00.22 W/L | 24   | SHEET PILE DETAILS                                  |
| 9                 | PLAN AND PROFILE - STA. 39+00.22 W/L TO STA. 45+33.58 W/L | 25   | SEAWALL REINFORCEMENT AND DETAILS                   |
| 10                | PLAN AND PROFILE - STA. 45+33.58 W/L TO STA. 51+43.73 W/L | 26   | DRAINAGE MODIFICATION DETAILS                       |
| 11                | PLAN AND PROFILE - STA. 51+43.73 W/L TO STA. 57+37.52 W/L | 27   | CONCRETE STAIR DETAILS                              |
| 12                | PLAN AND PROFILE - STA. 57+37.52 W/L TO STA. 63+13.52 W/L | 28   | EXISTING WALL PROFILE                               |
| 13                | PLAN AND PROFILE - STA. 63+13.52 W/L TO STA. 68+66.21 W/L | 29   | SOIL BORING LEGEND                                  |
| 14                | PLAN AND PROFILE - STA. 68+66.21 W/L TO STA. 74+39.28 W/L | 30   | BORING LOGS                                         |
| 15                | PLAN AND PROFILE - STA. 74+39.28 W/L TO STA. 80+08.98 W/L | 31   | STAGE HYDROGRAPH                                    |
| 16                | PLAN AND PROFILE - STA. 80+08.98 W/L TO STA. 83+25.09 W/L |      |                                                     |

| BENCH MARK DESCRIPTION |                                                                                                                                                                                                                                                                                                                                                                                                                                                                                           |                             |
|------------------------|-------------------------------------------------------------------------------------------------------------------------------------------------------------------------------------------------------------------------------------------------------------------------------------------------------------------------------------------------------------------------------------------------------------------------------------------------------------------------------------------|-----------------------------|
| DESIGNATION            | DESCRIPTION                                                                                                                                                                                                                                                                                                                                                                                                                                                                               | ELEV. N.G.V.D.              |
| MANDEVILLE 1934 4      | LOCATED 0.7 MILE SOUTH OF THE INTERSECTION OF STATE HIGHWAY 114 AND U.S. HIGHWAY 190, IN THE NORTHEAST CORNER OF THE INTERSECTION OF LAKESHORE DR. AND LAFITTE ST., IN THE SOUTH-WEST CORNER OF THE LAWN OF THE OLD GEORGIAN MANNER HOTEL, 1 FOOT EAST OF THE EAST EDGE OF THE SIDEWALK AND 1 FOOT NORTH OF AN EAST-WEST SIDEWALK. IT IS A STANDARD DISK SET IN THE TOP OF A CONCRETE POST, 2 INCHES BELOW THE SURFACE OF THE LAWN AND IS ABOUT 2 INCHES ABOVE THE LEVEL OF THE SIDEWALK. | 4.265 N.G.V.D. (1969 EPOCH) |

Safety is a Part of Your Contract



THIS PLAN ACCOMPANIES MODIFICATION P0000 TO CONTRACT NUMBER DACW29-94-C-0031



|                                                                                                                                                                                                                                                                                                                          |                    |                 |                          |                    |
|--------------------------------------------------------------------------------------------------------------------------------------------------------------------------------------------------------------------------------------------------------------------------------------------------------------------------|--------------------|-----------------|--------------------------|--------------------|
| DESIGNED BY: R.W.Y.                                                                                                                                                                                                                                                                                                      | CHECKED BY: R.W.Y. | DATE: NOV. 1993 | APPROVED BY: [Signature] | FILE NO. H-4-40335 |
| <p>U. S. ARMY ENGINEER DISTRICT, NEW ORLEANS<br/>CORPS OF ENGINEERS<br/>NEW ORLEANS, LOUISIANA</p> <p><b>Brown Cunningham Gannuch</b><br/>ENGINEERS - ARCHITECTS - CONSULTANTS</p> <p>MANDEVILLE SEAWALL, LA.<br/>REPLACEMENT OF MANDEVILLE SEAWALL<br/>ST. TAMMANY PARISH, LA.<br/>INDEX, LOCATION AND VICINITY MAP</p> |                    |                 |                          |                    |



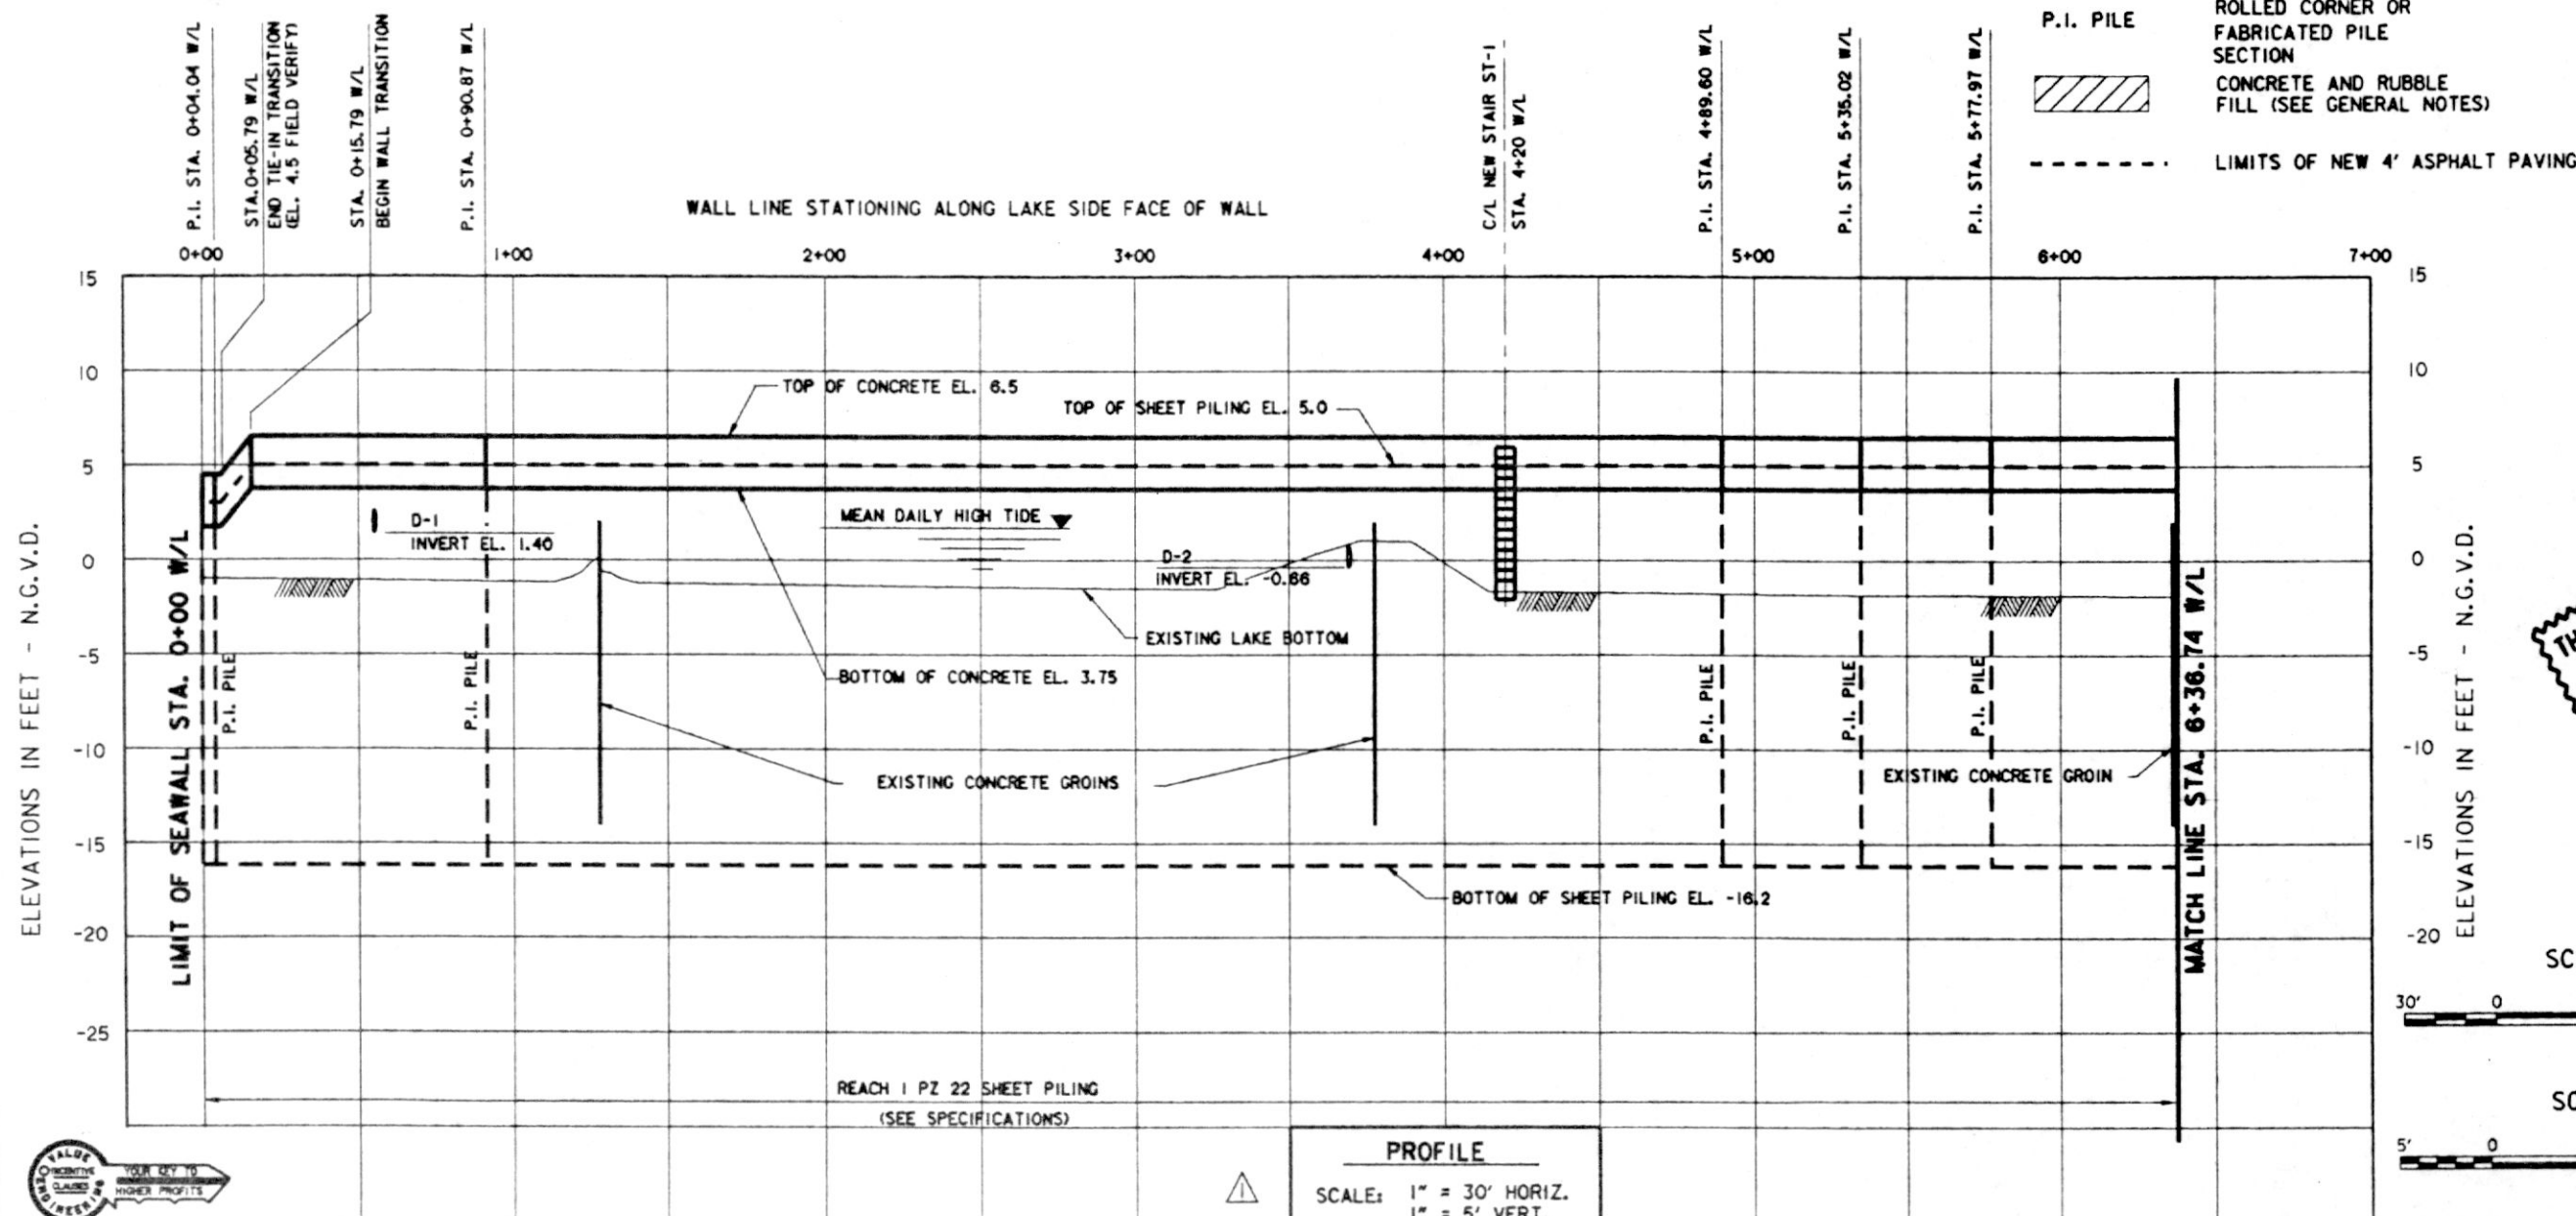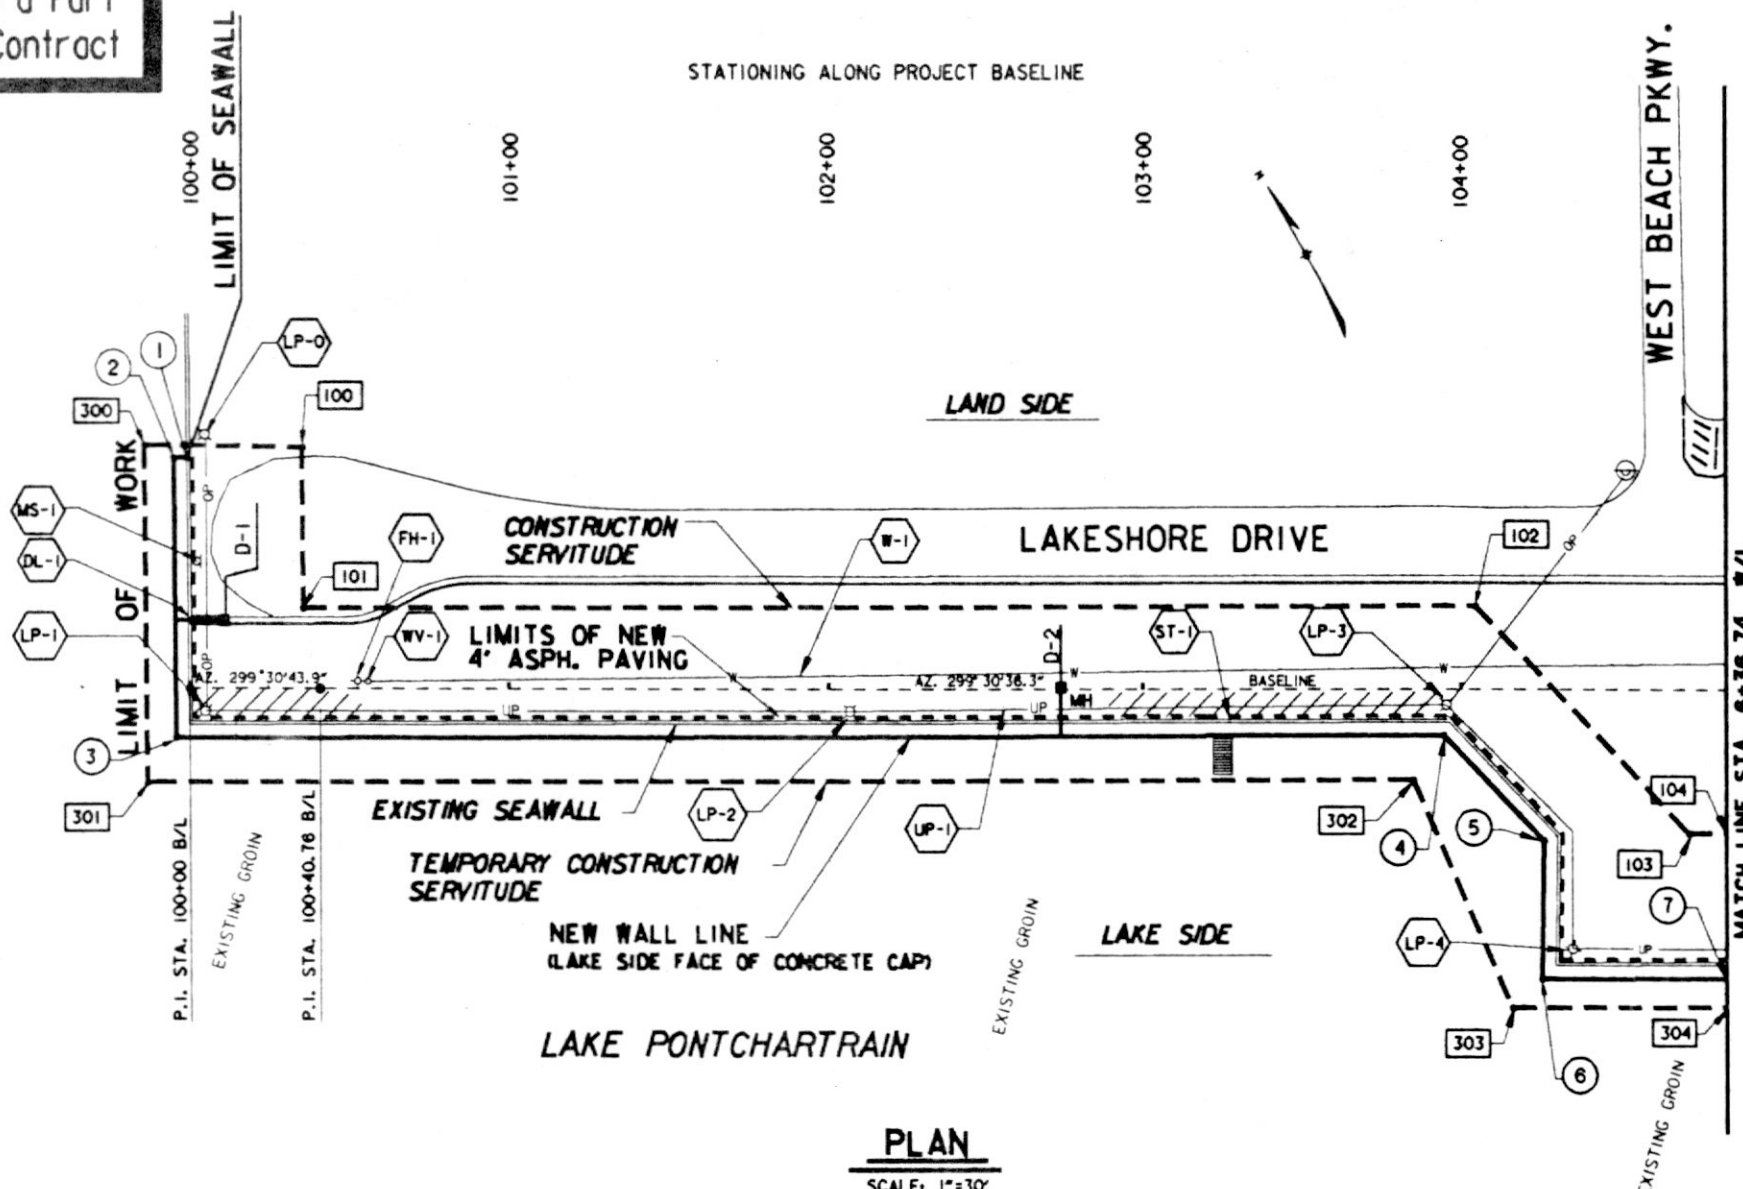
Safety is a Part  
of Your Contract



| WALL LINE DATA |                     |                           |     |                      |
|----------------|---------------------|---------------------------|-----|----------------------|
| P.I.<br>NO.    | BASILINE<br>STATION | DISTANCE FROM<br>BASILINE |     | WALL LINE<br>STATION |
| *1             | 99 + 99.20          | 71.11                     | LT. | 0 + 00.00            |
| 2              | 99 + 95.19          | 71.64                     | LT. | 0 + 04.04            |
| 3              | 99 + 95.68          | 15.15                     | RT. | 0 + 90.87            |
| 4              | 103 + 94.41         | 14.21                     | RT. | 4 + 89.60            |
| 5              | 104 + 25.88         | 46.97                     | RT. | 5 + 35.02            |
| 6              | 104 + 25.23         | 89.91                     | RT. | 5 + 77.97            |
| 7              | 104 + 84.00         | 89.72                     | RT. | 5 + 36.74            |

• LIMIT OF NEW SEAWALL

### LEGEND

 - |                                                                                                      |                                                     |
|------------------------------------------------------------------------------------------------------|-----------------------------------------------------|
| <u>AL 200' 30' 36.3"</u>                                                                             | <b>SURVEY BASELINE</b>                              |
| — W — W —                                                                                            | <b>WATERLINE</b>                                    |
| — OP — OP —                                                                                          | <b>OVERHEAD POWER LINE</b>                          |
| — UP — UP —                                                                                          | <b>UNDERGROUND POWER LINE</b>                       |
| — S — S —                                                                                            | <b>SEWER LINE</b>                                   |
| == == == ==                                                                                          | <b>DRAIN LINE</b>                                   |
|                   | <b>CONCRETE STEPS</b>                               |
|                   | <b>LIGHT POLE</b>                                   |
|                   | <b>FIRE HYDRANT</b>                                 |
|                   | <b>WATER VALVE</b>                                  |
|                   | <b>METAL SIGN AND POST</b>                          |
|                   | <b>UTILITY POLE AND GUY WIRE</b>                    |
|                   | <b>UTILITY POLE</b>                                 |
|                   | <b>REQUIRED DRAINAGE MODIFICATIONS</b>              |
|                   | <b>EXISTING POST</b>                                |
|                   | <b>EXISTING RIPRAP</b>                              |
| <b>2-MU</b><br> | <b>UNDISTURBED BORING</b>                           |
| <b>P.I. PILE</b>                                                                                     | <b>ROLLED CORNER OR FABRICATED PILE SECTION</b>     |
|                 | <b>CONCRETE AND RUBBLE FILL (SEE GENERAL NOTES)</b> |
| — — — — —                                                                                            | <b>LIMITS OF NEW 4' ASPHALT</b>                     |

| CONSTRUCTION<br>SERVITUDE |                |                                  | TEMPORARY<br>CONSTRUCTION<br>SERVITUDE |                |                                  |
|---------------------------|----------------|----------------------------------|----------------------------------------|----------------|----------------------------------|
| LAND SIDE                 |                |                                  | LAKE SIDE                              |                |                                  |
| P.I.<br>NO.               | B/L<br>STATION | DISTANCE<br>MEASURED<br>FROM B/L | P.I.<br>NO.                            | B/L<br>STATION | DISTANCE<br>MEASURED<br>FROM B/L |
| 100                       | 100+35.2       | 75.9' LT.                        | 300                                    | 99+86.2        | 75.6' LT.                        |
| 101                       | 100+35.0       | 24.9' LT.                        | 301                                    | 99+86.8        | 29.2' RT.                        |
| 102                       | 104+04.5       | 25.8' LT.                        | 302                                    | 103+84.8       | 28.2' RT.                        |
| 103                       | 104+72.1       | 44.5' RT.                        | 303                                    | 104+16.1       | 98.9' RT.                        |
| 104                       | 104+84.0       | 45.5' RT.                        | 304                                    | 104+84.0       | 98.7' RT.                        |

## EXISTING FACILITIES

| ITEM | DESCRIPTION                  | B/L STATION        | OWNER              | DISPOSITION   |
|------|------------------------------|--------------------|--------------------|---------------|
| DL-1 | 10"x24" BOX CULVERT          | 100+00 TO 100+06.1 | CITY OF MANDEVILLE | CONTR. REMOVE |
| MS-1 | METAL SIGN & POST            | 100+02.8           | CITY OF MANDEVILLE | OWNER RELOC.  |
| LP-0 | LIGHT POLE W/OP LINE         | 100+04.81          | CLECO              | OWNER RELOC.  |
| LP-1 | LIGHT POLE W/OP LINE         | 100+04.8           | CLECO              | OWNER RELOC.  |
| UP-1 | 3" ELEC. UNDERGROUND CONDUIT | 100+04.8 TO 104+84 | CLECO              | ABANDON       |
| FH-1 | FIRE HYDRANT                 | 100+35             | CITY OF MANDEVILLE | NOT AFFECTED  |
| W-1  | 8" WATER MAIN                | 100+35 TO 104+22.3 | CITY OF MANDEVILLE | NOT AFFECTED  |
| WV-1 | WATER VALVE                  | 100+37             | CITY OF MANDEVILLE | NOT AFFECTED  |
| LP-2 | LIGHT POLE W/UP LINE         | 102+06.6           | CLECO              | OWNER*RELOC.  |
| ST-1 | CONCRETE STEPS               | 103+24.6           | CITY OF MANDEVILLE | CONTR. REMOVE |
| LP-3 | LIGHT POLE W/UP LINE         | 103+95.2           | CLECO              | OWNER RELOC.  |
| LP-4 | LIGHT POLE W/UP LINE         | 104+34.9           | CLECO              | OWNER RELOC.  |

\* CONTRACTOR NOT TO DISTURB

**000** DENOTES CONSTRUCTION SERVITUDE P.I. NUMBERS

(8) DENOTES WALL LINE P.I. NUMBERS

**NOTES:**

1. FOR GENERAL NOTES, SEE DWG. 2
2. FOR GROIN MODIFICATIONS, SEE DWG. 24
3. FOR WALL TRANSITION DETAILS, SEE DWG. 25
4. FOR DRAIN DETAILS, SEE DWG. 26
5. FOR STAIR DETAILS, SEE DWG. 27
6. FOR SOIL BORING LOGS, SEE DWG. 30
7. FOR LAKE HYDROGRAPH, SEE DWG. 31
8. STAKES AND GUY WIRES AROUND SMALL TREES NOT SHOWN. CONTRACTOR TO MAINTAIN.
9. EXTENT OF RIPRAP ON LAKE BOTTOM AND DEBRIS BEHIND WALL MAY VARY FROM THAT SHOWN.

9.

THIS PLAN ACCOMPANIES  
MODIFICATION P0000  
TO CONTRACT NUMBER  
DACW29-94-C-0031



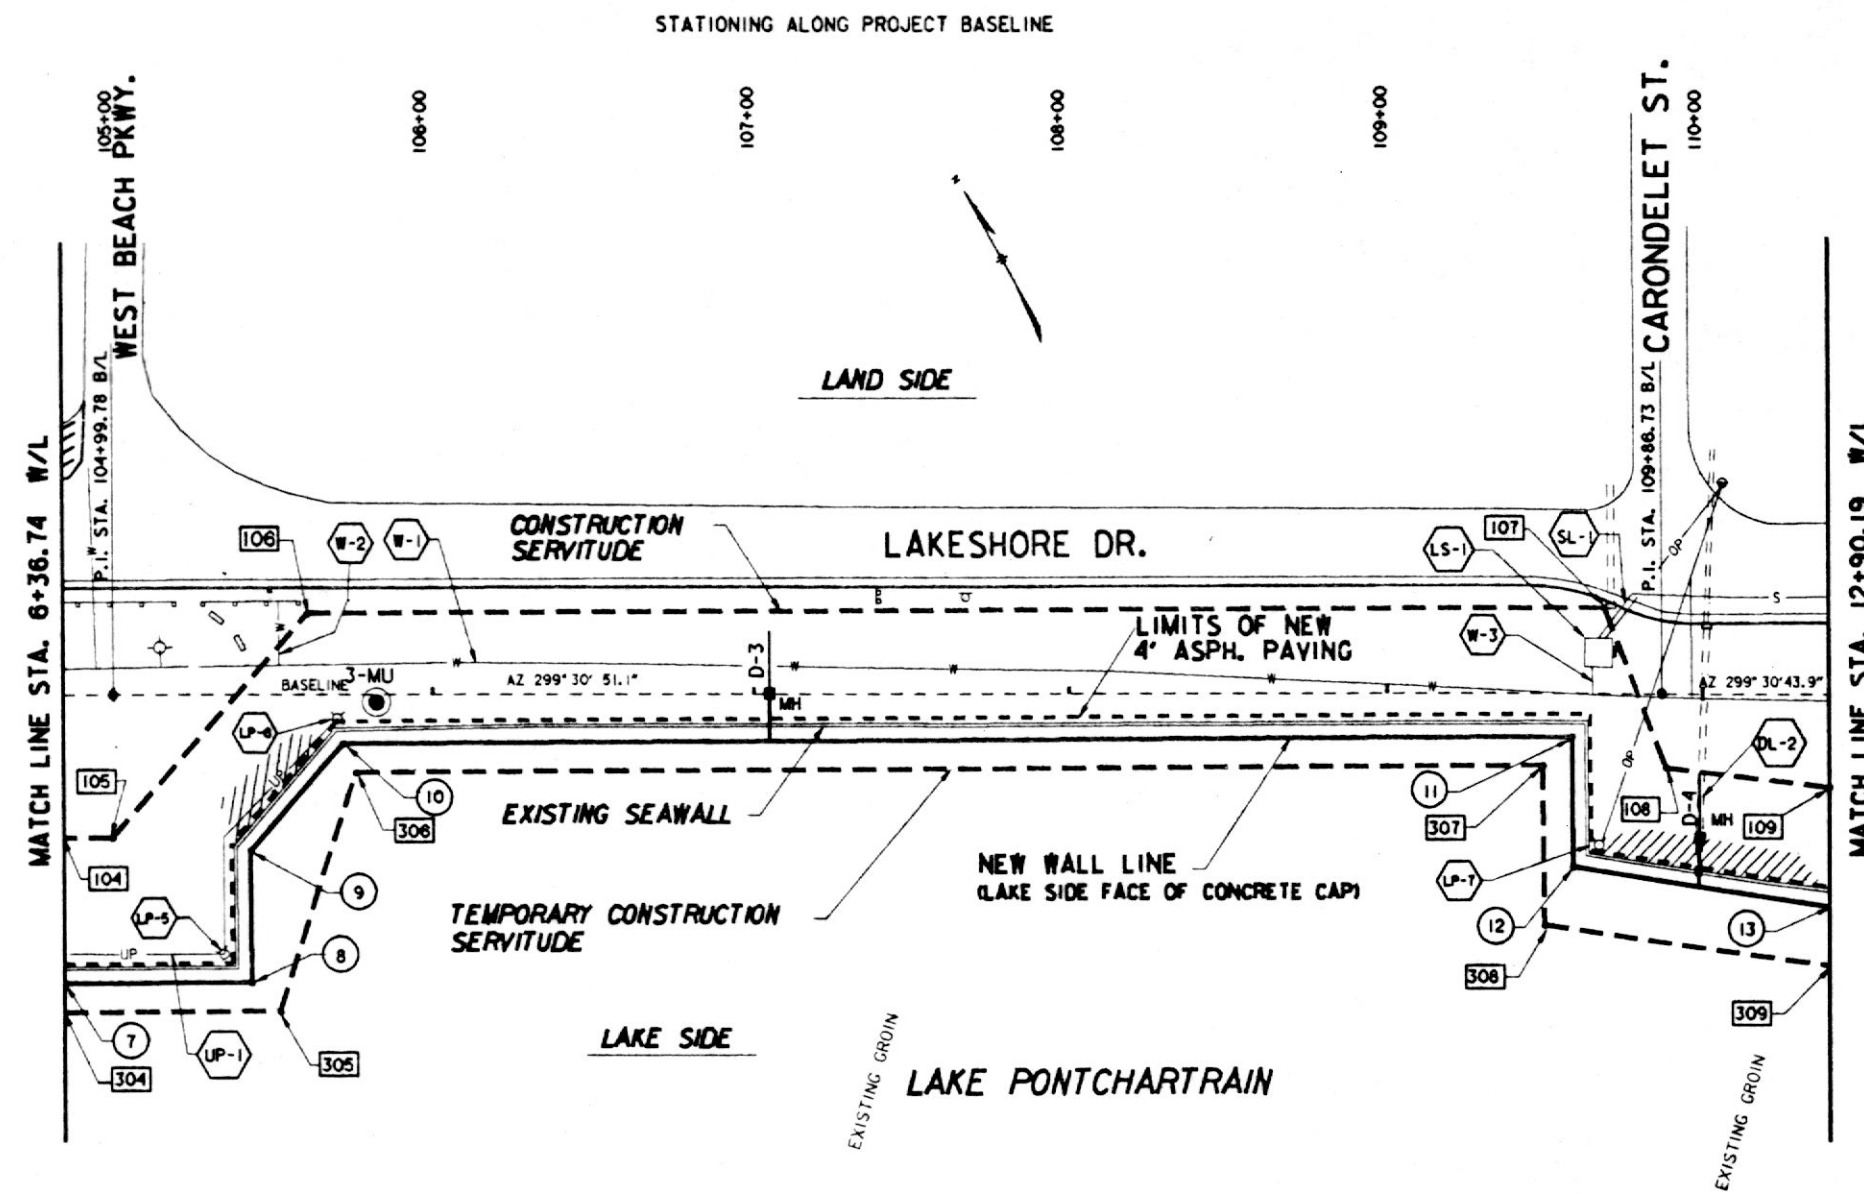


SCALE: 1" = 30'

SCALE: 1" = 5'


|                                                                                                                                                        |                                                                                           |                              |                      |
|--------------------------------------------------------------------------------------------------------------------------------------------------------|-------------------------------------------------------------------------------------------|------------------------------|----------------------|
| ⚠                                                                                                                                                      | REVISED TOP OF WALL AND SHEET PILING IN<br>PROFILE AND P.I. 3 W/L STATING MOD.            | 4-5-94                       | W.O.B.               |
|                                                                                                                                                        | SYMBOL                                                                                    | DESCRIPTION                  | DATE APPROVED        |
| REVISIONS                                                                                                                                              |                                                                                           |                              |                      |
|                                                                   | U. S. ARMY ENGINEER DISTRICT, NEW ORLEANS<br>CORPS OF ENGINEERS<br>NEW ORLEANS, LOUISIANA |                              |                      |
|  Brown Cunningham Gannuch<br>ENGINEERS • ARCHITECTS • CONSULTANTS |                                                                                           |                              |                      |
| MANDEVILLE SEAWALL, LA.<br><b>REPLACEMENT OF MANDEVILLE SEAWALL</b><br>ST. TAMMANY PARISH, LOUISIANA                                                   |                                                                                           |                              |                      |
| <b>PLAN AND PROFILE</b><br><b>STA. 0+00 W/L TO STA. 6+36.74 W/L</b>                                                                                    |                                                                                           |                              |                      |
| DESIGNED BY: R.W.Y.                                                                                                                                    | DATE: NOV. 1993                                                                           | PLOT SCALE: 360              | PLOT DATE: NOV. 1993 |
| DRAWN BY: J.S.B.                                                                                                                                       | CADD FILES: 40335-03.DGN                                                                  | FILE NO.<br><b>H-4-00335</b> | DWG. 3 OF 31         |
| CHECKED BY: T.P.H.                                                                                                                                     |                                                                                           |                              |                      |
| SUBMITTED BY: ROBERT W. YOKUM, P.E.<br>PROJECT NO. DACW29-94-B-0024                                                                                    |                                                                                           |                              |                      |





### PLAN

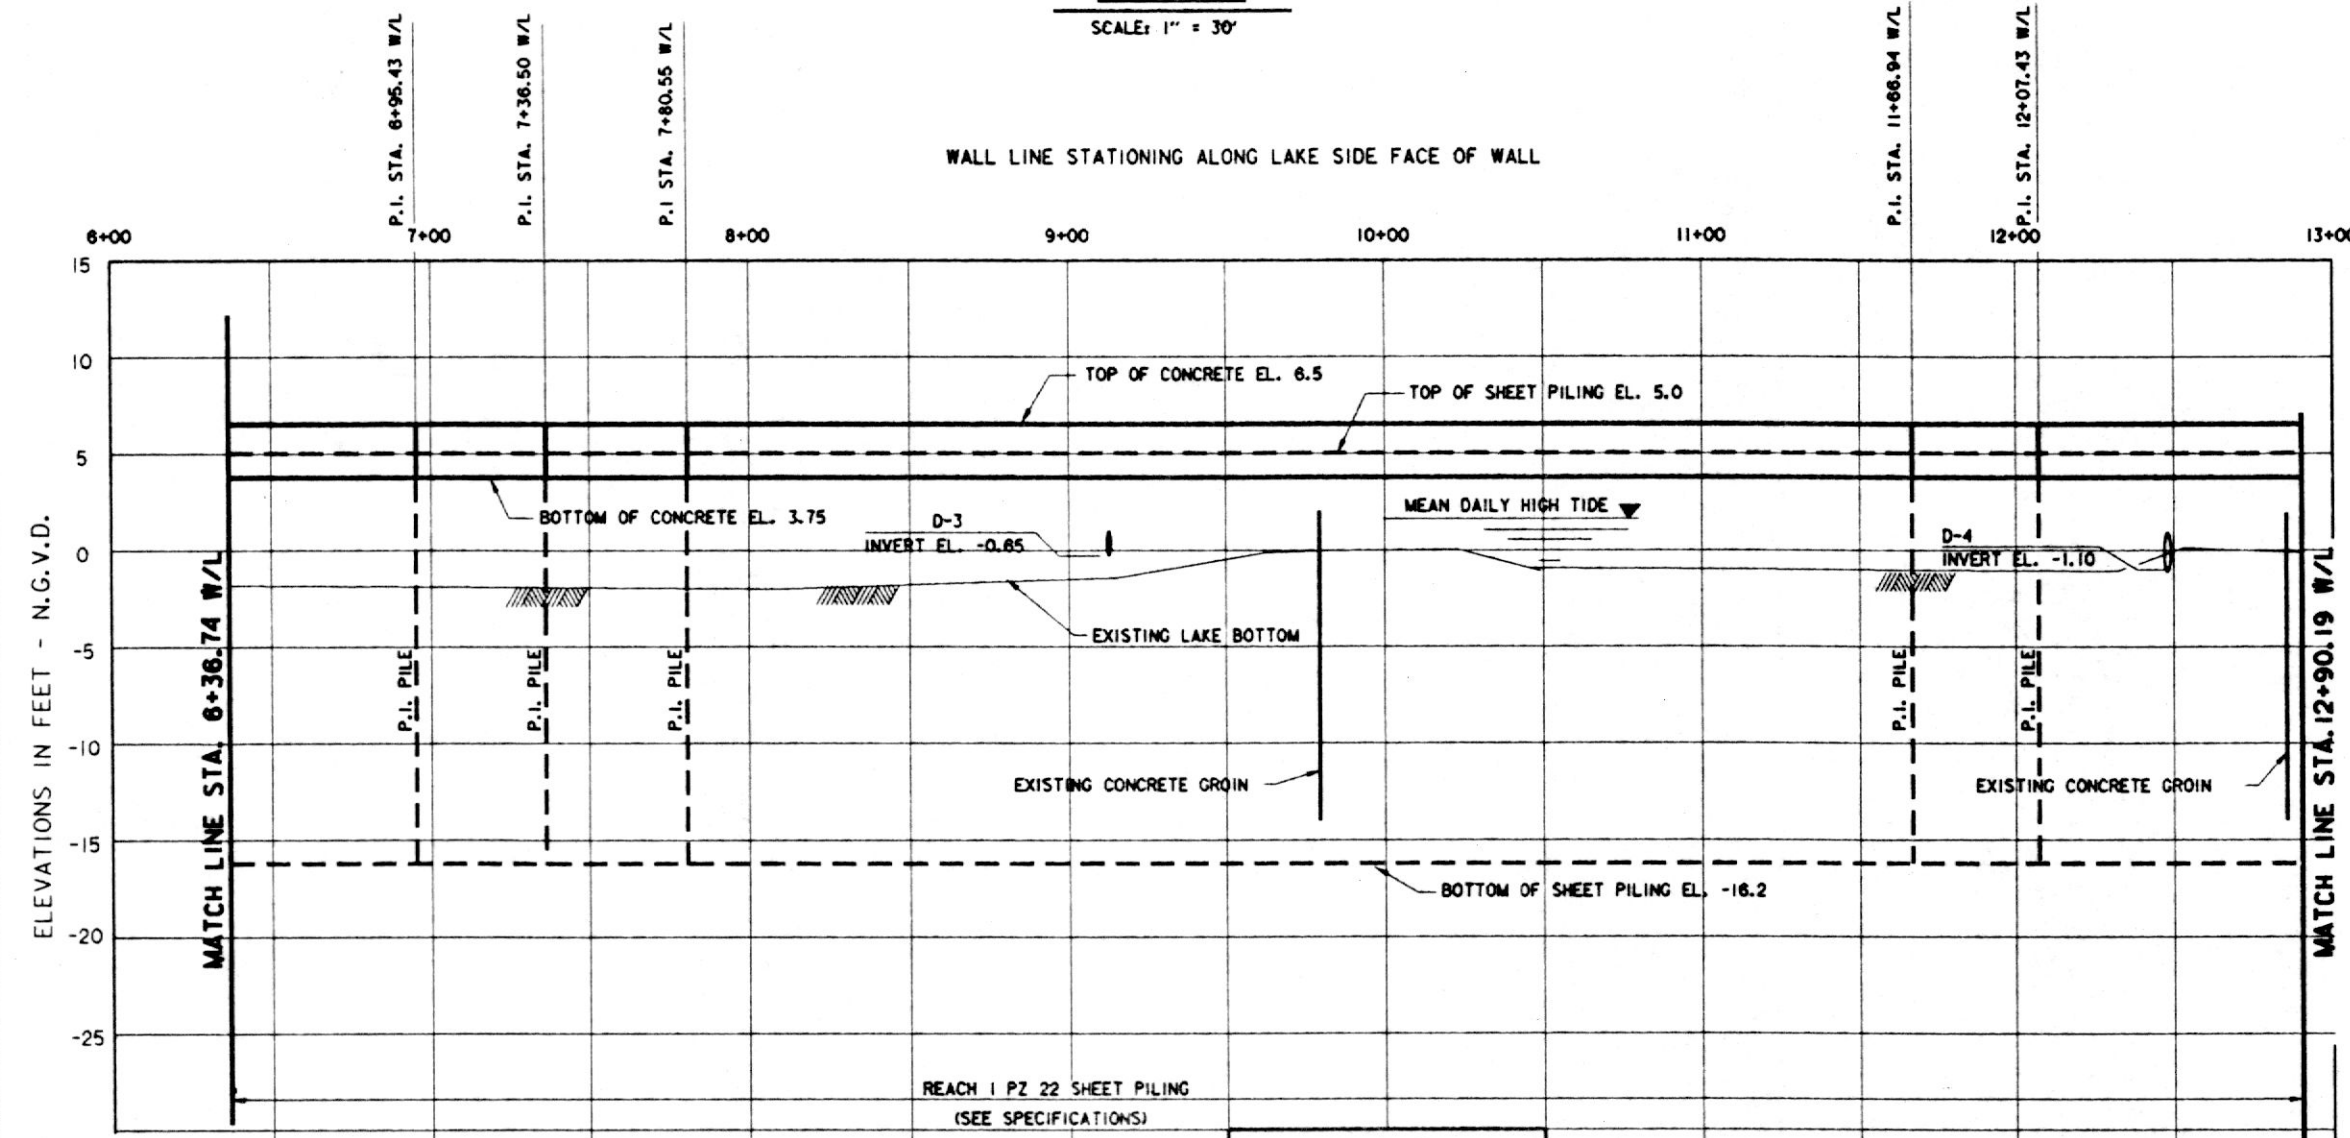SCALE: 1" = 30'



### PROFILE

SCALE: 1" = 30' HORIZ.  
1" = 5' VERT.

| WALL LINE DATA |                  |                        |     |                   |
|----------------|------------------|------------------------|-----|-------------------|
| P.I. NO.       | BASELINE STATION | DISTANCE FROM BASELINE |     | WALL LINE STATION |
| 7              | 104+84.00        | 89.72                  | RT. | 6+36.74           |
| 8              | 105+42.69        | 89.53                  | RT. | 6+95.43           |
| 9              | 105+42.46        | 48.46                  | RT. | 7+36.50           |
| 10             | 105+71.60        | 15.42                  | RT. | 7+80.55           |
| 11             | 109+57.98        | 13.49                  | RT. | 11+66.94          |
| 12             | 109+58.12        | 53.98                  | RT. | 12+07.43          |
| 13             | 110+40.00        | 66.04                  | RT. | 12+90.19          |

| CONSTRUCTION SERVITUDE |             |                            | TEMPORARY CONSTRUCTION SERVITUDE |             |                            |
|------------------------|-------------|----------------------------|----------------------------------|-------------|----------------------------|
| LAND SIDE              |             |                            | LAKE SIDE                        |             |                            |
| P.I. NO.               | B/L STATION | DISTANCE MEASURED FROM B/L | P.I. NO.                         | B/L STATION | DISTANCE MEASURED FROM B/L |
| 104                    | 104+84.0    | 44.5' RT.                  | 304                              | 104+84.0    | 98.7' RT.                  |
| 105                    | 104+99.4    | 44.4' RT.                  | 305                              | 105+51.7    | 98.5' RT.                  |
| 106                    | 105+60.6    | 25.1' LT.                  | 306                              | 105+75.7    | 24.4' RT.                  |
| 107                    | 109+68.5    | 26.6' LT.                  | 307                              | 109+48.7    | 22.5' RT.                  |
| 108                    | 109+88.0    | 23.0' RT.                  | 308                              | 109+49.2    | 72.1' RT.                  |
| 109                    | 110+40.0    | 29.0' RT.                  | 309                              | 110+40.0    | 84.3' RT.                  |

| EXISTING FACILITIES |                          |                      |                    |               |
|---------------------|--------------------------|----------------------|--------------------|---------------|
| ITEM                | DESCRIPTION              | B/L STATION          | OWNER              | DISPOSITION   |
| UP-1                | 3" ELEC. CONDUIT         | 104+84 TO 105+70     | CLECO              | ABANDON       |
| W-1                 | 8" WATER MAIN            | 105+46.4 TO 109+79.3 | CITY OF MANDEVILLE | NOT AFFECTED  |
| LP-5                | LIGHT POLE W/UP LINE     | 105+34               | CLECO              | OWNER RELOC.  |
| W-2                 | 2" WATER LINE            | 105+51.5             | CITY OF MANDEVILLE | NOT AFFECTED  |
| LP-6                | LIGHT POLE W/UP LINE     | 105+70               | CLECO              | OWNER RELOC.  |
| W-3                 | 2" WATER LINE            | 109+64.6             | CITY OF MANDEVILLE | NOT AFFECTED  |
| SL-1                | 10" SEWER LINE           | 109+66.5 TO 109+70.3 | CITY OF MANDEVILLE | NOT AFFECTED  |
| LS-1                | SEWERAGE LIFT STATION    | 109+66.5             | CITY OF MANDEVILLE | NOT AFFECTED  |
| LP-7                | LIGHT POLE W/OP LINE     | 109+66.4             | CLECO              | OWNER RELOC.  |
| DL-2                | 24" CLAY PIPE DRAIN LINE | 109+98.6             | CITY OF MANDEVILLE | CONTR. RELOC. |

- \* CONTRACTOR NOT TO DISTURB  
 0000 DENOTES CONSTRUCTION SERVITUDE P.I. NUMBERS  
 6 DENOTES WALL LINE P.I. NUMBERS

### NOTES:

- FOR GENERAL NOTES, SEE DWG. 2
- FOR LEGEND, SEE DWG. 3
- FOR GROIN MODIFICATIONS, SEE DWG. 24
- FOR WALL TRANSITION DETAILS, SEE DWG. 25
- FOR DRAIN DETAILS, SEE DWG. 26
- FOR STAIR DETAILS, SEE DWG. 27
- FOR SOIL BORING LOGS SEE DWG. 30
- FOR LAKE HYDROGRAPH SEE DWG. 31
- STAKES AND GUY WIRES AROUND SMALL TREES NOT SHOWN. CONTRACTOR TO MAINTAIN.
- EXTENT OF RIPRAP ON LAKE BOTTOM AND DEBRIS BEHIND WALL MAY VARY FROM THAT SHOWN.

Safety is a Part of Your Contract

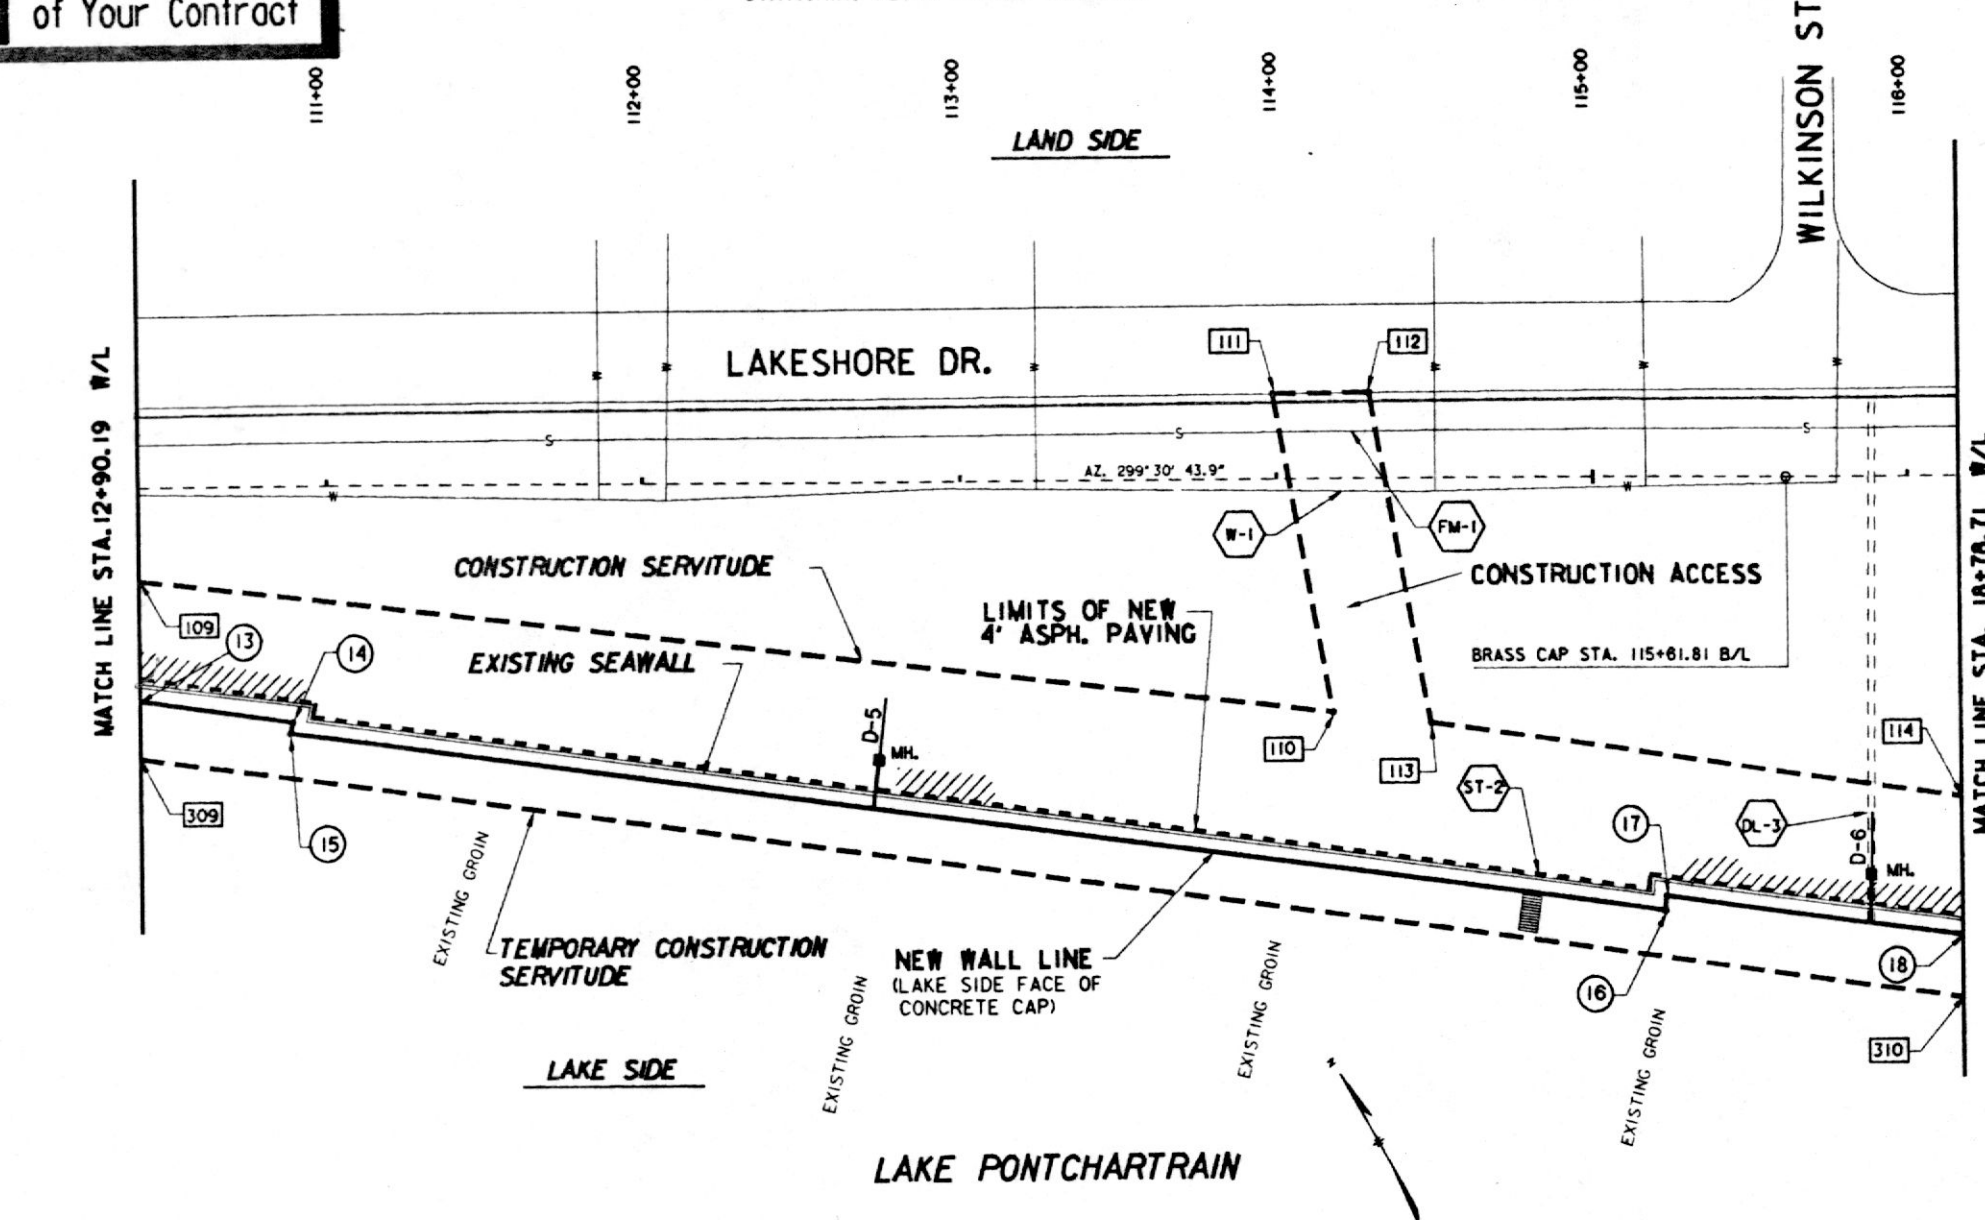
THIS PLAN ACCOMPANIES MODIFICATION P0000 TO CONTRACT NUMBER DACW29-94-C-0031

|                                                                                                                                                                          |                                   |                    |                      |
|--------------------------------------------------------------------------------------------------------------------------------------------------------------------------|-----------------------------------|--------------------|----------------------|
| REVISED TOP OF WALL AND SHEET PILING IN PROFILE MOD.                                                                                                                     |                                   | 4-5-94             | W.O.B.               |
| SYMBOL                                                                                                                                                                   | DESCRIPTION                       | DATE               | APPROVED             |
|                                                                                                                                                                          |                                   |                    |                      |
| <b>U. S. ARMY ENGINEER DISTRICT, NEW ORLEANS</b><br>CORPS OF ENGINEERS<br>NEW ORLEANS, LOUISIANA                                                                         |                                   |                    |                      |
| <b>Brown Cunningham Gannuch</b><br>ENGINEERS - ARCHITECTS - CONSULTANTS<br>MANDEVILLE SEAWALL, LA.<br>REPLACEMENT OF MANDEVILLE SEAWALL<br>ST. TAMMANY PARISH, LOUISIANA |                                   |                    |                      |
| <b>PLAN AND PROFILE</b><br>STA. 6+36.74 W/L TO STA. 12+90.19 W/L                                                                                                         |                                   |                    |                      |
| DESIGNED BY: R.W.Y.                                                                                                                                                      | DATES: NOV. 1993                  | PLOT SCALE: 360    | PLOT DATE: NOV. 1993 |
| DRAWN BY: J.S.B.                                                                                                                                                         | CADD FILES: 40335-04.DGN          | FILE NO. H-4-40335 |                      |
| CHECKED BY: T.P.H.                                                                                                                                                       | SOLICITATION NO. DACW29-94-B-0024 | DWG. 4 OF 31       |                      |
| SUBMITTED BY: ROBERT W. YOKUM, P.E.<br>DESIGN ENGINEER                                                                                                                   |                                   |                    |                      |




**Safety is a Part  
of Your Contract**

STATIONING ALONG PROJECT BASELINE



**PLAN**  
**SCALE: 1"=30'**

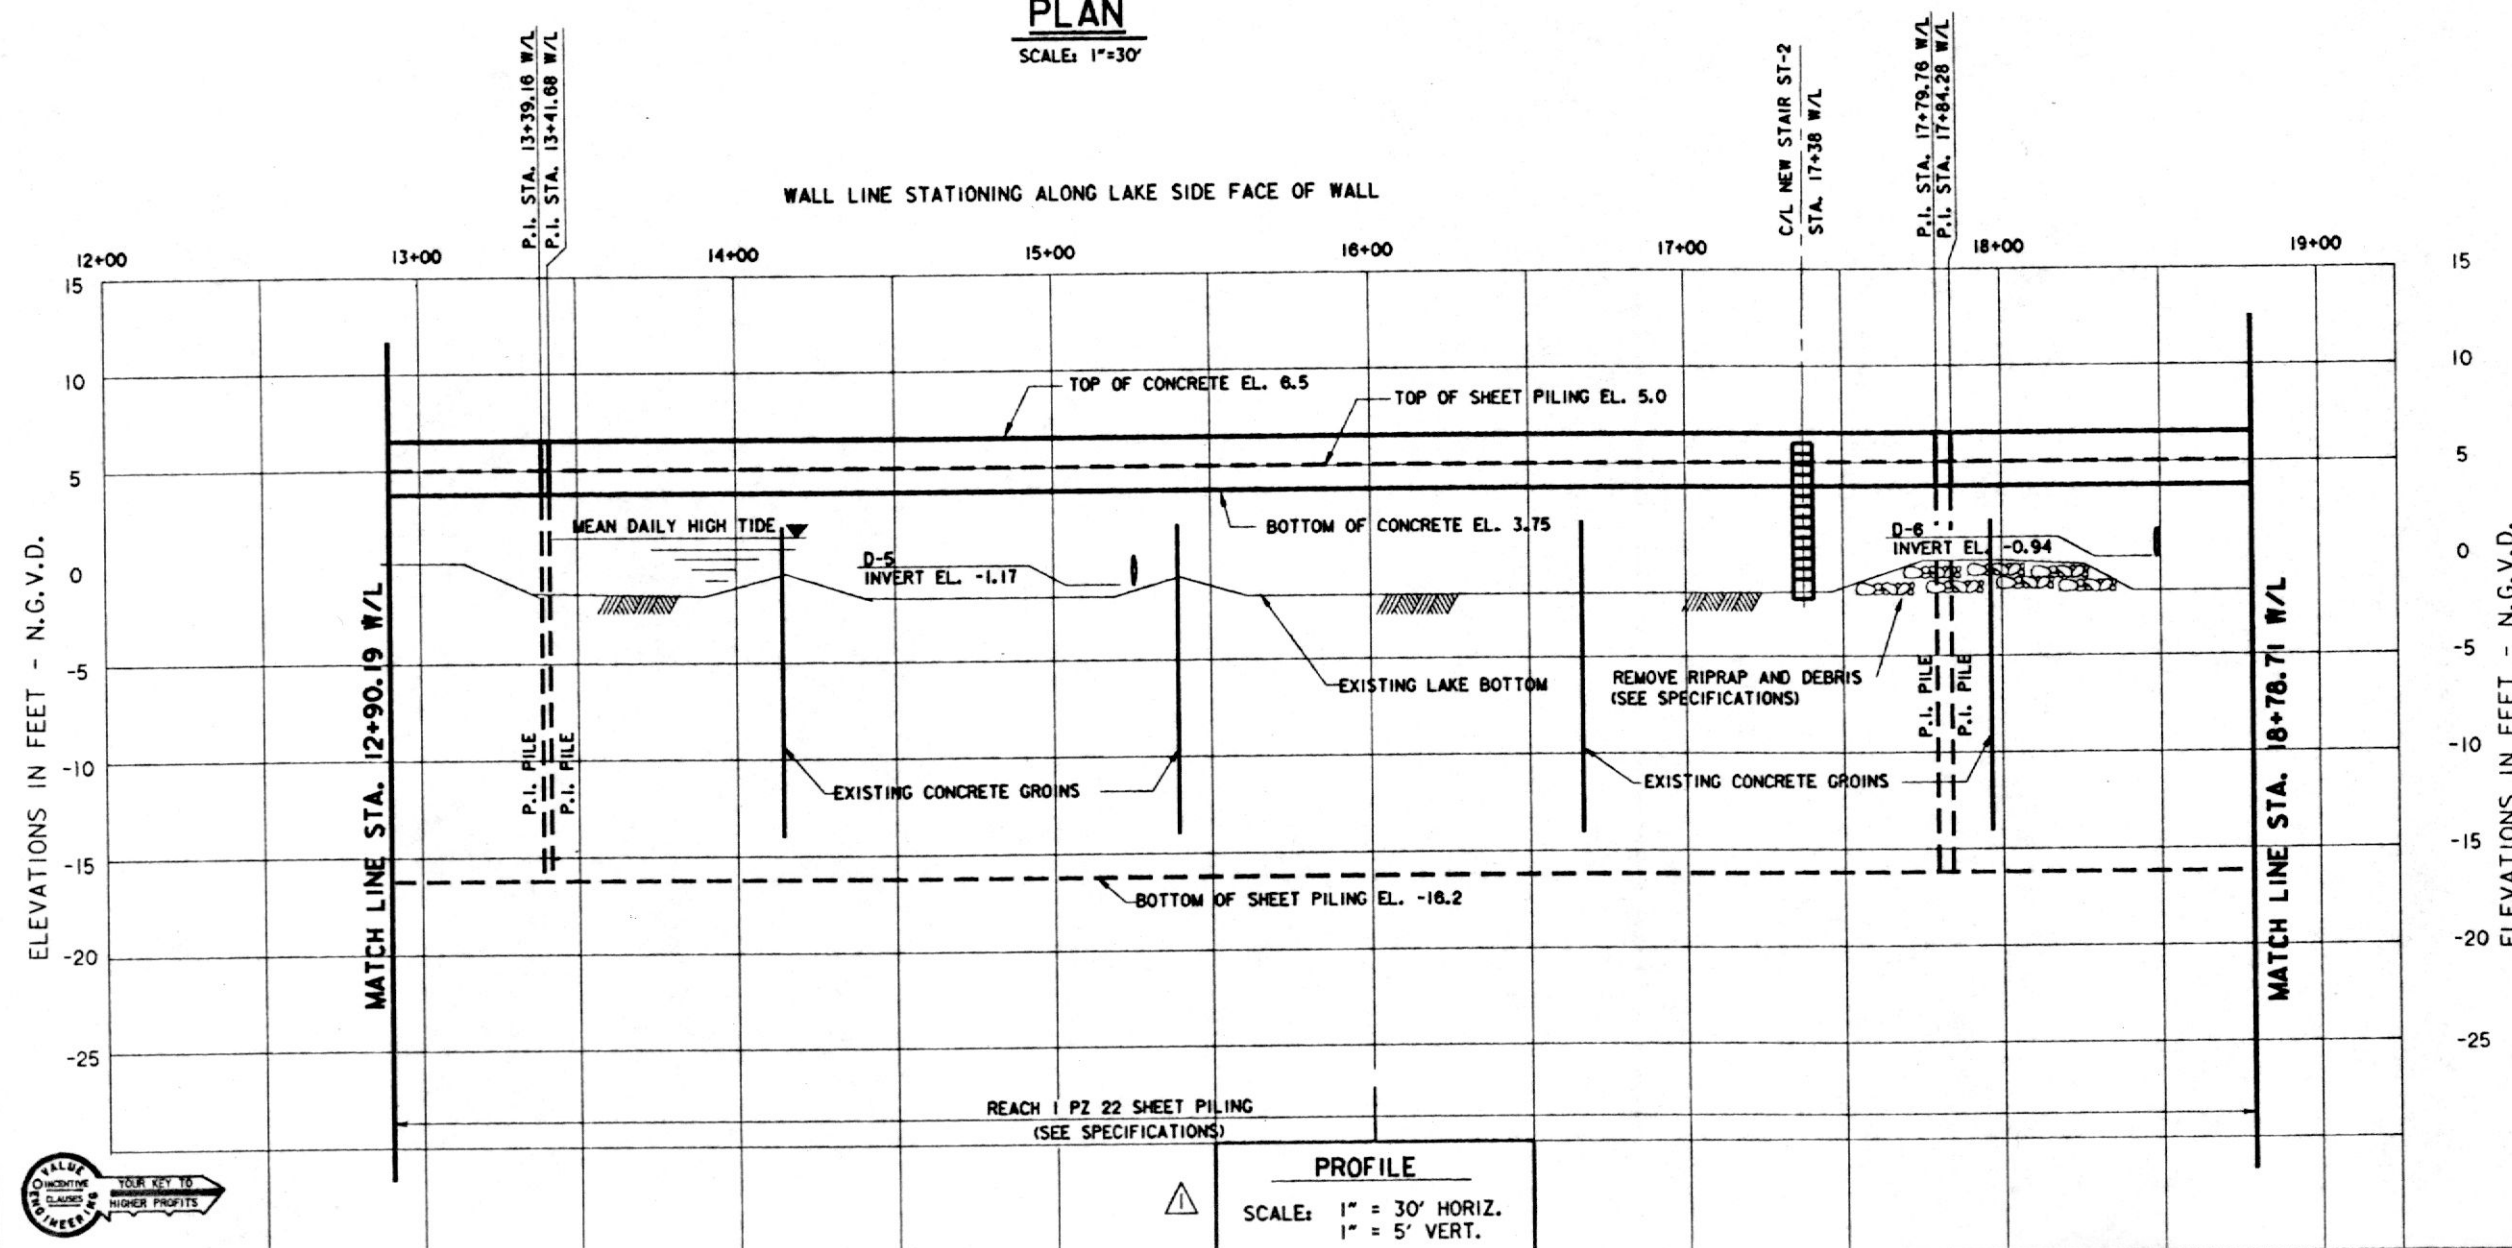

| WALL LINE DATA |                     |                           |     |                      |
|----------------|---------------------|---------------------------|-----|----------------------|
| P.I.<br>NO.    | BASELINE<br>STATION | DISTANCE FROM<br>BASELINE |     | WALL LINE<br>STATION |
| 13             | 110+40.00           | 66.04                     | RT. | 12+90.19             |
| 14             | 110+88.44           | 73.18                     | RT. | 13+39.16             |
| 15             | 110+87.90           | 75.65                     | RT. | 13+41.68             |
| 16             | 115+21.97           | 134.72                    | RT. | 17+79.76             |
| 17             | 115+22.37           | 130.21                    | RT. | 17+84.28             |
| 18             | 116+16              | 142.45                    | RT. | 18+78.71             |

| CONSTRUCTION<br>SERVIDUTE |                |                                  | TEMPORARY<br>CONSTRUCTION<br>SERVIDUTE |                |                                  |
|---------------------------|----------------|----------------------------------|----------------------------------------|----------------|----------------------------------|
| LAND SIDE                 |                |                                  | LAKE SIDE                              |                |                                  |
| P.I.<br>NO.               | B/L<br>STATION | DISTANCE<br>MEASURED<br>FROM B/L | P.I.<br>NO.                            | B/L<br>STATION | DISTANCE<br>MEASURED<br>FROM B/L |
| 109                       | 110+40.0       | 29.0' RT.                        | 309                                    | 110+40.0       | 84.3' RT.                        |
| 110                       | 114+17.1       | 72.4' RT.                        | 310                                    | 116+16.0       | 161.8' RT.                       |
| 111                       | 113+98.9       | 26.5' LT.                        |                                        |                |                                  |
| 112                       | 114+29.4       | 26.6' LT.                        |                                        |                |                                  |
| 113                       | 114+48.2       | 75.9' RT.                        |                                        |                |                                  |
| 114                       | 116+16.0       | 99.6' RT.                        |                                        |                |                                  |

| EXISTING FACILITIES |                          |                         |                    |               |
|---------------------|--------------------------|-------------------------|--------------------|---------------|
| ITEM                | DESCRIPTION              | B/L STATION             | OWNER              | DISPOSITION   |
| ST-2                | CONCRETE STEPS           | 114+80                  | CITY OF MANDEVILLE | CONTR. REMOVE |
| W-1                 | 8" WATER MAIN            | 114+04.2 TO<br>114+35.0 | CITY OF MANDEVILLE | NOT AFFECTED  |
| FM-1                | 6" SEWER FORCE MAIN      | 114+01.8 TO<br>114+31.6 | CITY OF MANDEVILLE | NOT AFFECTED  |
| DL-3                | 24" CLAY PIPE DRAIN LINE | 115+87.1                | CITY OF MANDEVILLE | CONTR. RELOC. |

\* CONTRACTOR NOT TO DISTURB

**000** DENOTES CONSTRUCTION SERVITUDE P.I. NUMBERS


⑥ DENOTES WALL LINE P.I. NUMBERS

**NOTES:**

 1. FOR GENERAL NOTES, SEE DWG. 2
2. FOR LEGEND, SEE DWG. 3
3. FOR GROIN MODIFICATIONS, SEE DWG. 24
4. FOR WALL TRANSITION DETAILS, SEE DWG. 25
5. FOR DRAIN DETAILS, SEE DWG. 26
6. FOR STAIR DETAILS, SEE DWG. 27
7. FOR SOIL BORING LOGS SEE DWG. 30
8. FOR LAKE HYDROGRAPH SEE DWG. 31
9. STAKES AND GUY WIRES AROUND SMALL TREES NOT SHOWN. CONTRACTOR TO MAINTAIN.
10. EXTENT OF RIPRAP ON LAKE BOTTOM AND DEBRIS BEHIND WALL MAY VARY FROM THAT SHOWN.

THIS PLAN ACCOMPANIES  
MODIFICATION P0000  
TO CONTRACT NUMBER  
DACW29-94-C-0031

SCALE: 1" = 30'



SCALE: 1" = 5'




|                                                                                               |                                                                                                                                                        |                    |                         |
|-----------------------------------------------------------------------------------------------|--------------------------------------------------------------------------------------------------------------------------------------------------------|--------------------|-------------------------|
|          | REVISED TOP OF WALL AND SHEET PILING IN<br>PROFILE; MOD.                                                                                               | 4-5-94             | W.O.B.                  |
|                                                                                               | SYMBOL                                                                                                                                                 | DESCRIPTION        | DATE                    |
| REVISIONS                                                                                     |                                                                                                                                                        |                    |                         |
|          | U. S. ARMY ENGINEER DISTRICT, NEW ORLEANS<br>CORPS OF ENGINEERS<br>NEW ORLEANS, LOUISIANA                                                              |                    |                         |
|                                                                                               |  Brown Cunningham Gannuch<br>ENGINEERS • ARCHITECTS • CONSULTANTS |                    |                         |
| MANDEVILLE SEAWALL, LA.<br>REPLACEMENT OF MANDEVILLE SEAWALL<br>ST. TAMMANY PARISH, LOUISIANA |                                                                                                                                                        |                    |                         |
| PLAN AND PROFILE<br>STA. 17+90.19 W/L TO STA. 18+78.71 W/L                                    |                                                                                                                                                        |                    |                         |
| DESIGNED BY: R.W.Y.<br>DRAWN BY: J.S.B<br>CHECKED BY: T.P.H.                                  | DATE:<br>NOV. 1993                                                                                                                                     | PLOT SCALE:<br>360 | PLOT DATE:<br>NOV. 1993 |
| SUBMITTED BY:<br>ROBERT W. YOKUM, P.E.<br>DISTRICT ENGINEER                                   | CADDO FILES: 40335-05.DWG                                                                                                                              |                    | FILE NO.<br>H-4-40335   |
|                                                                                               | SOLICITATION NO.<br>DAC29-94-B-0024                                                                                                                    |                    | DWG. 5 OF 31            |





Safety is a Part  
of Your Contract

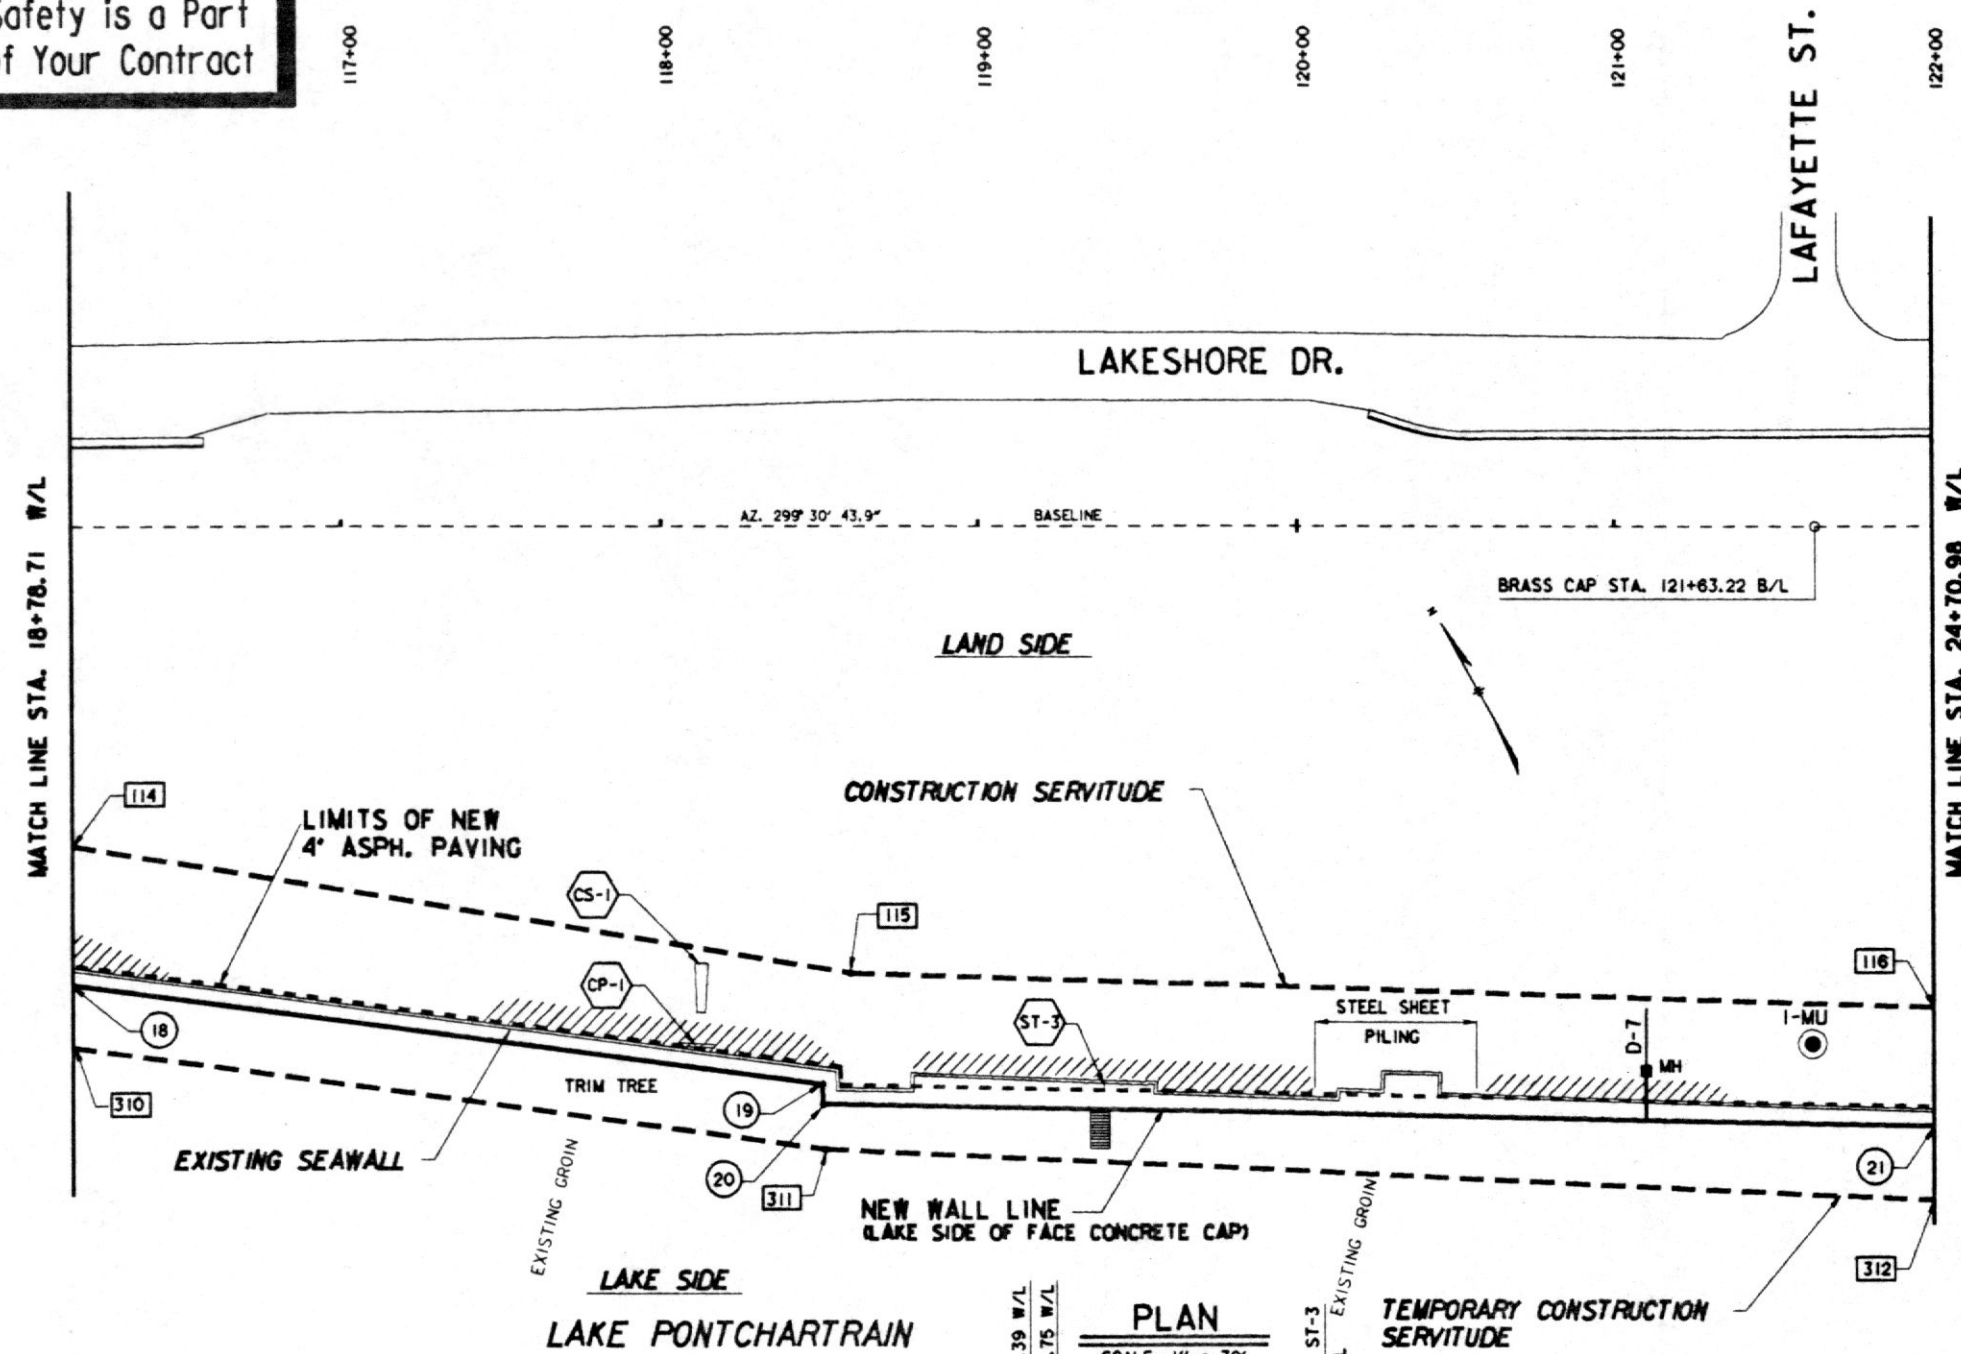STATIONING ALONG PROJECT BASELINE



| WALL LINE DATA |                 |                       |                   |  |
|----------------|-----------------|-----------------------|-------------------|--|
| P.I. NO.       | BASLINE STATION | DISTANCE FROM BASLINE | WALL LINE STATION |  |
| 18             | 116 + 16.00     | 142.45 RT.            | 18 + 78.71        |  |
| 19             | 118 + 50.68     | 173.16 RT.            | 21 + 15.39        |  |
| 20             | 118 + 50.84     | 179.52 RT.            | 21 + 21.75        |  |
| 21             | 122 + 00.00     | 186.16 RT.            | 24 + 70.98        |  |


| CONSTRUCTION SERVITUDE |             |                            | TEMPORARY CONSTRUCTION SERVITUDE |             |                            |
|------------------------|-------------|----------------------------|----------------------------------|-------------|----------------------------|
| LAND SIDE              |             |                            | LAKE SIDE                        |             |                            |
| P.I. NO.               | B/L STATION | DISTANCE MEASURED FROM B/L | P.I. NO.                         | B/L STATION | DISTANCE MEASURED FROM B/L |
| 114                    | 116+16.0    | 99.6' RT.                  | 310                              | 116+16.0    | 161.8' RT.                 |
| 115                    | 118+59.7    | 138.8' RT.                 | 311                              | 118+51.5    | 193.5' RT.                 |
| 116                    | 122+00.0    | 149.3' RT.                 | 312                              | 122+00.0    | 209.2' RT.                 |

| EXISTING FACILITIES |                |             |                    |               |
|---------------------|----------------|-------------|--------------------|---------------|
| ITEM                | DESCRIPTION    | B/L STATION | OWNER              | DISPOSITION   |
| CP-1                | CONCRETE PIER  | 118+10.5    | CITY OF MANDEVILLE | CONTR. REMOVE |
| CS-1                | CONCRETE SLAB  | 118+12.1    | CITY OF MANDEVILLE | CONTR. REMOVE |
| ST-3                | CONCRETE STEPS | 119+37.8    | CITY OF MANDEVILLE | CONTR. REMOVE |


- 000 DENOTES CONSTRUCTION SERVITUDE NUMBERS  
6 DENOTES WALL LINE P.I. NUMBERS

#### NOTES:

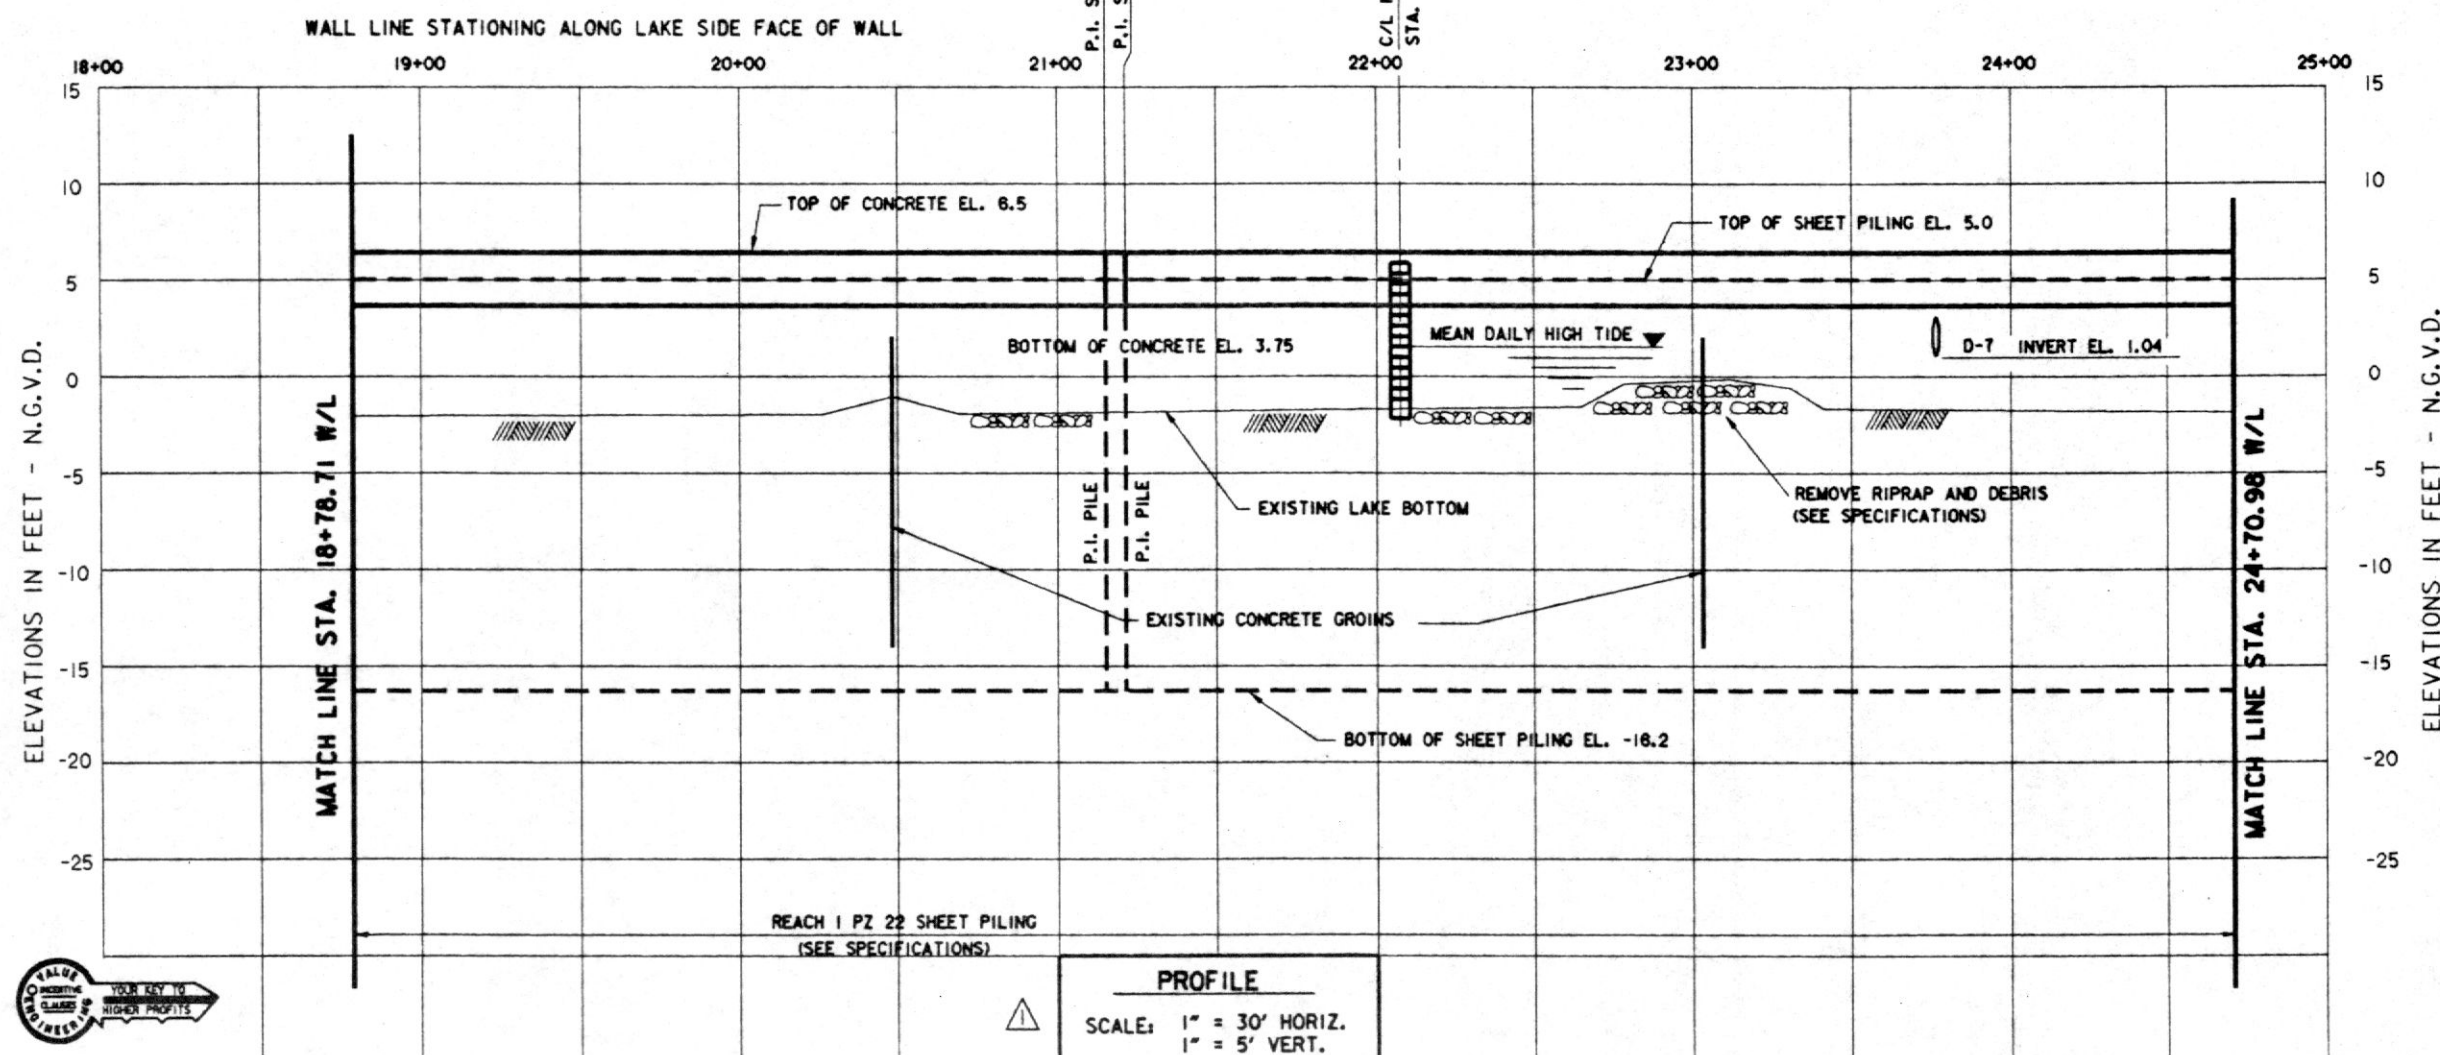- FOR GENERAL NOTES, SEE DWG. 2
- FOR LEGEND, SEE DWG. 3
- FOR GROIN MODIFICATIONS, SEE DWG. 24
- FOR WALL TRANSITION DETAILS, SEE DWG. 25
- FOR DRAIN DETAILS, SEE DWG. 26
- FOR STAIR DETAILS, SEE DWG. 27
- FOR SOIL BORING LOGS, SEE DWG. 30
- FOR LAKE HYDROGRAPH, SEE DWG. 31
- STAKES AND GUY WIRES AROUND SMALL TREES NOT SHOWN. CONTRACTOR TO MAINTAIN.
- EXTENT OF RIPRAP ON LAKE BOTTOM AND DEBRIS BEHIND WALL MAY VARY FROM THAT SHOWN.



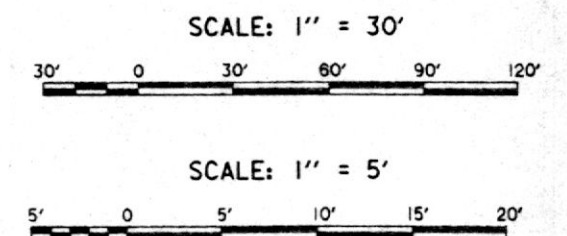THIS PLAN ACCOMPANIES  
MODIFICATION P0000  
TO CONTRACT NUMBER  
DACW29-94-C-0031



| REVISIONS                                                                                                                                                         |                                                      | DATE                              | APPROVED             |
|-------------------------------------------------------------------------------------------------------------------------------------------------------------------|------------------------------------------------------|-----------------------------------|----------------------|
| Δ                                                                                                                                                                 | REVISED TOP OF WALL AND SHEET PILING IN PROFILE MOD. | 4-5-94                            | W.O.B.               |
| SYMBOL DESCRIPTION                                                                                                                                                |                                                      |                                   |                      |
| U. S. ARMY ENGINEER DISTRICT, NEW ORLEANS<br>CORPS OF ENGINEERS<br>NEW ORLEANS, LOUISIANA                                                                         |                                                      |                                   |                      |
| Brown Cunningham Gannuch<br>ENGINEERS • ARCHITECTS • CONSULTANTS<br>MANDEVILLE SEAWALL, LA.<br>REPLACEMENT OF MANDEVILLE SEAWALL<br>ST. TAMMANY PARISH, LOUISIANA |                                                      |                                   |                      |
| PLAN AND PROFILE<br>STA. 18+78.71 W/L TO STA. 24+70.98 W/L                                                                                                        |                                                      |                                   |                      |
| DESIGNED BY: R.W.Y.                                                                                                                                               | DATE: NOV. 1993                                      | PLOT SCALE: 360                   | PLOT DATE: NOV. 1993 |
| DRAWN BY: S.F.S.                                                                                                                                                  | CADD FILE: 40335-04-000                              | FILE NO. H-4-40335                |                      |
| CHECKED BY: T.P.H.                                                                                                                                                | SUBMITTED BY: ROBERT W. YOKUM, P.E.                  | SOLICITATION NO. DACW29-94-B-0024 |                      |
| DESIGN ENGINEER                                                                                                                                                   |                                                      | DWG. 6 OF 31                      |                      |



Safety is a Part  
of Your Contract

STATIONING ALONG PROJECT BASELINE

123+00 124+00 125+00 126+00 127+00 128+00

LAKESHORE DR.

CONSTRUCTION ACCESS

CONSTRUCTION SERVITUDE

LAND SIDE

LIMITS OF NEW 4' ASPH. PAVING

EXISTING SEAWALL

NEW WALL LINE (LAKE SIDE FACE OF CONCRETE CAP)

LAKE SIDE

EXISTING GROIN

LAKE PONTCHARTRAIN

PLAN

SCALE: 1" = 30'

WALL LINE STATIONING ALONG LAKE SIDE FACE OF WALL

24+00 25+00 26+00 27+00 28+00 29+00 30+00 31+00 32+00

TOP OF SHEET PILING EL. 5.0

TOP OF CONCRETE EL. 6.5

BOTTOM OF CONCRETE EL. 3.75

EXISTING LAKE BOTTOM

EXISTING CONCRETE GROINS

BOTTOM OF SHEET PILING EL. -16.2

REACH 1 PZ 22 SHEET PILING (SEE SPECIFICATIONS)

PROFILE

SCALE: 1" = 30' HORIZ.  
1" = 5' VERT.

ELEVATIONS IN FEET - N.G.V.D.

24+00 25+00 26+00 27+00 28+00 29+00 30+00 31+00 32+00

15 10 5 0 -5 -10 -15 -20 -25

MATCH LINE STA. 24+70.98 W/L

MATCH LINE STA. 31+17.61 W/L

THIS PLAN ACCOMPANIES  
MODIFICATION 0000  
TO CONTRACT NUMBER  
DACW29-94-C-0031

WALL LINE DATA

| P.I. NO. | BASELINE STATION | DISTANCE FROM BASELINE | WALL LINE STATION |
|----------|------------------|------------------------|-------------------|
| 21       | 122+00.00        | 186.16                 | RT. 24+70.98      |
| 22       | 122+64.47        | 188.24                 | RT. 25+35.48      |
| 23       | 122+64.77        | 193.16                 | RT. 25+40.41      |
| 24       | 123+61.07        | 207.48                 | RT. 26+37.77      |
| 25       | 125+86.25        | 186.53                 | RT. 28+63.92      |
| 26       | 125+85.80        | 181.68                 | RT. 28+68.79      |
| 27       | 128+34.00        | 164.16                 | RT. 31+17.61      |

CONSTRUCTION SERVITUDE

| LAND SIDE |             |                            | LAKE SIDE |             |                            |
|-----------|-------------|----------------------------|-----------|-------------|----------------------------|
| P.I. NO.  | B/L STATION | DISTANCE MEASURED FROM B/L | P.I. NO.  | B/L STATION | DISTANCE MEASURED FROM B/L |
| 116       | 122+00.0    | 149.3' RT.                 | 312       | 122+00.0    | 209.2' RT.                 |
| 117       | 123+37.9    | 153.5' RT.                 | 313       | 123+61.1    | 216.5' RT.                 |
| 118       | 123+78.0    | 150.7' RT.                 | 314       | 128+34.0    | 191.1' RT.                 |
| 119       | 123+65.3    | 31.2' LT.                  |           |             |                            |
| 120       | 123+95.4    | 31.3' LT.                  |           |             |                            |
| 121       | 124+08.0    | 148.6' RT.                 |           |             |                            |
| 122       | 128+34.0    | 118.8' RT.                 |           |             |                            |

EXISTING FACILITIES

| ITEM   | DESCRIPTION         | B/L STATION          | OWNER              | DISPOSITION   |
|--------|---------------------|----------------------|--------------------|---------------|
| * FM-1 | 6" SEWER FORCE MAIN | 123+66.2 TO 123+96.3 | CITY OF MANDEVILLE | NOT AFFECTED  |
| ST-4   | CONCRETE STEPS      | 125+92.2             | CITY OF MANDEVILLE | CONTR. REMOVE |

\* CONTRACTOR NOT TO DISTURB

000 DENOTES CONSTRUCTION SERVITUDE P.I. NUMBERS

6 DENOTES WALL LINE P.I. NUMBERS

NOTES:

- FOR GENERAL NOTES, SEE DWG. 2
- FOR LEGEND, SEE DWG. 3
- FOR GROIN MODIFICATIONS, SEE DWG. 24
- FOR WALL TRANSITION DETAILS, SEE DWG. 25
- FOR DRAIN DETAILS, SEE DWG. 26
- FOR STAIR DETAILS, SEE DWG. 27
- FOR SOIL BORING LOGS SEE DWG. 30
- FOR LAKE HYDROGRAPH SEE DWG. 31
- STAKES AND GUY WIRES AROUND SMALL TREES NOT SHOWN. CONTRACTOR TO MAINTAIN.
- EXTENT OF RIPRAP ON LAKE BOTTOM AND DEBRIS BEHIND WALL MAY VARY FROM THAT SHOWN.

SCALE: 1" = 30'

30' 0 30' 60' 90' 120'

SCALE: 1" = 5'

5' 0 5' 10' 15' 20'

| SYMBOL | DESCRIPTION                                           | DATE   | APPROVED |
|--------|-------------------------------------------------------|--------|----------|
| △      | REVISED TOP OF WALL AND SHEET PILING IN PROFILE; MOD. | 4-5-94 | W.O.B.   |

U. S. ARMY ENGINEER DISTRICT, NEW ORLEANS  
CORPS OF ENGINEERS  
NEW ORLEANS, LOUISIANA

Brown Cunningham Gannuch  
ENGINEERS - ARCHITECTS - CONSULTANTS


MANDEVILLE SEAWALL, LA.  
REPLACEMENT OF MANDEVILLE SEAWALL  
ST. TAMMANY PARISH, LOUISIANA

PLAN AND PROFILE  
STA. 24+70.98 W/L TO STA. 31+17.61 W/L

|                                     |                    |                 |                      |
|-------------------------------------|--------------------|-----------------|----------------------|
| DESIGNED BY: R.W.Y.                 | DATE: NOV. 1993    | PLOT SCALE: 360 | PLOT DATE: NOV. 1993 |
| DRAWN BY: S.F.S.                    |                    |                 |                      |
| CHECKED BY: T.P.H.                  |                    |                 |                      |
| SUBMITTED BY: ROBERT W. YOKUM, P.E. | FILE NO. H-4-40335 |                 |                      |
| DESIGN ENGINEER                     | DACW29-94-B-0024   | DWG. 7 OF 31    |                      |



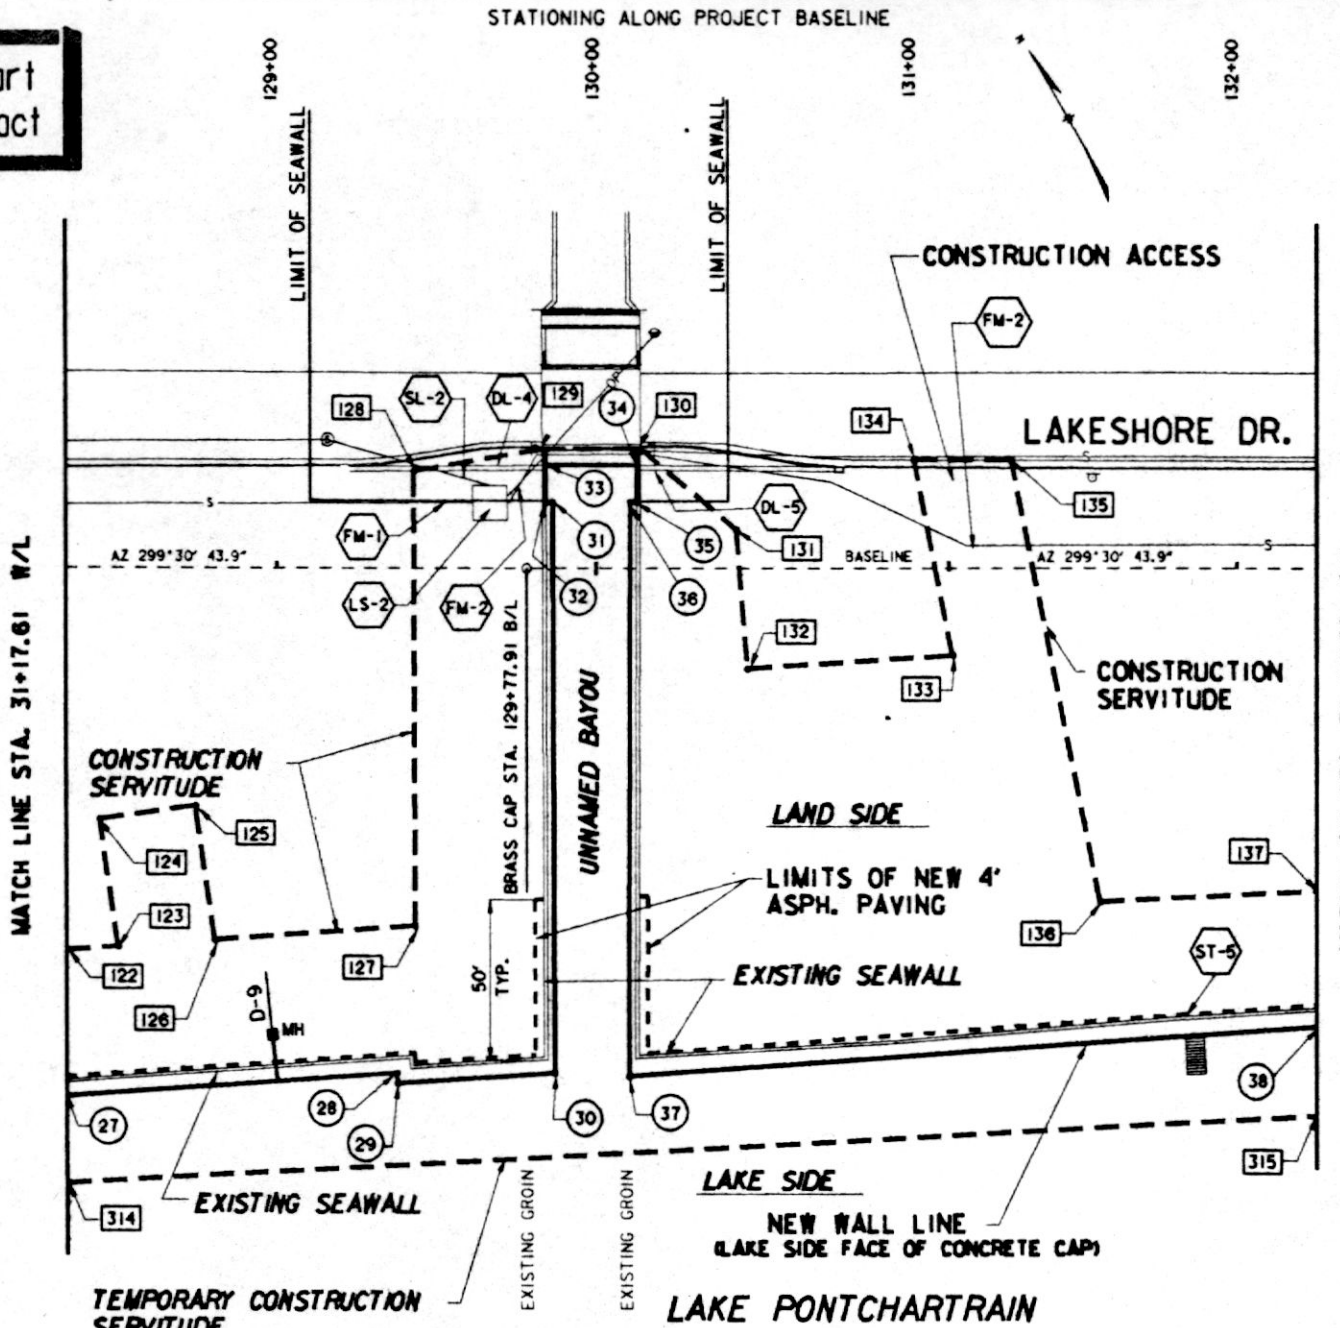
**Safety is a Part  
of Your Contract**



| WALL LINE DATA |                     |                           |     |                      |
|----------------|---------------------|---------------------------|-----|----------------------|
| P.I.<br>NO.    | BASELINE<br>STATION | DISTANCE FROM<br>BASELINE |     | WALL LINE<br>STATION |
| 27             | 128 + 34.00         | 164.16                    | RT. | 31 + 17.6            |
| 28             | 129 + 37.49         | 156.93                    | RT. | 32 + 21.35           |
| 29             | 129 + 37.64         | 160.01                    | RT. | 32 + 24.43           |
| 30             | 129 + 86.56         | 156.86                    | RT. | 32 + 73.46           |
| 31             | 129 + 86.06         | 20.50                     | LT. | 34 + 50.82           |
| 32             | 129 + 84.08         | 20.50                     | LT. | 34 + 52.82           |
| 33             | 129 + 84.05         | 31.96                     | LT. | 34 + 64.28           |
| 34             | 130 + 12.54         | 32.02                     | LT. | 34 + 92.77           |
| 35             | 130 + 12.50         | 20.52                     | LT. | 35 + 04.27           |
| 36             | 130 + 10.50         | 20.52                     | LT. | 35 + 06.27           |
| 37             | 130 + 09.93         | 157.81                    | RT. | 36 + 84.60           |
| 38             | 132 + 25.00         | 142.34                    | RT. | 39 + 00.22           |


| CONSTRUCTION<br>SERVITUDE |                |                                  | TEMPORARY<br>CONSTRUCTION<br>SERVITUDE |                |                                  |
|---------------------------|----------------|----------------------------------|----------------------------------------|----------------|----------------------------------|
| LAND SIDE                 |                |                                  | LAKE SIDE                              |                |                                  |
| P.I.<br>NO.               | B/L<br>STATION | DISTANCE<br>MEASURED<br>FROM B/L | P.I.<br>NO.                            | B/L<br>STATION | DISTANCE<br>MEASURED<br>FROM B/L |
| 122                       | 128+34.0       | 118.8' RT.                       | 314                                    | 128+34.0       | 191.1' RT.                       |
| 123                       | 128+50.1       | 117.7' RT.                       | 315                                    | 132+25.0       | 170.1' RT.                       |
| 124                       | 128+44.6       | 78.1' RT.                        |                                        |                |                                  |
| 125                       | 128+74.3       | 73.9' RT.                        |                                        |                |                                  |
| 126                       | 128+80.1       | 115.6' RT.                       |                                        |                |                                  |
| 127                       | 129+43.2       | 111.2' RT.                       |                                        |                |                                  |
| 128                       | 129+42.8       | 30.1' LT.                        |                                        |                |                                  |
| 129                       | 129+82.8       | 37.0' LT.                        |                                        |                |                                  |
| 130                       | 130+13.8       | 37.1' LT.                        |                                        |                |                                  |
| 131                       | 130+43.7       | 11.9' LT.                        |                                        |                |                                  |
| 132                       | 130+47.2       | 31.2' RT.                        |                                        |                |                                  |
| 133                       | 131+11.4       | 27.1' RT.                        |                                        |                |                                  |
| 134                       | 130+99.2       | 33.6' LT.                        |                                        |                |                                  |
| 135                       | 131+29.8       | 33.5' LT.                        |                                        |                |                                  |
| 136                       | 131+57.3       | 103.4' RT.                       |                                        |                |                                  |
| 137                       | 132+25.0       | 99.9' RT.                        |                                        |                |                                  |

| EXISTING FACILITIES |                       |                         |                    |               |
|---------------------|-----------------------|-------------------------|--------------------|---------------|
| ITEM                | DESCRIPTION           | B/L STATION             | OWNER              | DISPOSITION   |
| * FM-1              | 6" SEWER FORCE MAIN   | 129+42.8 TO<br>129+61   | CITY OF MANDEVILLE | NOT AFFECTED  |
| * SL-2              | 12" SEWER LINE        | 129+47.6 TO<br>129+65.7 | CITY OF MANDEVILLE | NOT AFFECTED  |
| * DL-4              | 18" RCP DRAIN LINE    | 129+47.6 TO<br>129+84.1 | CITY OF MANDEVILLE | NOT AFFECTED  |
| * LS-2              | SEWERAGE LIFT STATION | 129+66.4                | CITY OF MANDEVILLE | NOT AFFECTED  |
| FM-2                | 6" SEWER FORCE MAIN   | 129+72.6 TO<br>130+16   | CITY OF MANDEVILLE | NOT AFFECTED  |
| * DL-5              | 18" RCP DRAIN LINE    | 130+12.5 TO<br>130+20.7 | CITY OF MANDEVILLE | NOT AFFECTED  |
| * FM-2              | 6" SEWER FORCE MAIN   | 131+03.4 TO<br>131+35.1 | CITY OF MANDEVILLE | NOT AFFECTED  |
| ST-5                | CONCRETE STEPS        | 131+86.1                | CITY OF MANDEVILLE | CONTR. REMOVE |

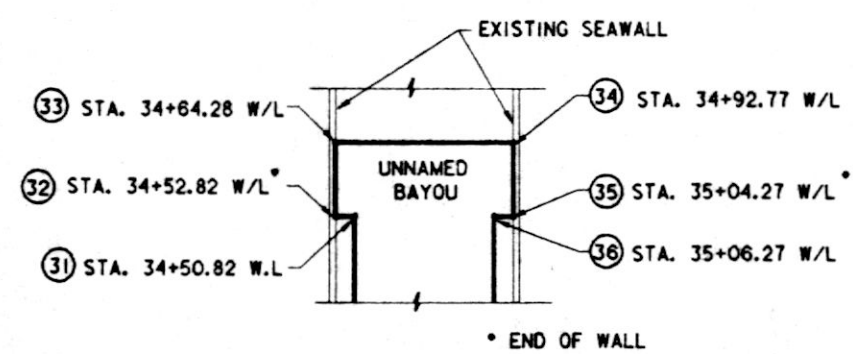

W/L STATIONING DETAIL

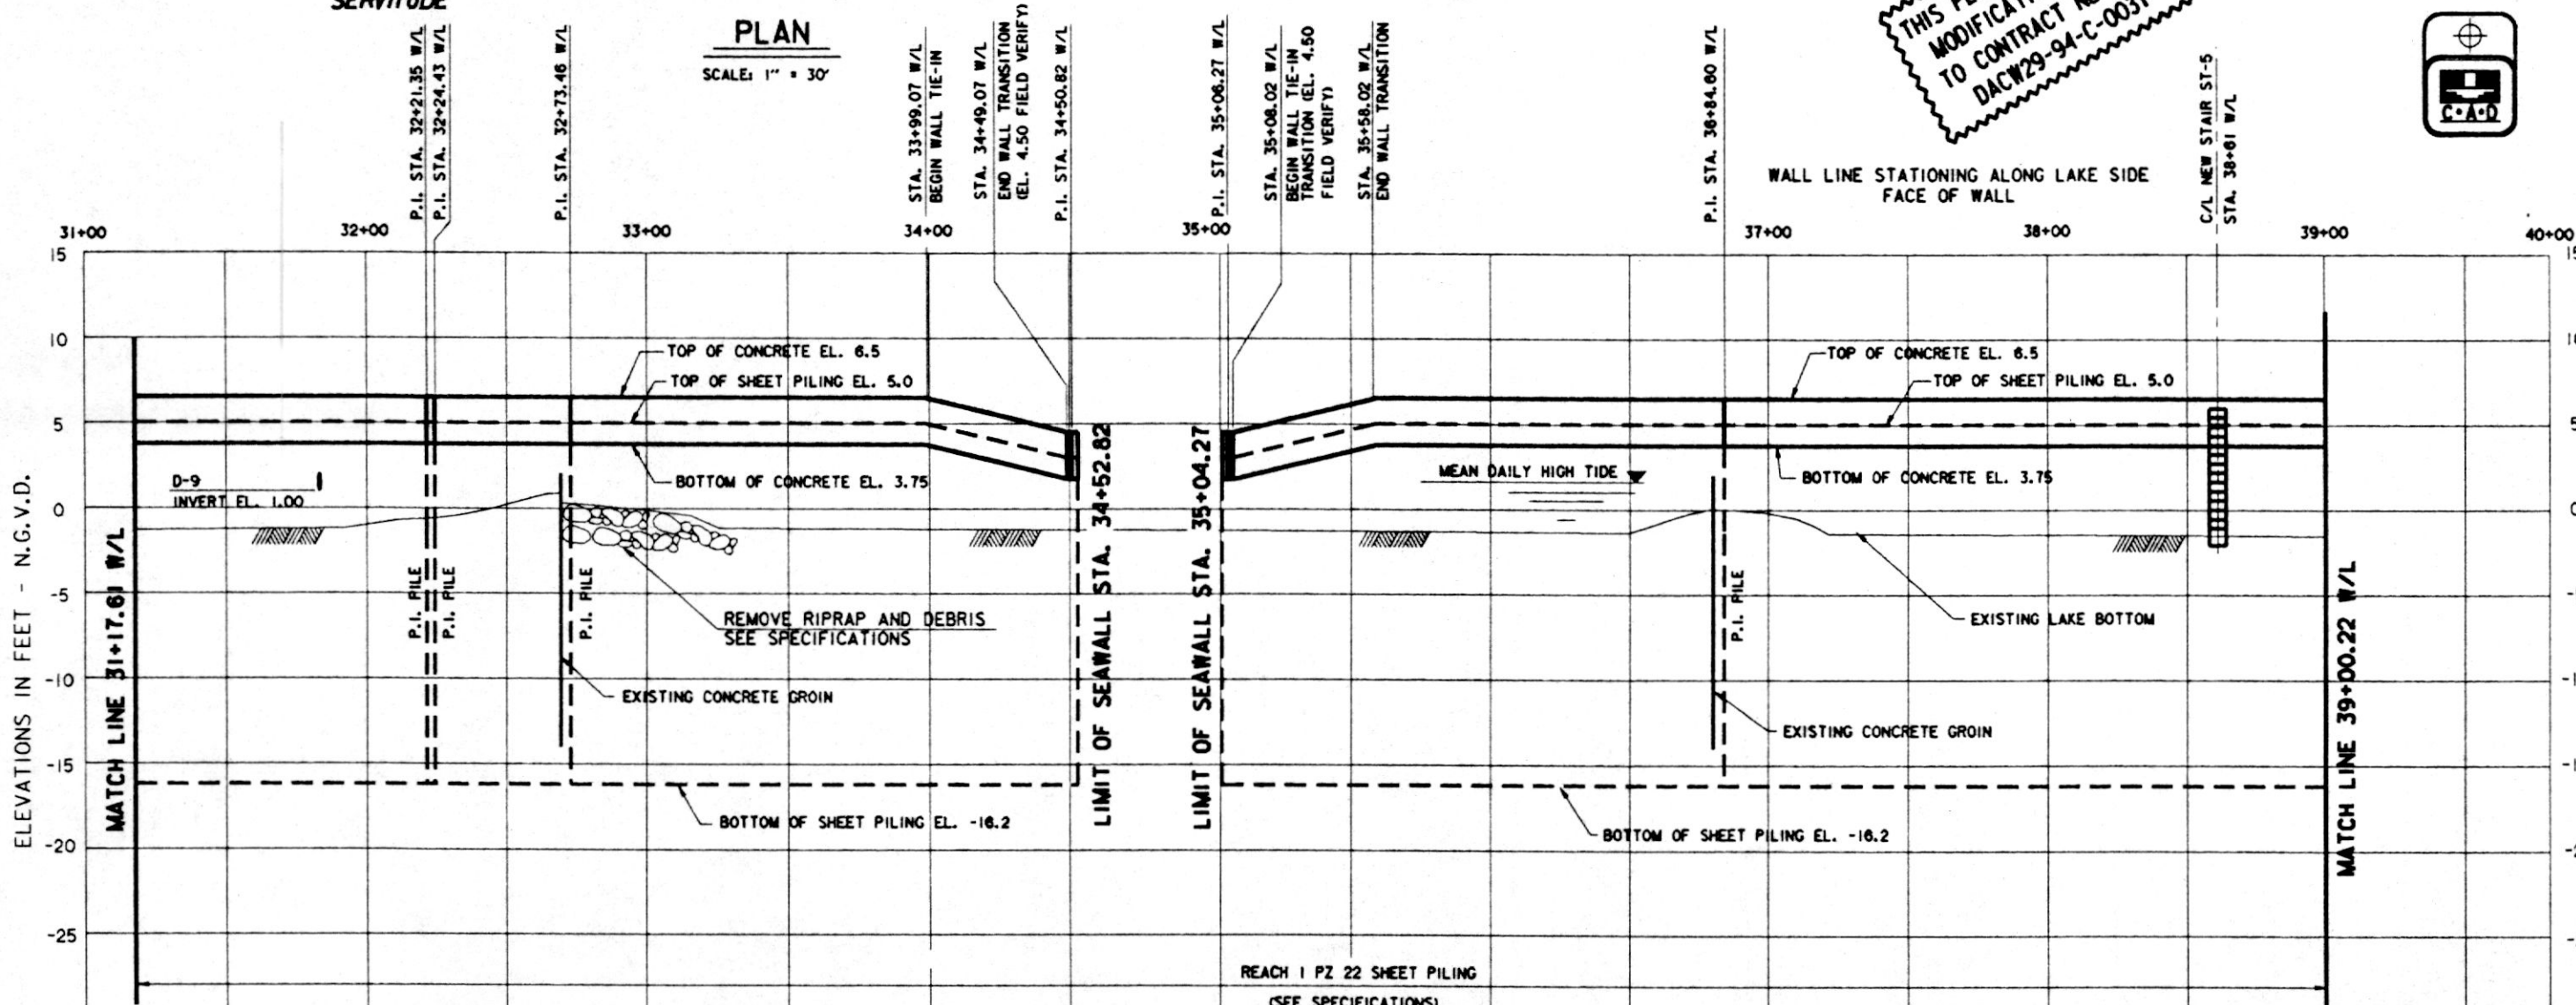**THIS PLAN ACCOMPANIES  
MODIFICATION P0000  
TO CONTRACT NUMBER  
DACW29-94-C-0031**



\* CONTRACTOR NOT TO DISTURB

**000** DENOTES CONSTRUCTION SERVITUDE P.I. NUMBERS


**6** DENOTES WALL LINE P.I. NUMBERS

**NOTES:**

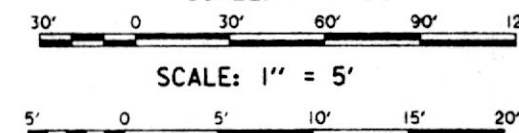1. FOR GENERAL NOTES, SEE DWG. 2
2. FOR LEGEND, SEE DWG. 3
3. FOR GROIN MODIFICATIONS, SEE DWG. 24
4. FOR WALL TRANSITION DETAILS, SEE DWG. 25
5. FOR DRAIN DETAILS, SEE DWG. 26
6. FOR STAIR DETAILS, SEE DWG. 27
7. FOR SOIL BORING LOGS, SEE DWG. 30
8. FOR LAKE HYDROGRAPH, SEE DWG. 31
9. STAKES AND GUY WIRES AROUND SMALL TREES NOT SHOWN. CONTRACTOR TO MAINTAIN.
10. EXTENT OF RIPRAP ON LAKE BOTTOM AND DEBRIS BEHIND WALL MAY VARY FROM THAT SHOWN.

SCALE: 1" = 30'

SCALE: 1" = 5'



|                                                                                       |                                                          |        |         |
|---------------------------------------------------------------------------------------|----------------------------------------------------------|--------|---------|
|                                                                                       |                                                          |        |         |
|  | REVISED TOP OF WALL AND SHEET PILING IN<br>PROFILE; MOD. | 4-5-94 | W.O.B.  |
| SYMBOL                                                                                | DESCRIPTION                                              | DATE   | APPROVE |

 U. S. ARMY ENGINEER DISTRICT, NEW ORLEANS  
CORPS OF ENGINEERS  
NEW ORLEANS, LOUISIANA

**Brown Cunningham Gannuch**  
ENGINEERS • ARCHITECTS • CONSULTANTS

MANDEVILLE SEAWALL, LA.  
REPLACEMENT OF MANDEVILLE SEAWALL  
ST. TAMMANY PARISH, LOUISIANA


PLAN AND PROFILE  
STA. 31+17.61 W/L TO STA. 39+00.22 W/L

|                                     |                                   |                 |                      |
|-------------------------------------|-----------------------------------|-----------------|----------------------|
| DESIGNED BY: R.W.Y.                 | DATE: NOV. 1993                   | PLOT SCALE: 360 | PLOT DATE: NOV. 1993 |
| DRAWN BY: J.S.B                     |                                   |                 |                      |
| CHECKED BY: T.P.H.                  | CADD FILE: 40335-08.DGN           |                 | FILE NO. H-4-40335   |
| SUBMITTED BY: ROBERT W. YOKUM, P.E. | SOLICITATION NO. DACW29-94-B-0024 |                 | DWG. 8 OF 31         |



Safety is a Part  
of Your Contract

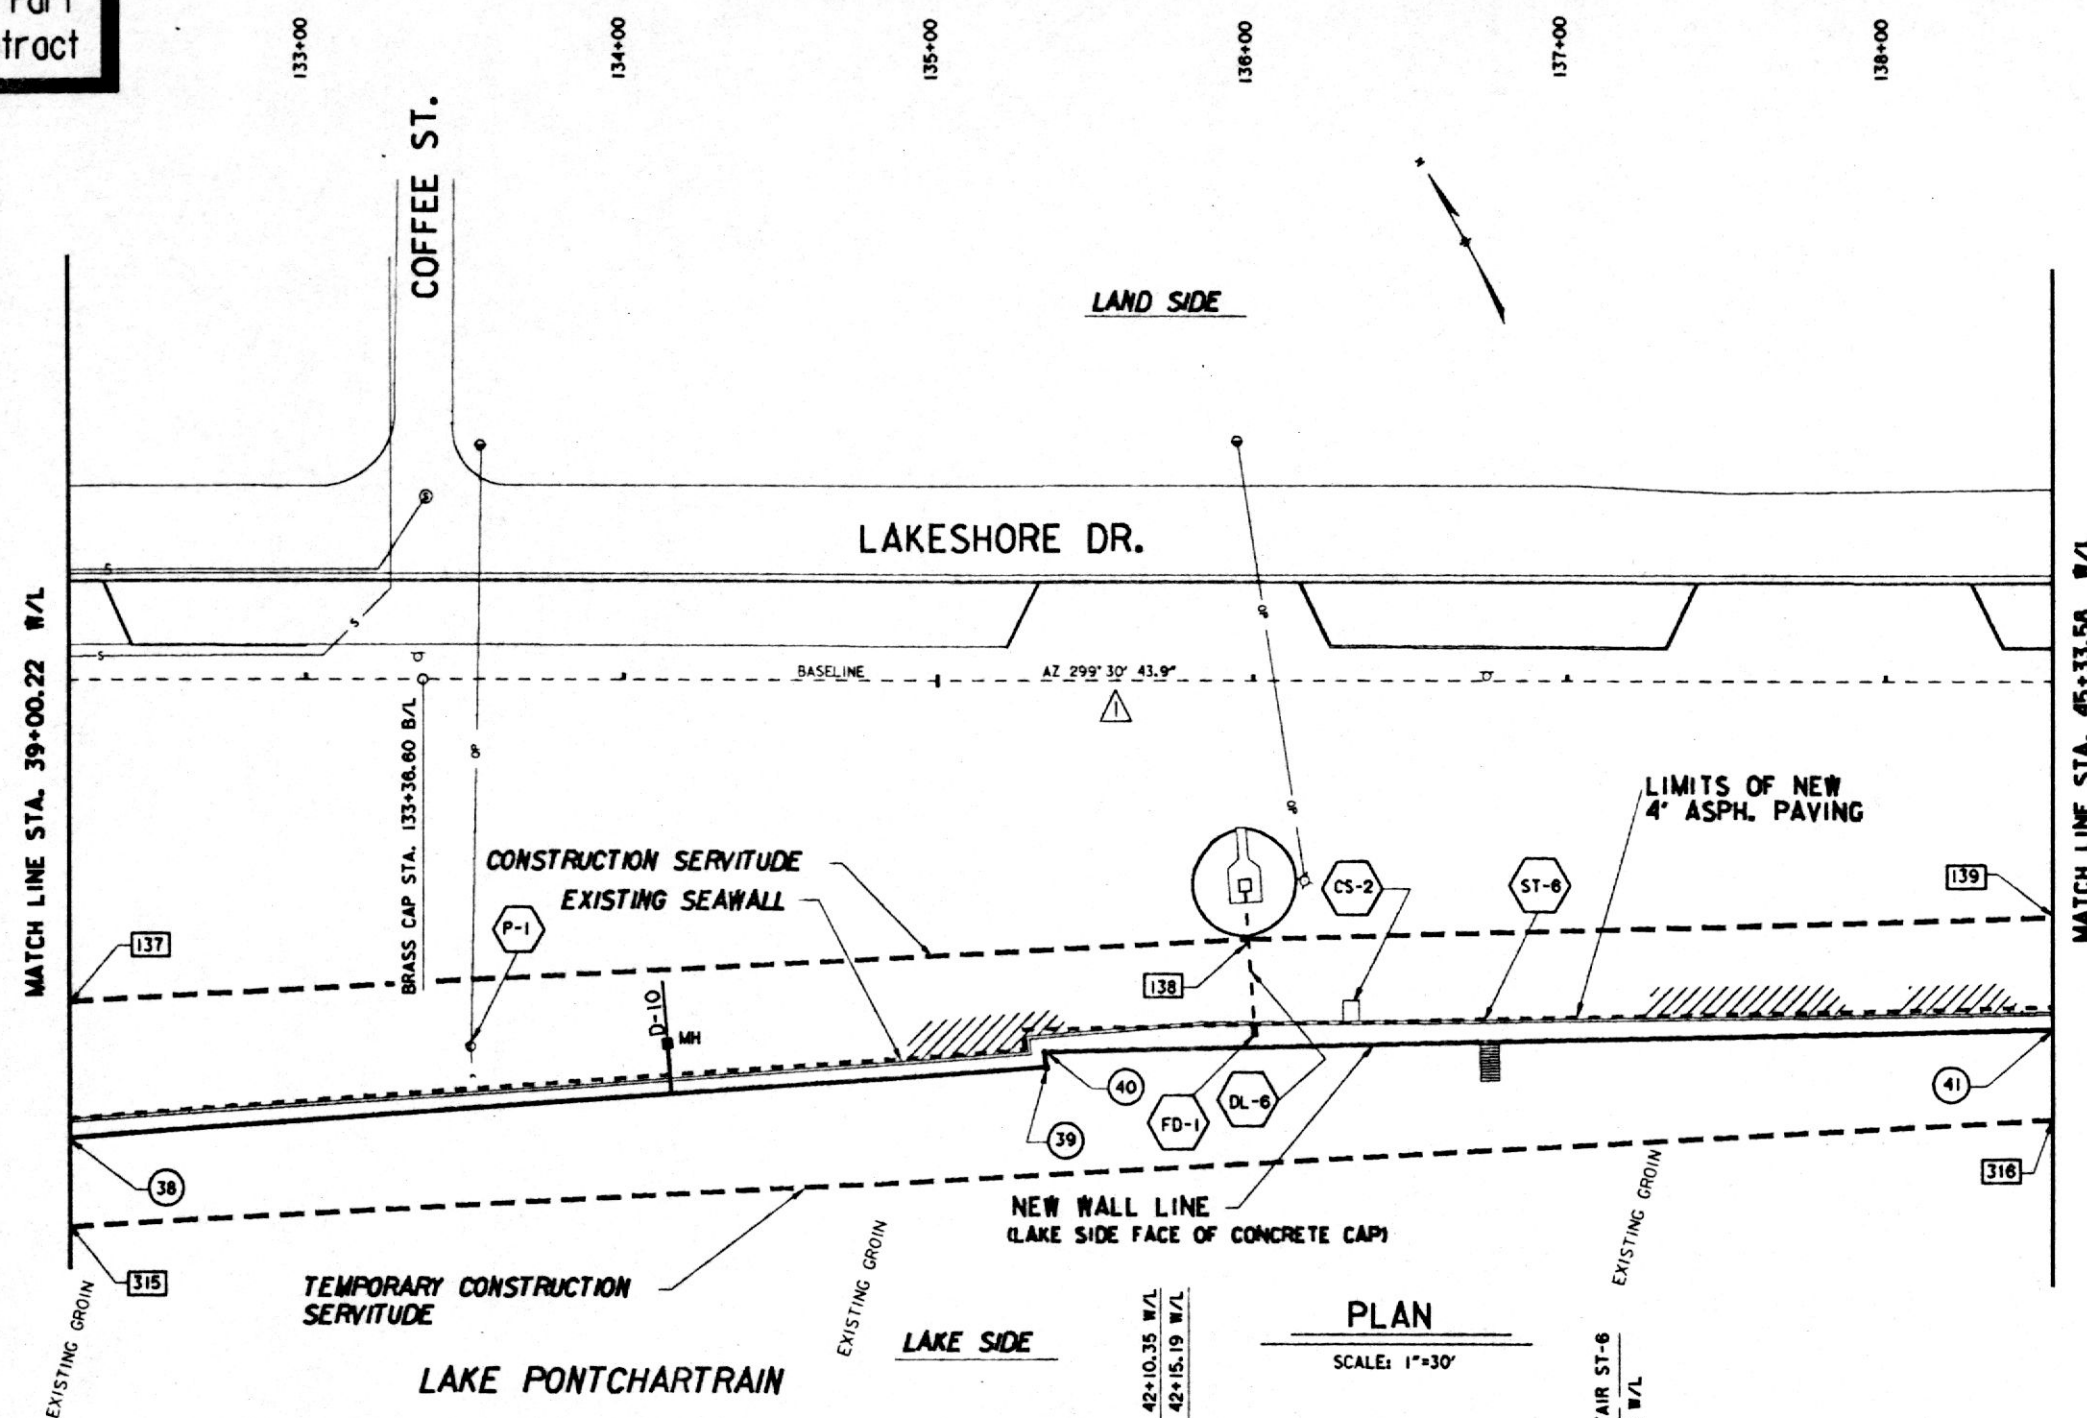STATIONING ALONG PROJECT BASELINE



| WALL LINE DATA |                  |                        |     |                   |
|----------------|------------------|------------------------|-----|-------------------|
| P.I. NO.       | BASELINE STATION | DISTANCE FROM BASELINE | RT. | WALL LINE STATION |
| 38             | 132 + 25.00      | 142.34                 | RT. | 39 + 00.22        |
| 39             | 135 + 34.33      | 120.09                 | RT. | 42 + 10.35        |
| 40             | 135 + 33.69      | 115.29                 | RT. | 42 + 15.19        |
| 41             | 138 + 52.00      | 108.17                 | RT. | 45 + 33.58        |

| CONSTRUCTION SERVITUDE |             |                            | TEMPORARY CONSTRUCTION SERVITUDE |             |                            |
|------------------------|-------------|----------------------------|----------------------------------|-------------|----------------------------|
| LAND SIDE              |             |                            | LAKE SIDE                        |             |                            |
| P.I. NO.               | B/L STATION | DISTANCE MEASURED FROM B/L | P.I. NO.                         | B/L STATION | DISTANCE MEASURED FROM B/L |
| 137                    | 132+25.0    | 99.9' RT.                  | 315                              | 132+25.0    | 170.1' RT.                 |
| 138                    | 135+98.0    | 80.8' RT.                  | 316                              | 138+52.0    | 136.4' RT.                 |
| 139                    | 138+52.0    | 73.4' RT.                  |                                  |             |                            |

| EXISTING FACILITIES |                                   |             |                    |               |
|---------------------|-----------------------------------|-------------|--------------------|---------------|
| ITEM                | DESCRIPTION                       | B/L STATION | OWNER              | DISPOSITION   |
| P-1                 | UTILITY POLE & GUY WIRE W/OP LINE | 133+51.5    | CLECO              | OWNER RELOC.  |
| DL-6                | 6" STEEL DRAIN LINE               | 135+98.8    | CITY OF MANDEVILLE | CONTR. RELOC. |
| CS-2                | CONCRETE SLAB                     | 136+31.2    | CITY OF MANDEVILLE | CONTR. REMOVE |
| ST-6                | CONCRETE STEPS                    | 136+74.8    | CITY OF MANDEVILLE | CONTR. REMOVE |


000 DENOTES CONSTRUCTION SERVITUDE P.I. NUMBERS

6 DENOTES WALL LINE P.I. NUMBERS



#### NOTES:

 - FOR GENERAL NOTES, SEE DWG. 2
- FOR LEGEND, SEE DWG. 3
- FOR GROIN MODIFICATIONS, SEE DWG. 24
- FOR WALL TRANSITION DETAILS, SEE DWG. 25
- FOR DRAIN DETAILS, SEE DWG. 26
- FOR STAIR DETAILS, SEE DWG. 27
- FOR SOIL BORING LOGS, SEE DWG. 30
- FOR LAKE HYDROGRAPH, SEE DWG. 31
- STAKES AND GUY WIRES AROUND SMALL TREES NOT SHOWN. CONTRACTOR TO MAINTAIN.
- EXTENT OF RIPRAP ON LAKE BOTTOM AND DEBRIS BEHIND WALL MAY VARY FROM THAT SHOWN.

SCALE: 1" = 30'



SCALE: 1" = 5'

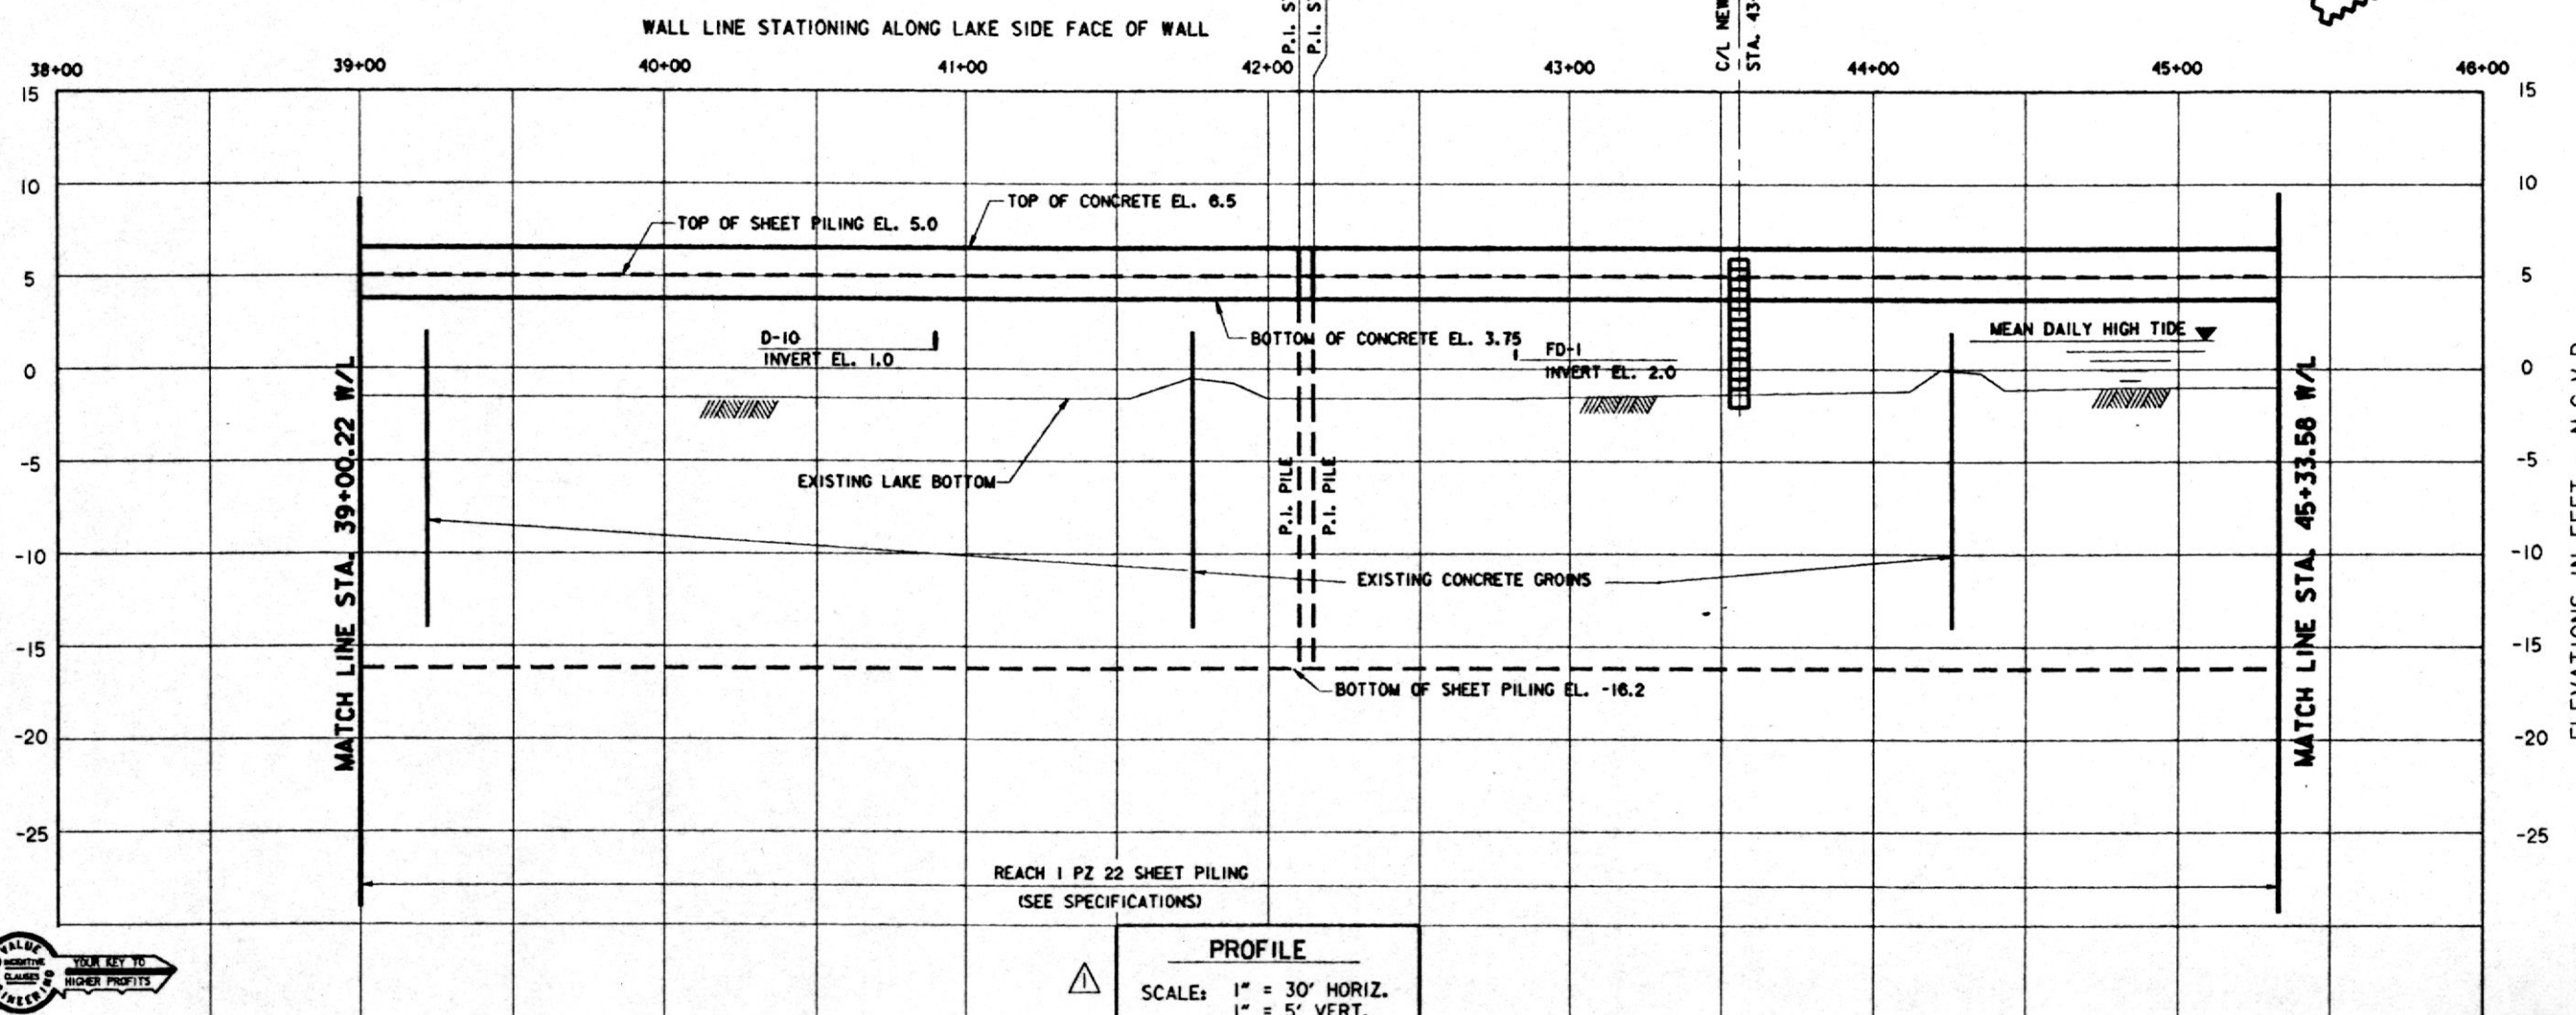 


THIS PLAN ACCOMPANIES  
MODIFICATION P0000  
TO CONTRACT NUMBER  
DACW29-94-C-0031

|                                                                                               |                                                                               |                     |                      |
|-----------------------------------------------------------------------------------------------|-------------------------------------------------------------------------------|---------------------|----------------------|
| REVISOR                                                                                       | REVISION                                                                      | DATE                | APPROVED             |
| 1                                                                                             | REVISED TOP OF WALL AND SHEET PILING IN PROFILE AND REVISED AZ. IN PLAN; MOD. | 4-5-94              | W.D.B.               |
| U. S. ARMY ENGINEER DISTRICT, NEW ORLEANS<br>CORPS OF ENGINEERS<br>NEW ORLEANS, LOUISIANA     |                                                                               |                     |                      |
| Brown Cunningham Gannuch<br>ENGINEERS • ARCHITECTS • CONSULTANTS                              |                                                                               |                     |                      |
| MANDEVILLE SEAWALL, LA.<br>REPLACEMENT OF MANDEVILLE SEAWALL<br>ST. TAMMANY PARISH, LOUISIANA |                                                                               |                     |                      |
| PLAN AND PROFILE<br>STA. 39+00.22 W/L TO STA. 45+33.58 W/L                                    |                                                                               |                     |                      |
| DESIGNED BY: R.W.Y.                                                                           | DATE: NOV. 1993                                                               | PLOT SCALE: 360     | PLOT DATE: NOV. 1993 |
| DRAWN BY: J.S.B.                                                                              | CADD FILE: 40335-09.DGN                                                       | FILE NO.: H-4-40335 |                      |
| CHECKED BY: T.P.H.                                                                            | SOLICITATION NO. DACW29-94-B-0024                                             | DWG. 9 OF 31        |                      |
| SUBMITTED BY: ROBERT W. YOKUM, P.E.<br>DESIGN ENGINEER                                        |                                                                               |                     |                      |



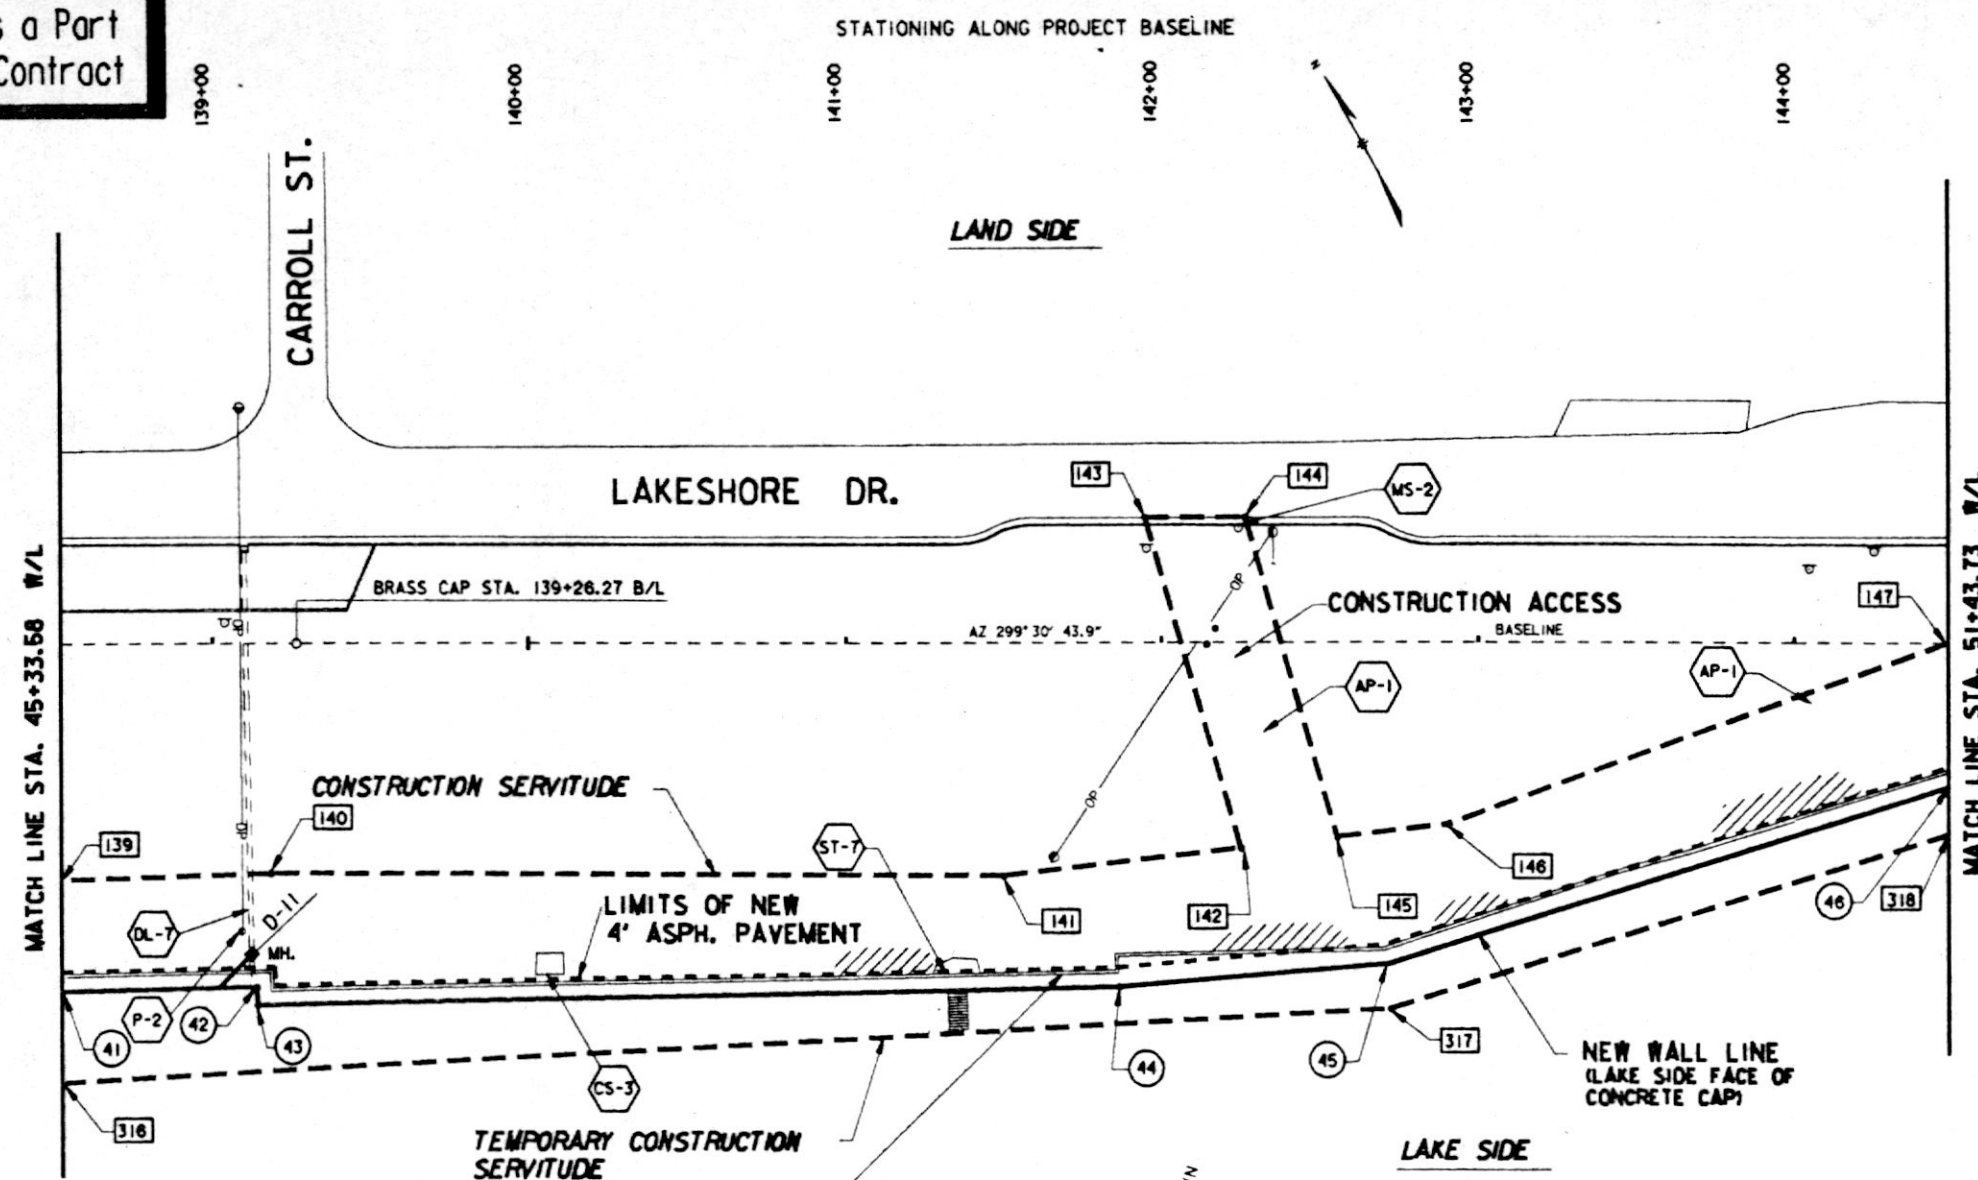**Safety is a Part  
of Your Contract**



| WALL LINE DATA |                  |                        |     |                   |
|----------------|------------------|------------------------|-----|-------------------|
|                | BASELINE STATION | DISTANCE FROM BASELINE |     | WALL LINE STATION |
| 41             | 138+52.00        | 108.17                 | RT. | 45+33.58          |
| 42             | 139+13.51        | 106.80                 | RT. | 45+95.11          |
| 43             | 139+13.66        | 112.40                 | RT. | 46+00.71          |
| 44             | 141+85.90        | 106.89                 | RT. | 48+73.01          |
| 45             | 142+70.70        | 99.90                  | RT. | 49+58.09          |
| 46             | 144+48.00        | 44.90                  | RT. | 51+43.73          |

| CONSTRUCTION<br>SERVITUDE |                |                                  | TEMPORARY<br>CONSTRUCTION<br>SERVITUDE |                |                                  |
|---------------------------|----------------|----------------------------------|----------------------------------------|----------------|----------------------------------|
| LAND SIDE                 |                |                                  | LAKE SIDE                              |                |                                  |
| P.I.<br>NO.               | B/L<br>STATION | DISTANCE<br>MEASURED<br>FROM B/L | P.I.<br>NO.                            | B/L<br>STATION | DISTANCE<br>MEASURED<br>FROM B/L |
| 139                       | 138+52.0       | 73.4' RT.                        | 316                                    | 138+52.0       | 136.4' RT.                       |
| 140                       | 139+18.1       | 71.5' RT.                        | 317                                    | 142+71.7       | 113.9' RT.                       |
| 141                       | 141+49.0       | 72.3' RT.                        | 318                                    | 144+48.0       | 59.6' RT.                        |
| 142                       | 142+24.6       | 63.8' RT.                        |                                        |                |                                  |
| 143                       | 141+94.8       | 38.7' LT.                        |                                        |                |                                  |
| 144                       | 142+26.0       | 38.7' LT.                        |                                        |                |                                  |
| 145                       | 142+54.9       | 60.5' RT.                        |                                        |                |                                  |
| 146                       | 142+90.3       | 56.5' RT.                        |                                        |                |                                  |
| 147                       | 144+48.0       | 0.0'                             |                                        |                |                                  |

| EXISTING FACILITIES |                          |                     |                    |               |
|---------------------|--------------------------|---------------------|--------------------|---------------|
| ITEM                | DESCRIPTION              | B/L STATION         | OWNER              | DISPOSITION   |
| ** AP-1             | ASPHALT PATH             | 142+14 TO<br>142+44 | CITY OF MANDEVILLE | TO REMAIN     |
| P-2                 | UTILITY POLE W/O P LINE  | 139+08.7            | CLECO              | OWNER RELOC.  |
| DL-7                | 24" CLAY PIPE DRAIN LINE | 139+18.6            | CITY OF MANDEVILLE | CONTR. RELOC. |
| CS-3                | CONCRETE SLAB            | 140+06.1            | CITY OF MANDEVILLE | CONTR. REMOVE |
| ST-7                | CONCRETE STEPS           | 141+35.2            | CITY OF MANDEVILLE | CONTR. REMOVE |
| MS-2                | METAL SIGN & POST        | 142+23.8            | CITY OF MANDEVILLE | OWNER RELOC.  |
| ** AP-1             | ASPHALT PATH             | 143+85 TO<br>144+48 | CITY OF MANDEVILLE | TO REMAIN     |

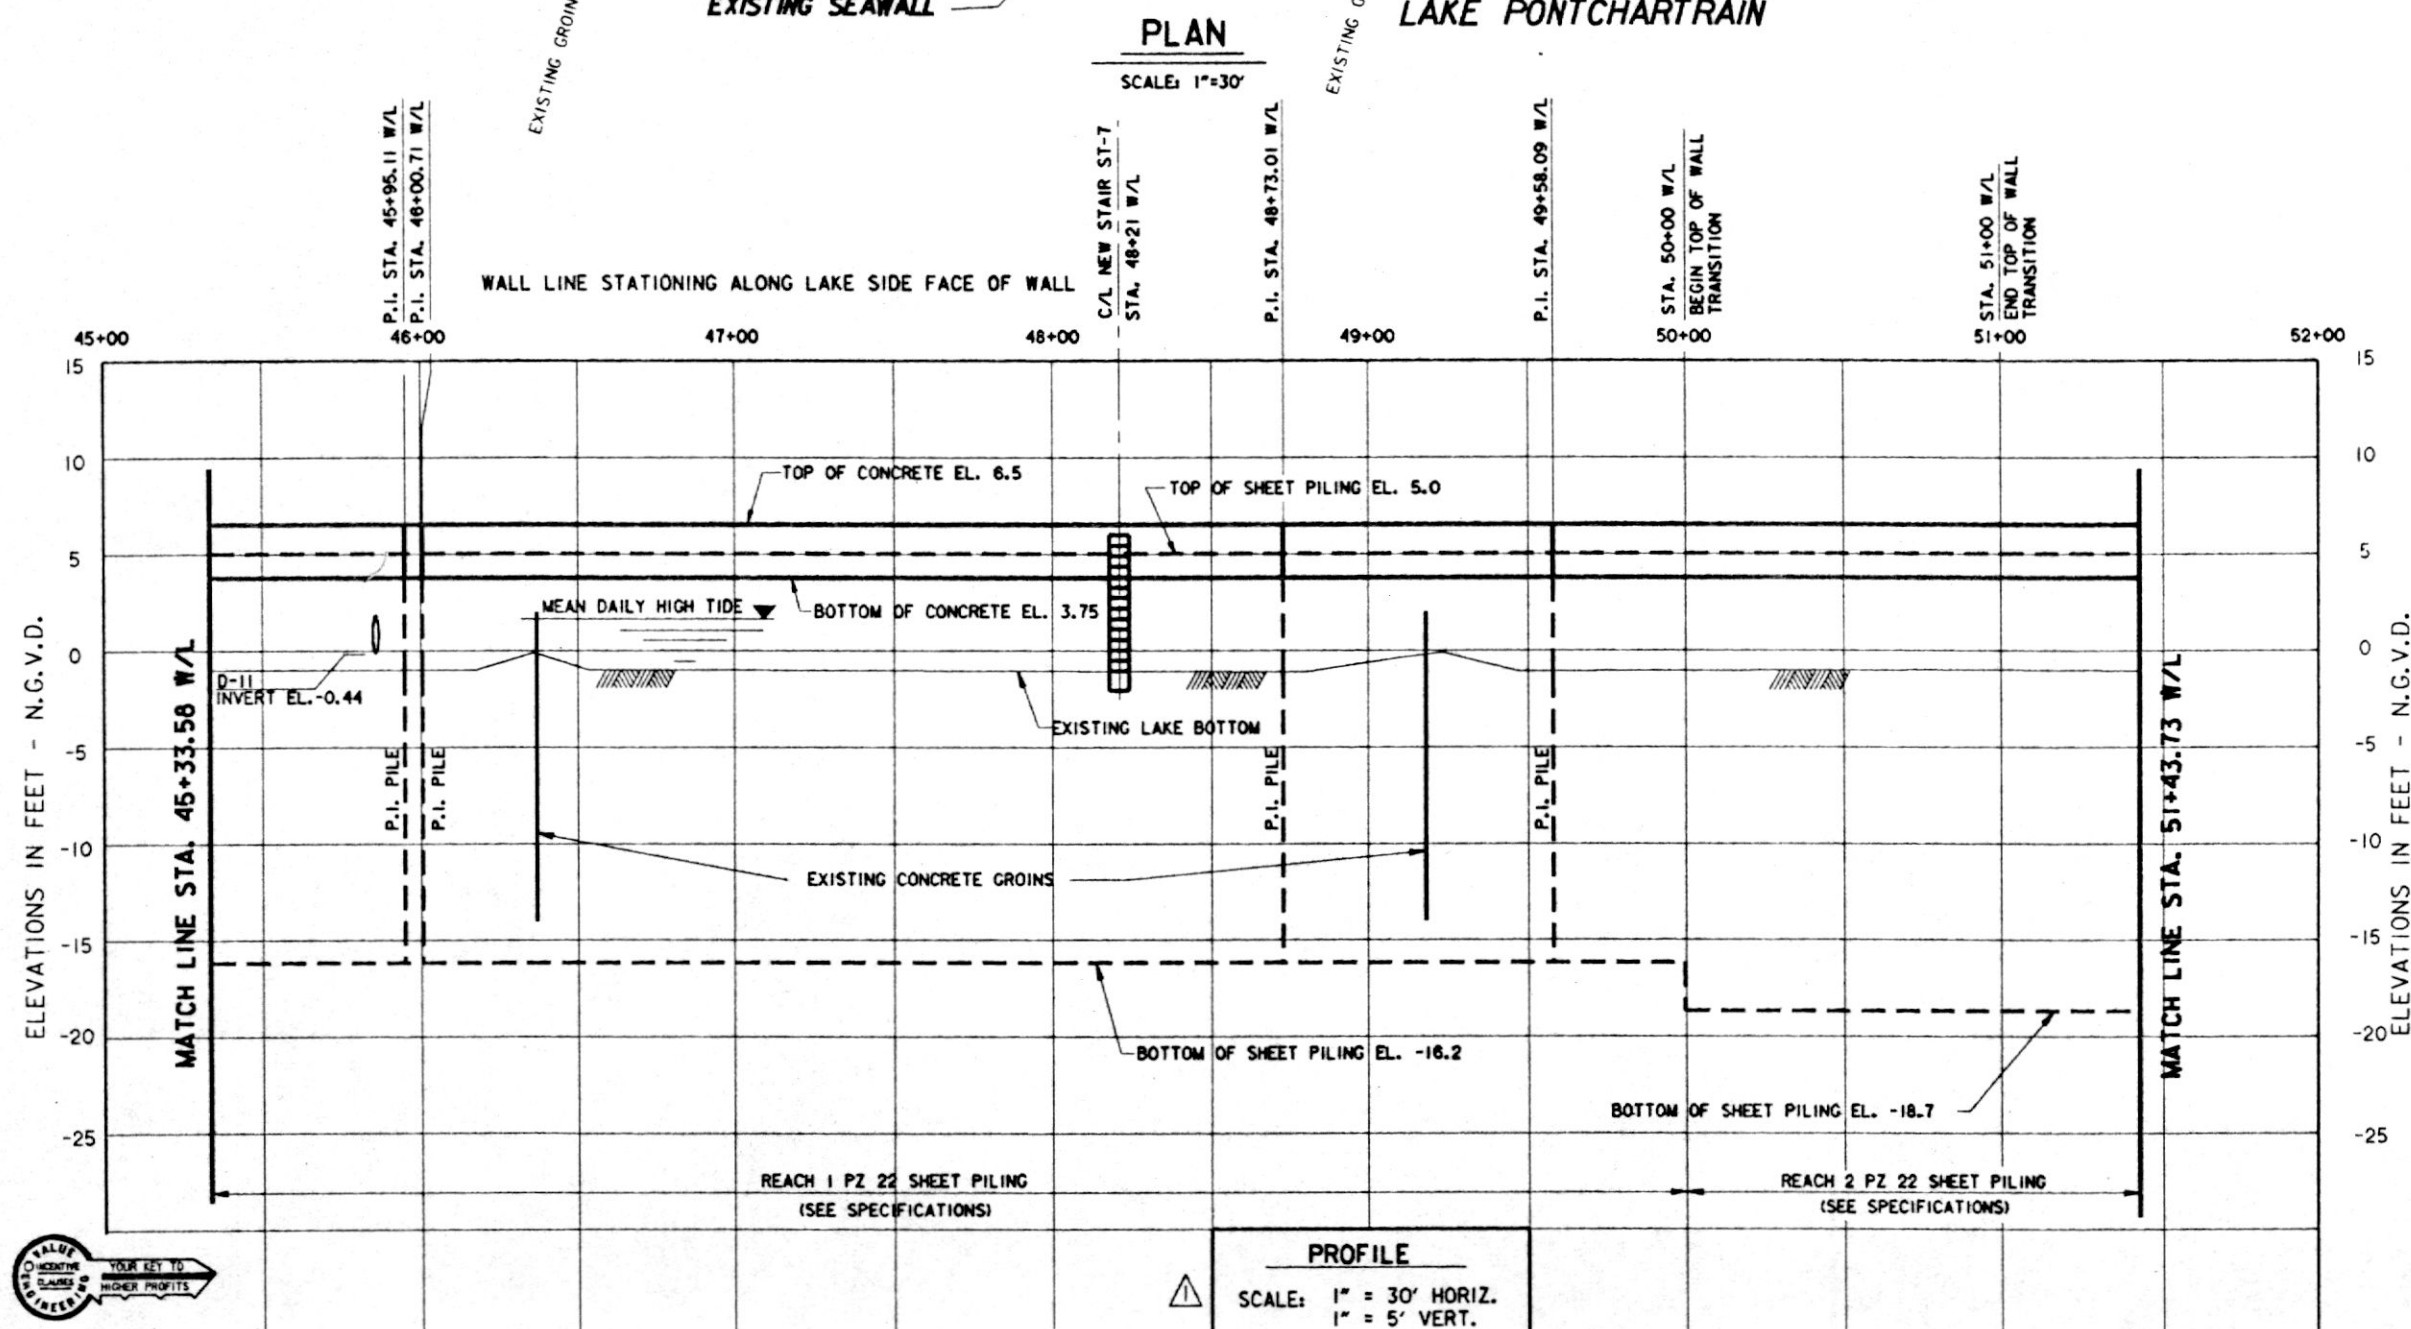
CONTRACTOR TO REPAIR CONSTRUCTION DAMAGE

000 DENOTES CONSTRUCTION SERVITUDE P.I. NUMBERS


6 DENOTES WALL LINE P.I. NUMBERS

NOTES:

1. FOR GENERAL NOTES, SEE DWG. 2
2. FOR LEGEND, SEE DWG. 3
3. FOR GROUT MODIFICATIONS, SEE DWG. 24
4. FOR WALL TRANSITION DETAILS, SEE DWG. 25
5. FOR DRAIN DETAILS, SEE DWG. 26
6. FOR STAIR DETAILS, SEE DWG. 27
7. FOR SOIL BORING LOGS SEE DWG. 30
8. FOR LAKE HYDROGRAPH SEE DWG. 31
9. STAKES AND GUY WIRES AROUND SMALL TREES NOT SHOWN. CONTRACTOR TO MAINTAIN.
10. EXTENT OF RIPRAP ON LAKE BOTTOM AND DEBRIS BEHIND WALL MAY VARY FROM THAT SHOWN.



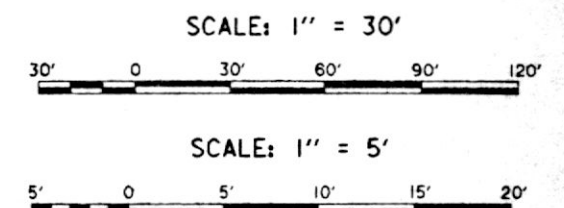
THIS PLAN ACCOMPANIES  
MODIFICATION P0000  
TO CONTRACT NUMBER  
DACW29-94-C-0031



|                                                                                                                                                               |                                                                                                     |                 |                           |
|---------------------------------------------------------------------------------------------------------------------------------------------------------------|-----------------------------------------------------------------------------------------------------|-----------------|---------------------------|
|                                                                          | REVISED TOP OF WALL AND SHEET PILING AND<br>BOTTOM OF WALL IN PROFILE; MOD.                         | 4-5-94          | W.O.B.                    |
|                                                                                                                                                               | SYMBOL                                                                                              | DESCRIPTION     | DATE APPROVED             |
| REVISIONS                                                                                                                                                     |                                                                                                     |                 |                           |
|                                                                          | <b>U. S. ARMY ENGINEERING DISTRICT, NEW ORLEANS</b><br>CORPS OF ENGINEERS<br>NEW ORLEANS, LOUISIANA |                 |                           |
|  <b>Brown Cunningham Gannuch</b><br>ENGINEERS • ARCHITECTS • CONSULTANTS |                                                                                                     |                 |                           |
| MANDEVILLE SEAWALL, LA.<br><b>REPLACEMENT OF MANDEVILLE SEAWALL</b><br>ST. TAMMANY PARISH, LOUISIANA                                                          |                                                                                                     |                 |                           |
| <b>PLAN AND PROFILE</b><br><b>STA. 45+33.58 W/L TO STA. 51+43.73 W/L</b>                                                                                      |                                                                                                     |                 |                           |
| DESIGNED BY: R.W.Y.                                                                                                                                           | DATE: NOV. 1993                                                                                     | PLOT SCALE: 360 | PLOT DATE: NOV. 1993      |
| DRAWN BY: J.S.B.                                                                                                                                              | CADD FILE #0335-10LDON                                                                              |                 | FILE NO. <b>H-4-40335</b> |
| CHECKED BY: T.P.H.                                                                                                                                            | SOLICITATION NO. DACW29-94-B-0024                                                                   |                 | DWG. 10 OF 31             |
| SUBMITTED BY: ROBERT W. YOKUM, P.E.<br>FOR THE U.S. ARMY CORPS OF ENGINEERS                                                                                   |                                                                                                     |                 |                           |



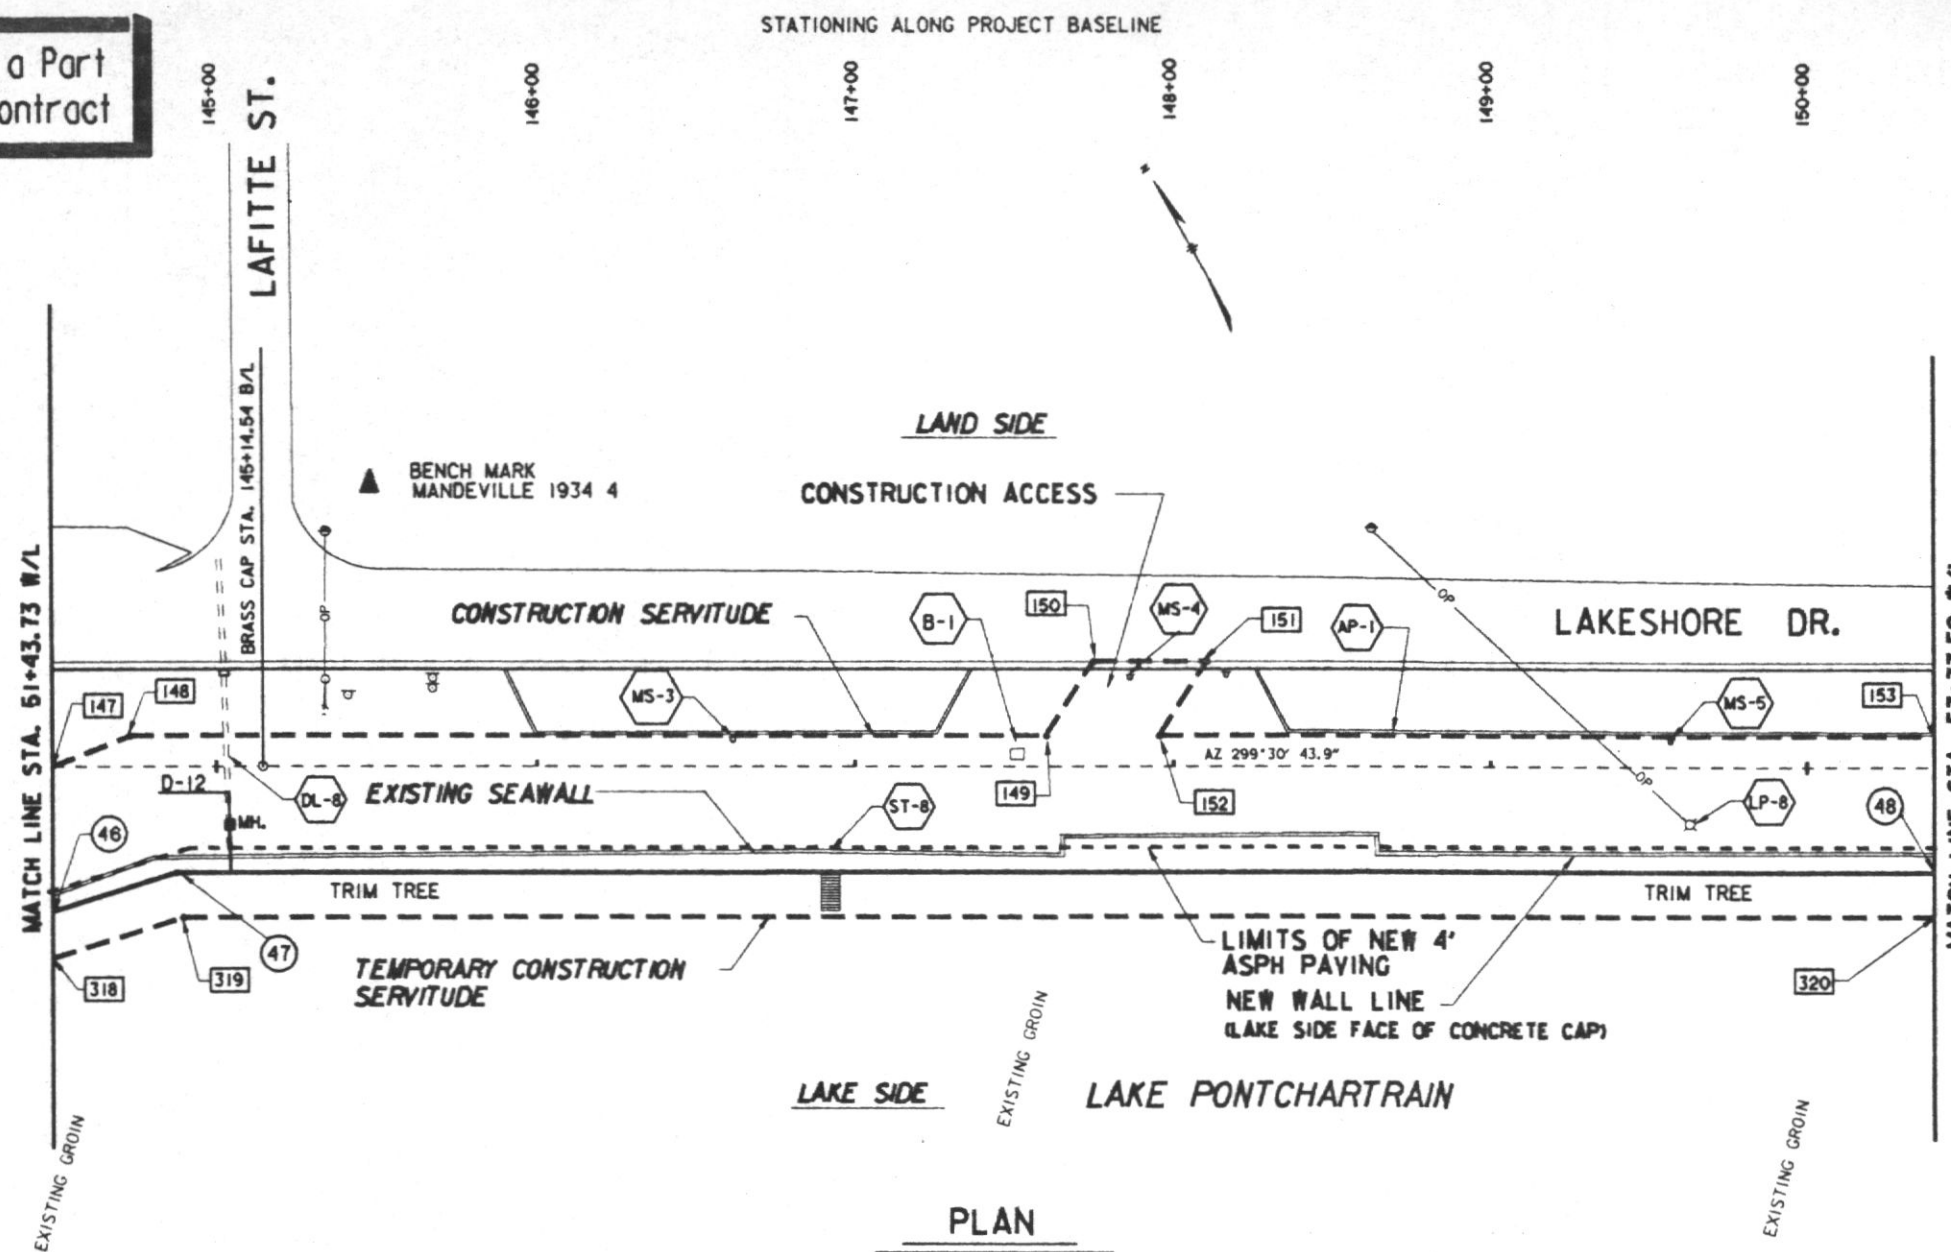**Safety is a Part  
of Your Contract**



| WALL LINE DATA |                     |                           |     |                      |
|----------------|---------------------|---------------------------|-----|----------------------|
| P.I.<br>NO.    | BASELINE<br>STATION | DISTANCE FROM<br>BASELINE |     | WALL LINE<br>STATION |
| 46             | 144+48.00           | 44.90                     | RT. | 51+43.73             |
| 47             | 144+87.25           | 32.90                     | RT. | 51+84.77             |
| 48             | 150+40.00           | 32.41                     | RT. | 57+37.52             |

| CONSTRUCTION<br>SERVITUDE |                |                                  | TEMPORARY<br>CONSTRUCTION<br>SERVITUDE |                |                                  |
|---------------------------|----------------|----------------------------------|----------------------------------------|----------------|----------------------------------|
| LAND SIDE                 |                |                                  | LAKE SIDE                              |                |                                  |
| P.I.<br>NO.               | B/L<br>STATION | DISTANCE<br>MEASURED<br>FROM B/L | P.I.<br>NO.                            | B/L<br>STATION | DISTANCE<br>MEASURED<br>FROM B/L |
| 147                       | 144+48.0       | 0.0'                             | 318                                    | 144+48.0       | 59.6' RT.                        |
| 148                       | 144+72.6       | 9.6' LT.                         | 319                                    | 144+89.4       | 46.9' RT.                        |
| 149                       | 147+59.7       | 9.6' LT.                         | 320                                    | 150+40.0       | 46.5' RT.                        |
| 150                       | 147+74.6       | 32.7' LT.                        |                                        |                |                                  |
| 151                       | 148+10.2       | 32.7' LT.                        |                                        |                |                                  |
| 152                       | 147+95.4       | 9.6' LT.                         |                                        |                |                                  |
| 153                       | 150+40.0       | 9.6' LT.                         |                                        |                |                                  |

| EXISTING FACILITIES |                          |                  |                    |               |
|---------------------|--------------------------|------------------|--------------------|---------------|
| ITEM                | DESCRIPTION              | B/L STATION      | OWNER              | DISPOSITION   |
| AP-1                | ASPHALT PATH             | 144+48 TO 150+40 | CITY OF MANDEVILLE | TO REMAIN     |
| DL-8                | 24" CLAY PIPE DRAIN LINE | 145+04.1         | CITY OF MANDEVILLE | CONTR. RELOC. |
| MS-3                | METAL SIGN & POST        | 146+60.9         | CITY OF MANDEVILLE | OWNER RELOC.  |
| ST-8                | CONCRETE STEPS           | 146+91.9         | CITY OF MANDEVILLE | CONTR. REMOVE |
| B-1                 | WOODEN BENCH             | 147+51           | CITY OF MANDEVILLE | TO REMAIN     |
| MS-4                | METAL SIGN & POST        | 147+86.1         | CITY OF MANDEVILLE | OWNER RELOC.  |
| MS-5                | METAL SIGN & POST        | 149+56.7         | CITY OF MANDEVILLE | OWNER RELOC.  |
| LP-8                | LIGHT POLE W/OP LINE     | 149+62.8         | CLECO              | OWNER RELOC.  |

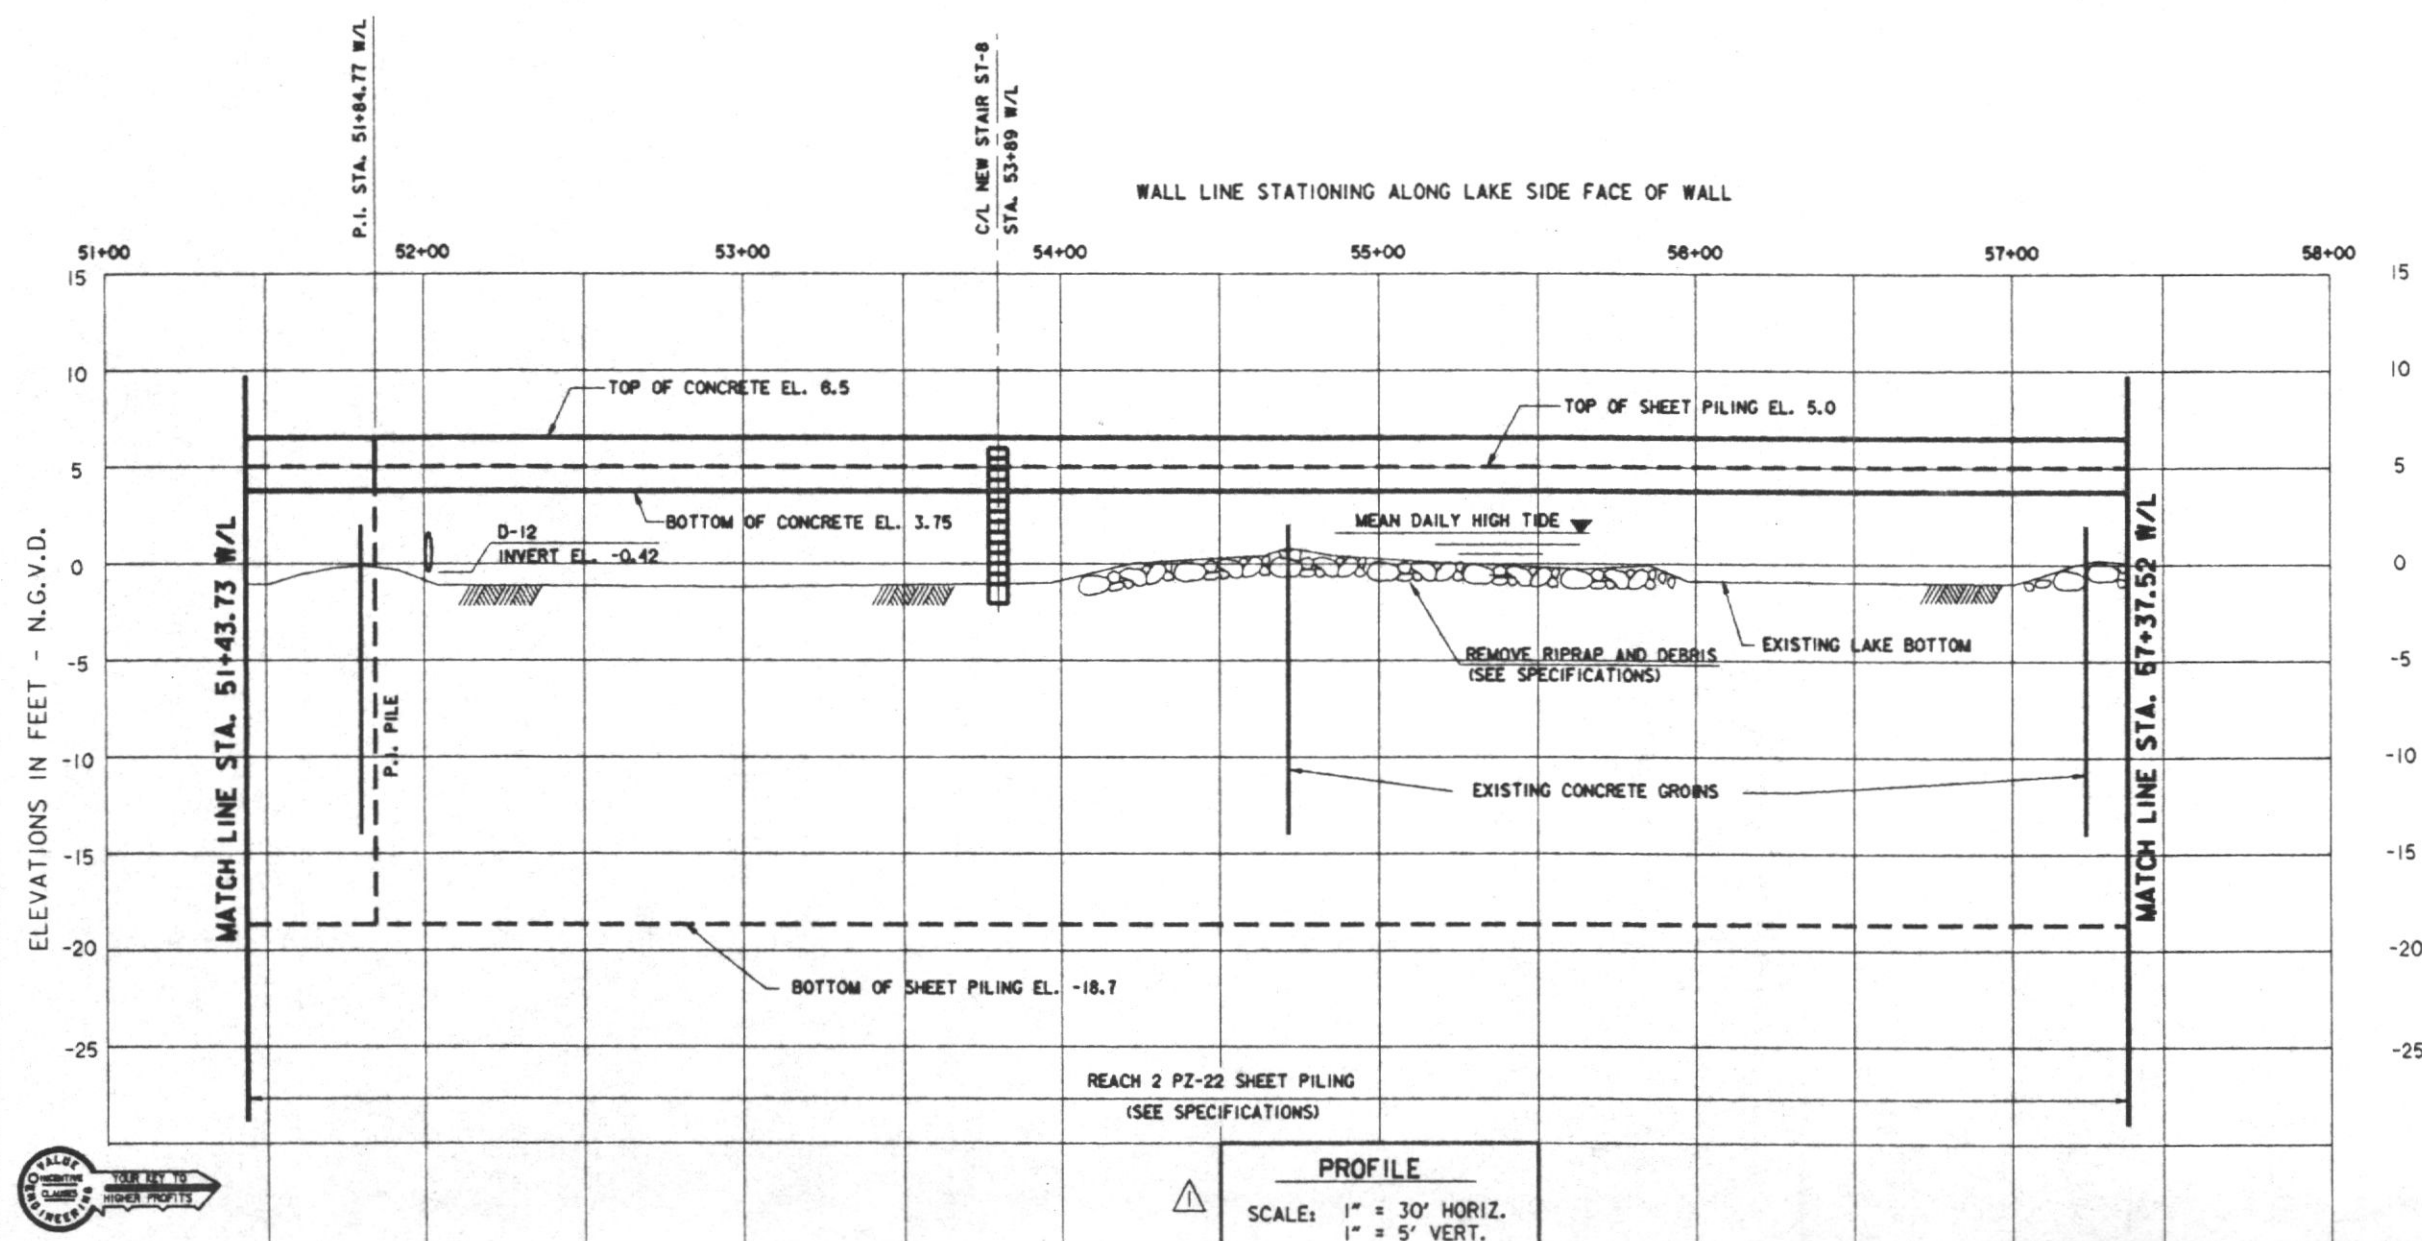
\* CONTRACTOR NOT TO DISTURB  
\*\* CONTRACTOR TO REPAIR CONSTRUCTION DAMAGE

000 DENOTES CONSTRUCTION SERVITUDE P.I. NUMBERS

(6) DENOTES WALL LINE P.I. NUMBERS


NOTES:

1. FOR GENERAL NOTES, SEE DWG. 2
2. FOR LEGEND, SEE DWG. 3
3. FOR GROUT MODIFICATIONS, SEE DWG. 24
4. FOR WALL TRANSITION DETAILS, SEE DWG. 25
5. FOR DRAIN DETAILS, SEE DWG. 26
6. FOR STAIR DETAILS, SEE DWG. 27
7. FOR SOIL BORING LOGS SEE DWG. 30
8. FOR LAKE HYDROGRAPH SEE DWG. 31
9. STAKES AND GUY WIRES AROUND SMALL TREES NOT SHOWN. CONTRACTOR TO MAINTAIN.
10. EXTENT OF RIPRAP ON LAKE BOTTOM AND DEBRIS BEHIND WALL MAY VARY FROM THAT SHOWN.



THIS PLAN ACCOMPANIES  
MODIFICATION P0000  
TO CONTRACT NUMBER  
DACW29-94-C-0031

 SCALE: 1" = 30'




SCALE: 1" = 5'



|                                                                                                                                                                                                                                                                                                                                                                                                                                                                                             |                                                                                           |                    |                                        |
|---------------------------------------------------------------------------------------------------------------------------------------------------------------------------------------------------------------------------------------------------------------------------------------------------------------------------------------------------------------------------------------------------------------------------------------------------------------------------------------------|-------------------------------------------------------------------------------------------|--------------------|----------------------------------------|
|                                                                                                                                                                                                                                                                                                                                                                                                        | REVISED TOP OF SHEET PILING AND BOTTOM<br>OF WALL IN PROFILE! MOD.                        | 4-5-94             | W.O.B.                                 |
| SYMBOL                                                                                                                                                                                                                                                                                                                                                                                                                                                                                      | DESCRIPTION                                                                               | DATE               | APPROVED                               |
| REVISIONS                                                                                                                                                                                                                                                                                                                                                                                                                                                                                   |                                                                                           |                    |                                        |
|                                                                                                                                                                                                                                                                                                                                                                                                        | U. S. ARMY ENGINEER DISTRICT, NEW ORLEANS<br>CORPS OF ENGINEERS<br>NEW ORLEANS, LOUISIANA |                    |                                        |
| <div data-bbox="2578 1688 2633 1727" style="display: inline-block; vertical-align: middle;">  </div> <div data-bbox="2639 1688 2957 1712" style="display: inline-block; vertical-align: middle;">         Brown Cunningham Gannuch       </div> <div data-bbox="2682 1716 2911 1731" style="display: inline-block; vertical-align: middle;">         ENGINEERS • ARCHITECTS • CONSULTANTS       </div> |                                                                                           |                    |                                        |
| MANDEVILLE SEAWALL, LA.<br>REPLACEMENT OF MANDEVILLE SEAWALL<br>ST. TAMMANY PARISH, LOUISIANA                                                                                                                                                                                                                                                                                                                                                                                               |                                                                                           |                    |                                        |
| <div data-bbox="2649 1810 2902 1839" style="text-align: center;"> <h1>PLAN AND PROFILE</h1> </div> <div data-bbox="2554 1849 2981 1874" style="text-align: center;"> <h2>STA. 51+43.73 W/L TO STA. 57+37.52 W/L</h2> </div>                                                                                                                                                                                                                                                                 |                                                                                           |                    |                                        |
| DESIGNED BY: R.W.Y.<br>DRAWN BY: J.S.B.<br>CHECKED BY: T.P.H.                                                                                                                                                                                                                                                                                                                                                                                                                               | DATE:<br>NOV. 1993                                                                        | PLOT SCALE:<br>360 | PLOT DATE:<br>NOV. 1993                |
| SUBMITTED BY:<br>ROBERT W. YOKUM, P.E.                                                                                                                                                                                                                                                                                                                                                                                                                                                      | CAD FILE# 40336-11.DGN<br>SOLLICITATION NO.<br>DACW29-94-B-0024                           |                    | FILE NO.<br>H-4-40335<br>DWG. 11 OF 30 |



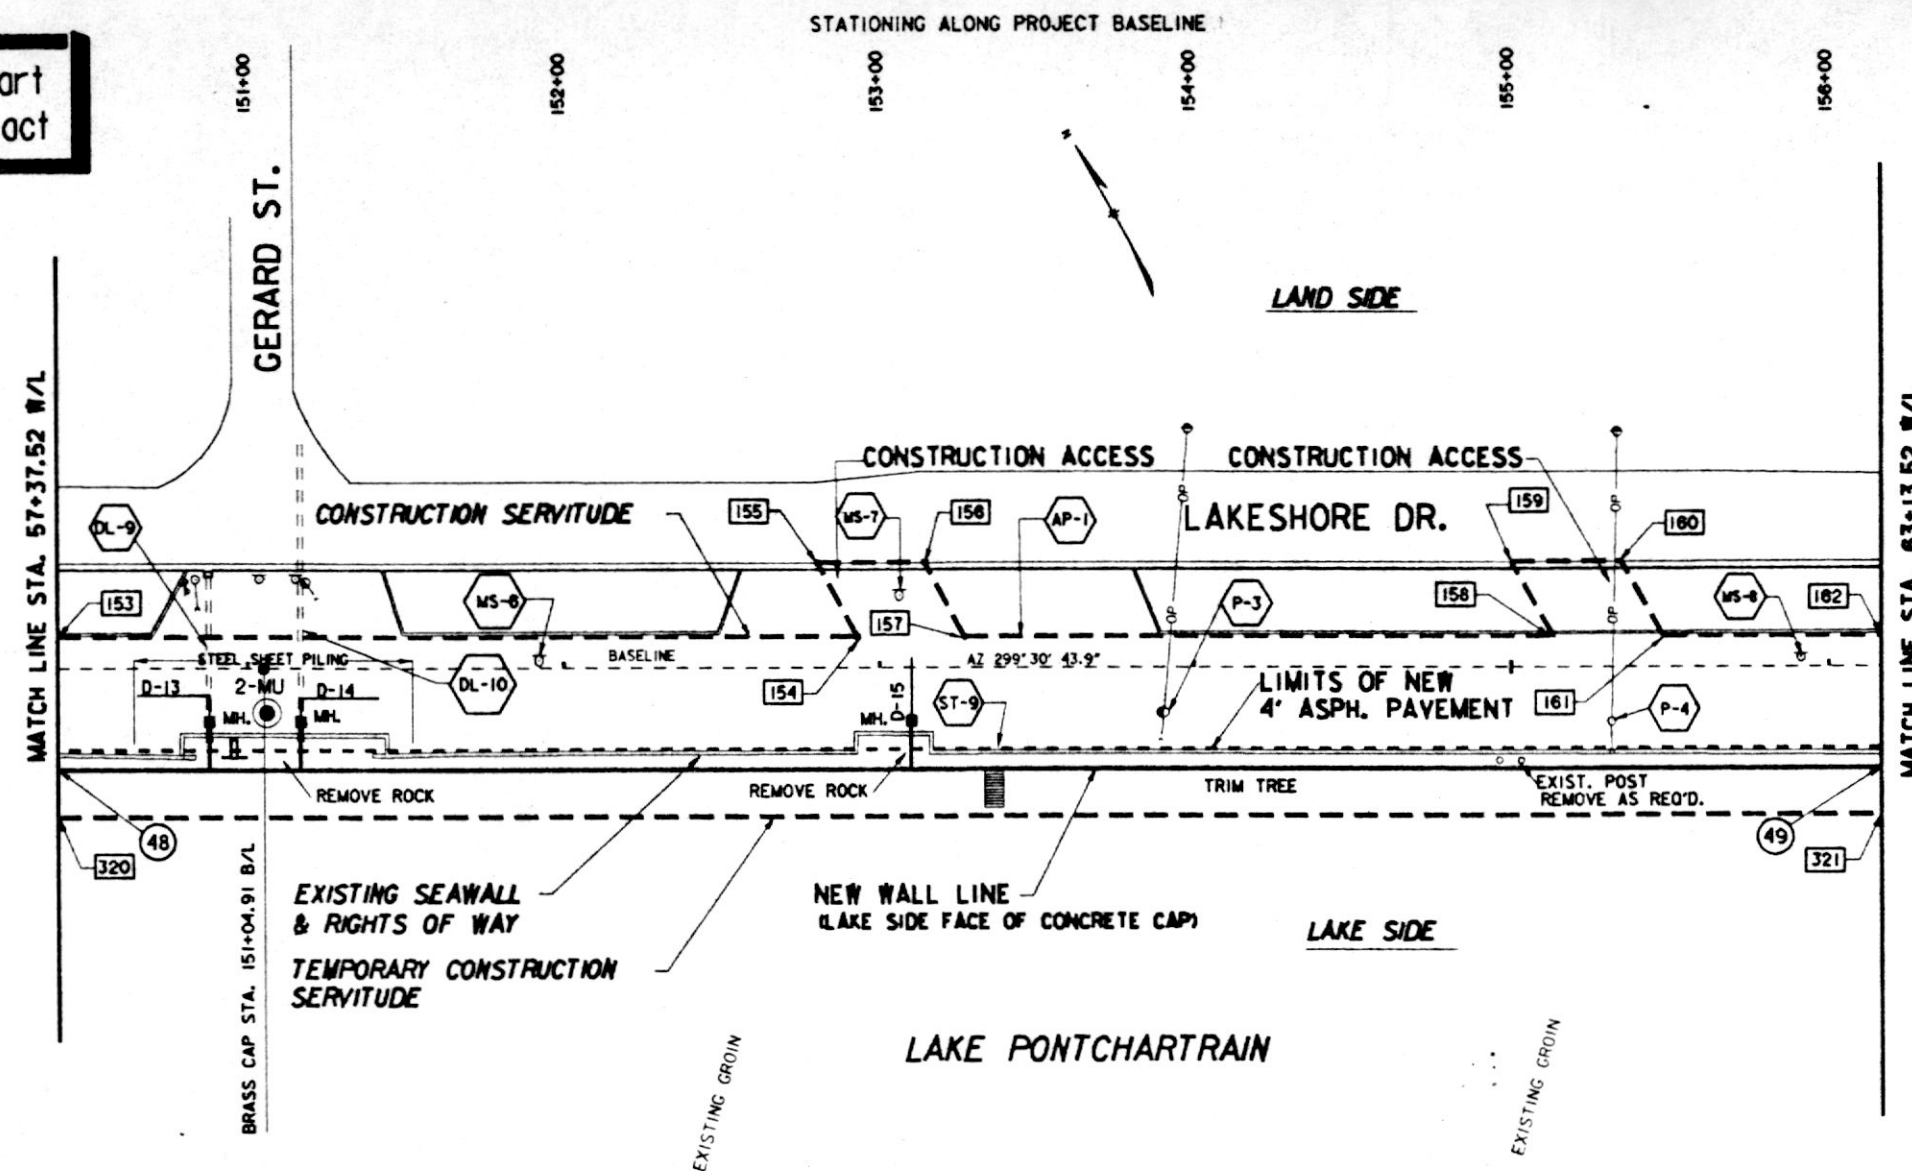Safety is a Part  
of Your Contract



| WALL LINE DATA |             |                        |     |                   |
|----------------|-------------|------------------------|-----|-------------------|
| P.I. NO.       | B/L STATION | DISTANCE FROM BASELINE | RT. | WALL LINE STATION |
| 48             | 150+40.00   | 32.41                  | RT. | 57+37.52          |
| 49             | 156+16.00   | 31.91                  | RT. | 63+13.52          |

| CONSTRUCTION SERVITUDE |             |                            | TEMPORARY CONSTRUCTION SERVITUDE |             |                            |
|------------------------|-------------|----------------------------|----------------------------------|-------------|----------------------------|
| LAND SIDE              |             |                            | LAKE SIDE                        |             |                            |
| P.I. NO.               | B/L STATION | DISTANCE MEASURED FROM B/L | P.I. NO.                         | B/L STATION | DISTANCE MEASURED FROM B/L |
| 153                    | 150+40.0    | 9.6' LT.                   | 320                              | 150+40.0    | 46.5' RT.                  |
| 154                    | 152+92.9    | 9.6' LT.                   | 321                              | 156+16.0    | 46.1' RT.                  |
| 155                    | 152+80.1    | 32.6' LT.                  |                                  |             |                            |
| 156                    | 153+14.5    | 32.6' LT.                  |                                  |             |                            |
| 157                    | 153+27.2    | 9.6' LT.                   |                                  |             |                            |
| 158                    | 155+13.4    | 9.6' LT.                   |                                  |             |                            |
| 159                    | 155+00.0    | 32.7' LT.                  |                                  |             |                            |
| 160                    | 155+34.7    | 32.7' LT.                  |                                  |             |                            |
| 161                    | 155+48.1    | 9.6' LT.                   |                                  |             |                            |
| 162                    | 156+16.0    | 9.6' LT.                   |                                  |             |                            |

| EXISTING FACILITIES |                                   |                  |                    |               |
|---------------------|-----------------------------------|------------------|--------------------|---------------|
| ITEM                | DESCRIPTION                       | B/L STATION      | OWNER              | DISPOSITION   |
| AP-1                | ASPHALT PATH                      | 150+40 TO 156+16 | CITY OF MANDEVILLE | TO REMAIN     |
| DL-9                | 24"CLAY PIPE DRAIN LINE           | 150+87.5         | CITY OF MANDEVILLE | CONTR. RELOC. |
| DL-10               | 24"CLAY PIPE DRAIN LINE           | 151+16.8         | CITY OF MANDEVILLE | CONTR. RELOC. |
| MS-6                | METAL SIGN & POST                 | 151+92.1         | CITY OF MANDEVILLE | OWNER RELOC.  |
| MS-7                | METAL SIGN & POST                 | 153+06.1         | CITY OF MANDEVILLE | OWNER RELOC.  |
| ST-9                | CONCRETE STEPS                    | 153+36.3         | CITY OF MANDEVILLE | CONTR. REMOVE |
| P-3                 | UTILITY POLE & GUY WIRE W/OP LINE | 153+90.1         | CLECO              | OWNER RELOC.  |
| P-4                 | UTILITY POLE & GUY WIRE W/OP LINE | 155+31.7         | CLECO              | OWNER RELOC.  |
| MS-8                | METAL SIGN & POST                 | 155+91           | CITY OF MANDEVILLE | OWNER RELOC.  |


\*\* CONTRACTOR TO REPAIR CONSTRUCTION DAMAGE

000 DENOTES CONSTRUCTION SERVITUDE P.I. NUMBERS

6 DENOTES WALL LINE P.I. NUMBERS

#### NOTES:

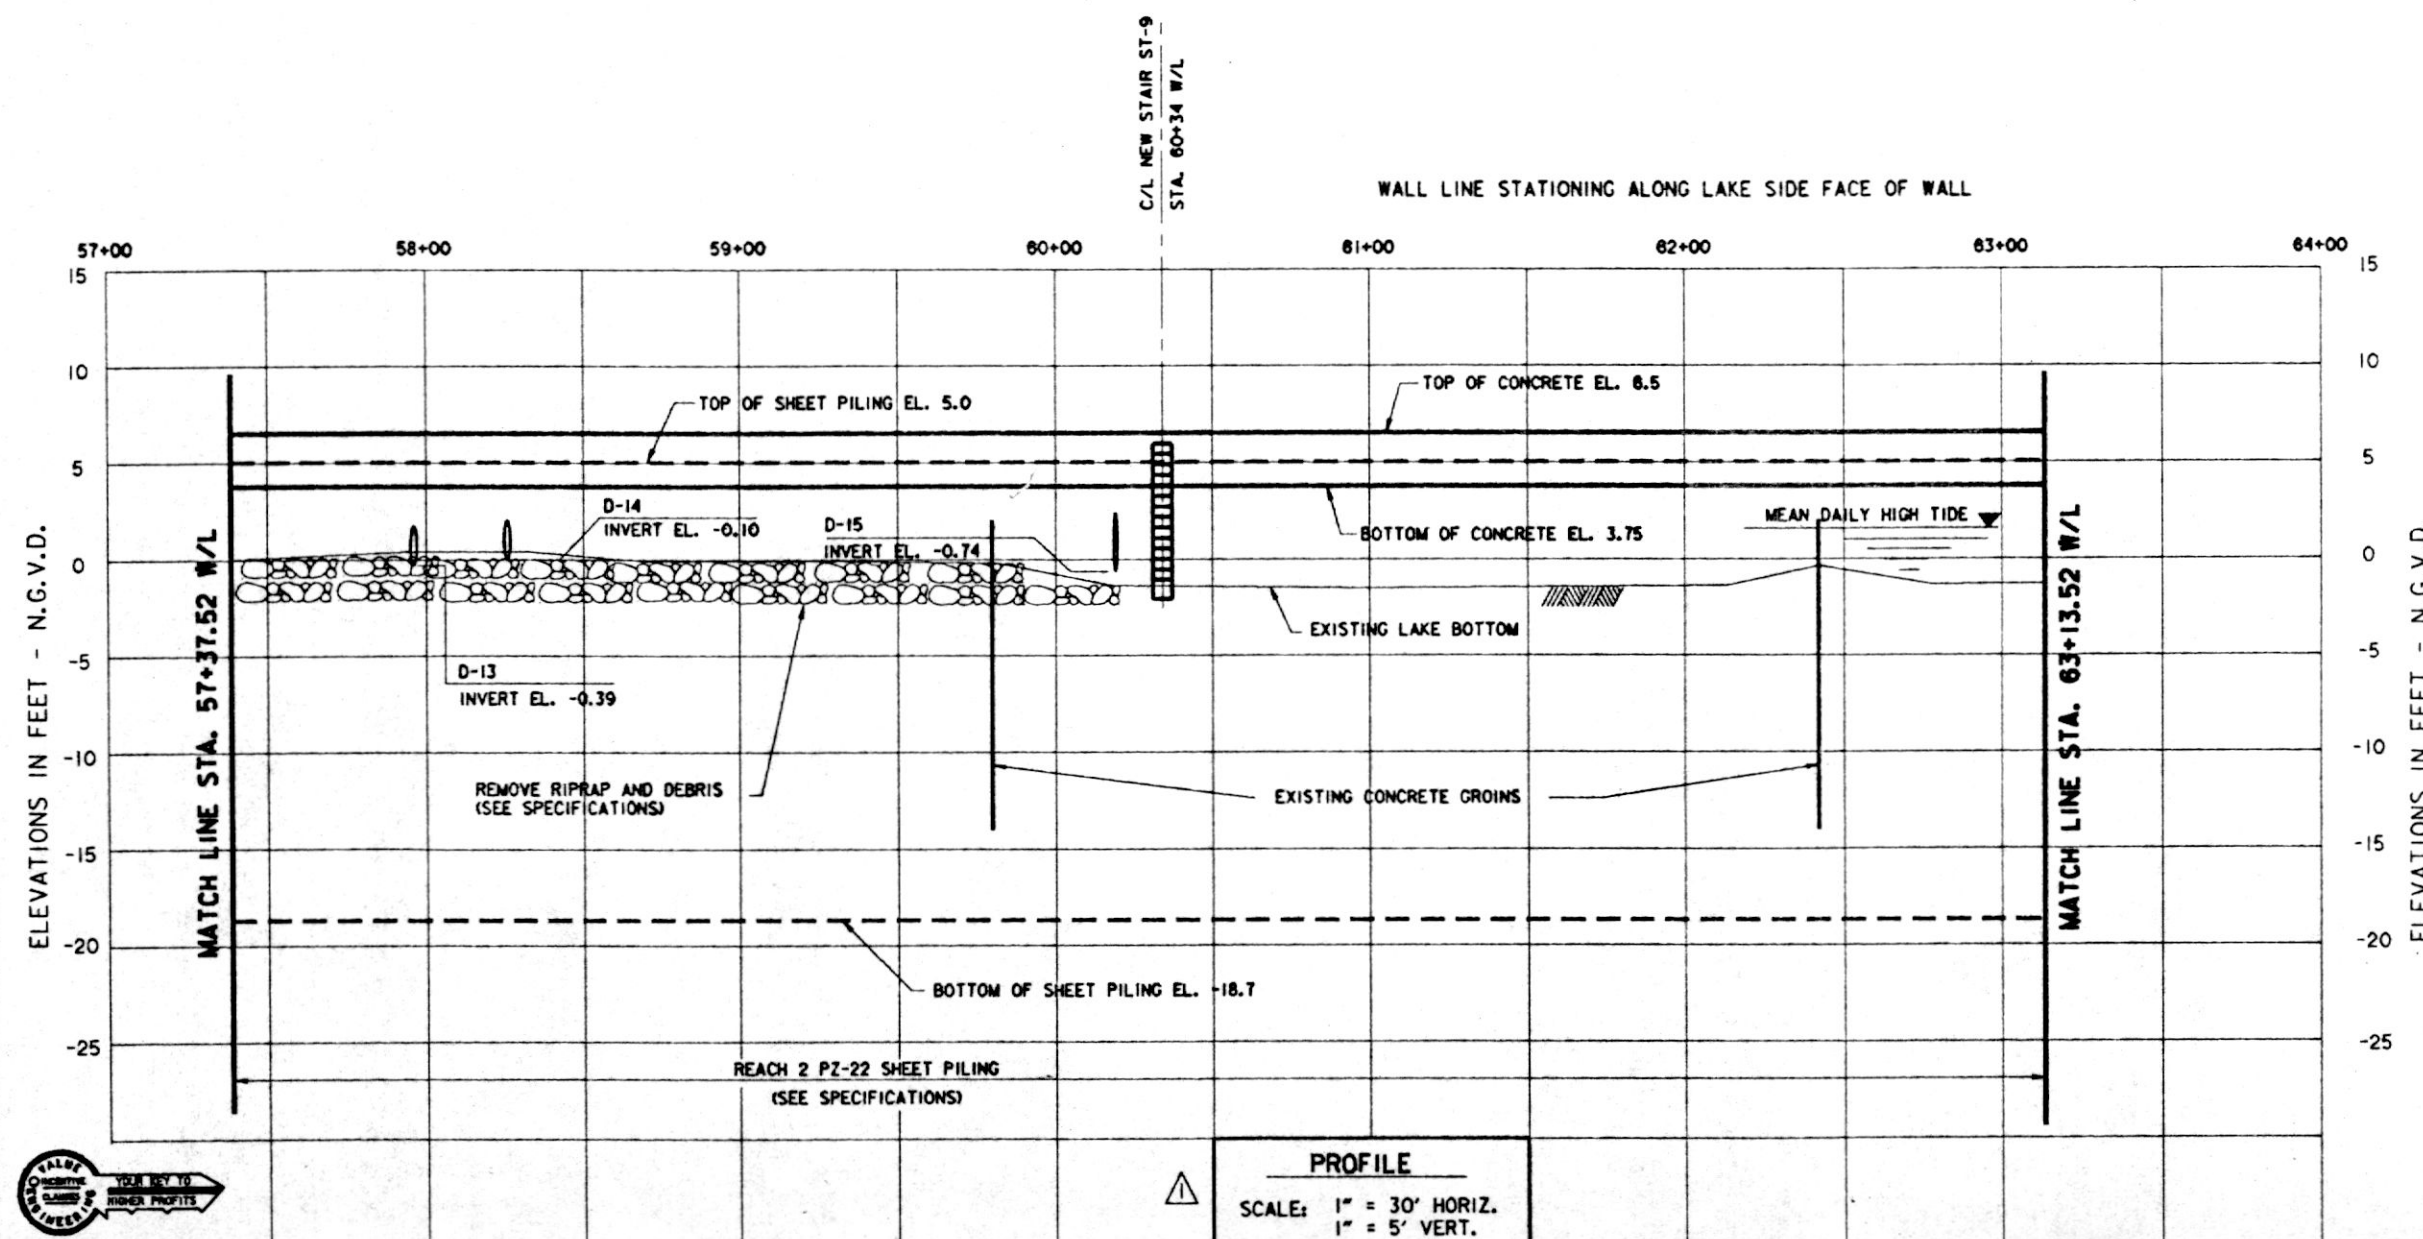- FOR GENERAL NOTES, SEE DWG. 2
- FOR LEGEND, SEE DWG. 3
- FOR GROIN MODIFICATIONS, SEE DWG. 24
- FOR WALL TRANSITION DETAILS, SEE DWG. 25
- FOR DRAIN DETAILS, SEE DWG. 26
- FOR STAIR DETAILS, SEE DWG. 27
- FOR SOIL BORING LOGS SEE DWG. 30
- FOR LAKE HYDROGRAPH SEE DWG. 31
- STAKES AND GUY WIRES AROUND SMALL TREES NOT SHOWN. CONTRACTOR TO MAINTAIN.
- EXTENT OF RIPRAP ON LAKE BOTTOM AND DEBRIS BEHIND WALL MAY VARY FROM THAT SHOWN.



THIS PLAN ACCOMPANIES  
MODIFICATION 0000  
TO CONTRACT NUMBER  
DACW29-94-C-0031

SCALE: 1" = 30'

30' 0 30' 60' 90' 120'

SCALE: 1" = 5'

5' 0 5' 10' 15' 20'

|           |        |                                                                 |          |
|-----------|--------|-----------------------------------------------------------------|----------|
| REVISIONS | DATE   | DESCRIPTION                                                     | APPROVED |
| 1         | 4-5-94 | REVISED TOP OF SHEET PILING AND BOTTOM OF WALL IN PROFILE; MOD. | W.O.B.   |

U. S. ARMY ENGINEER DISTRICT, NEW ORLEANS  
CORPS OF ENGINEERS  
NEW ORLEANS, LOUISIANA

BC Brown Cunningham Gannuch  
ENGINEERS • ARCHITECTS • CONSULTANTS

MANDEVILLE SEAWALL, LA.  
REPLACEMENT OF MANDEVILLE SEAWALL  
ST. TAMMANY PARISH, LOUISIANA


PLAN AND PROFILE  
STA. 57+37.52 W/L TO STA. 63+13.52 W/L

|                     |                                     |                                   |                      |
|---------------------|-------------------------------------|-----------------------------------|----------------------|
| DESIGNED BY: R.W.Y. | DATE: NOV. 1993                     | PLOT SCALE: 360                   | PLOT DATE: NOV. 1993 |
| DRAWN BY: J.S.B.    | CADD FILE: 40336-12.DGN             | FILE NO. H-4-40335                |                      |
| CHECKED BY: T.P.N.  | SUBMITTED BY: ROBERT W. YOKUM, P.E. | SOLICITATION NO. DACW29-94-B-0024 | DWG. 12 OF 31        |




Safety is a Part  
of Your Contract

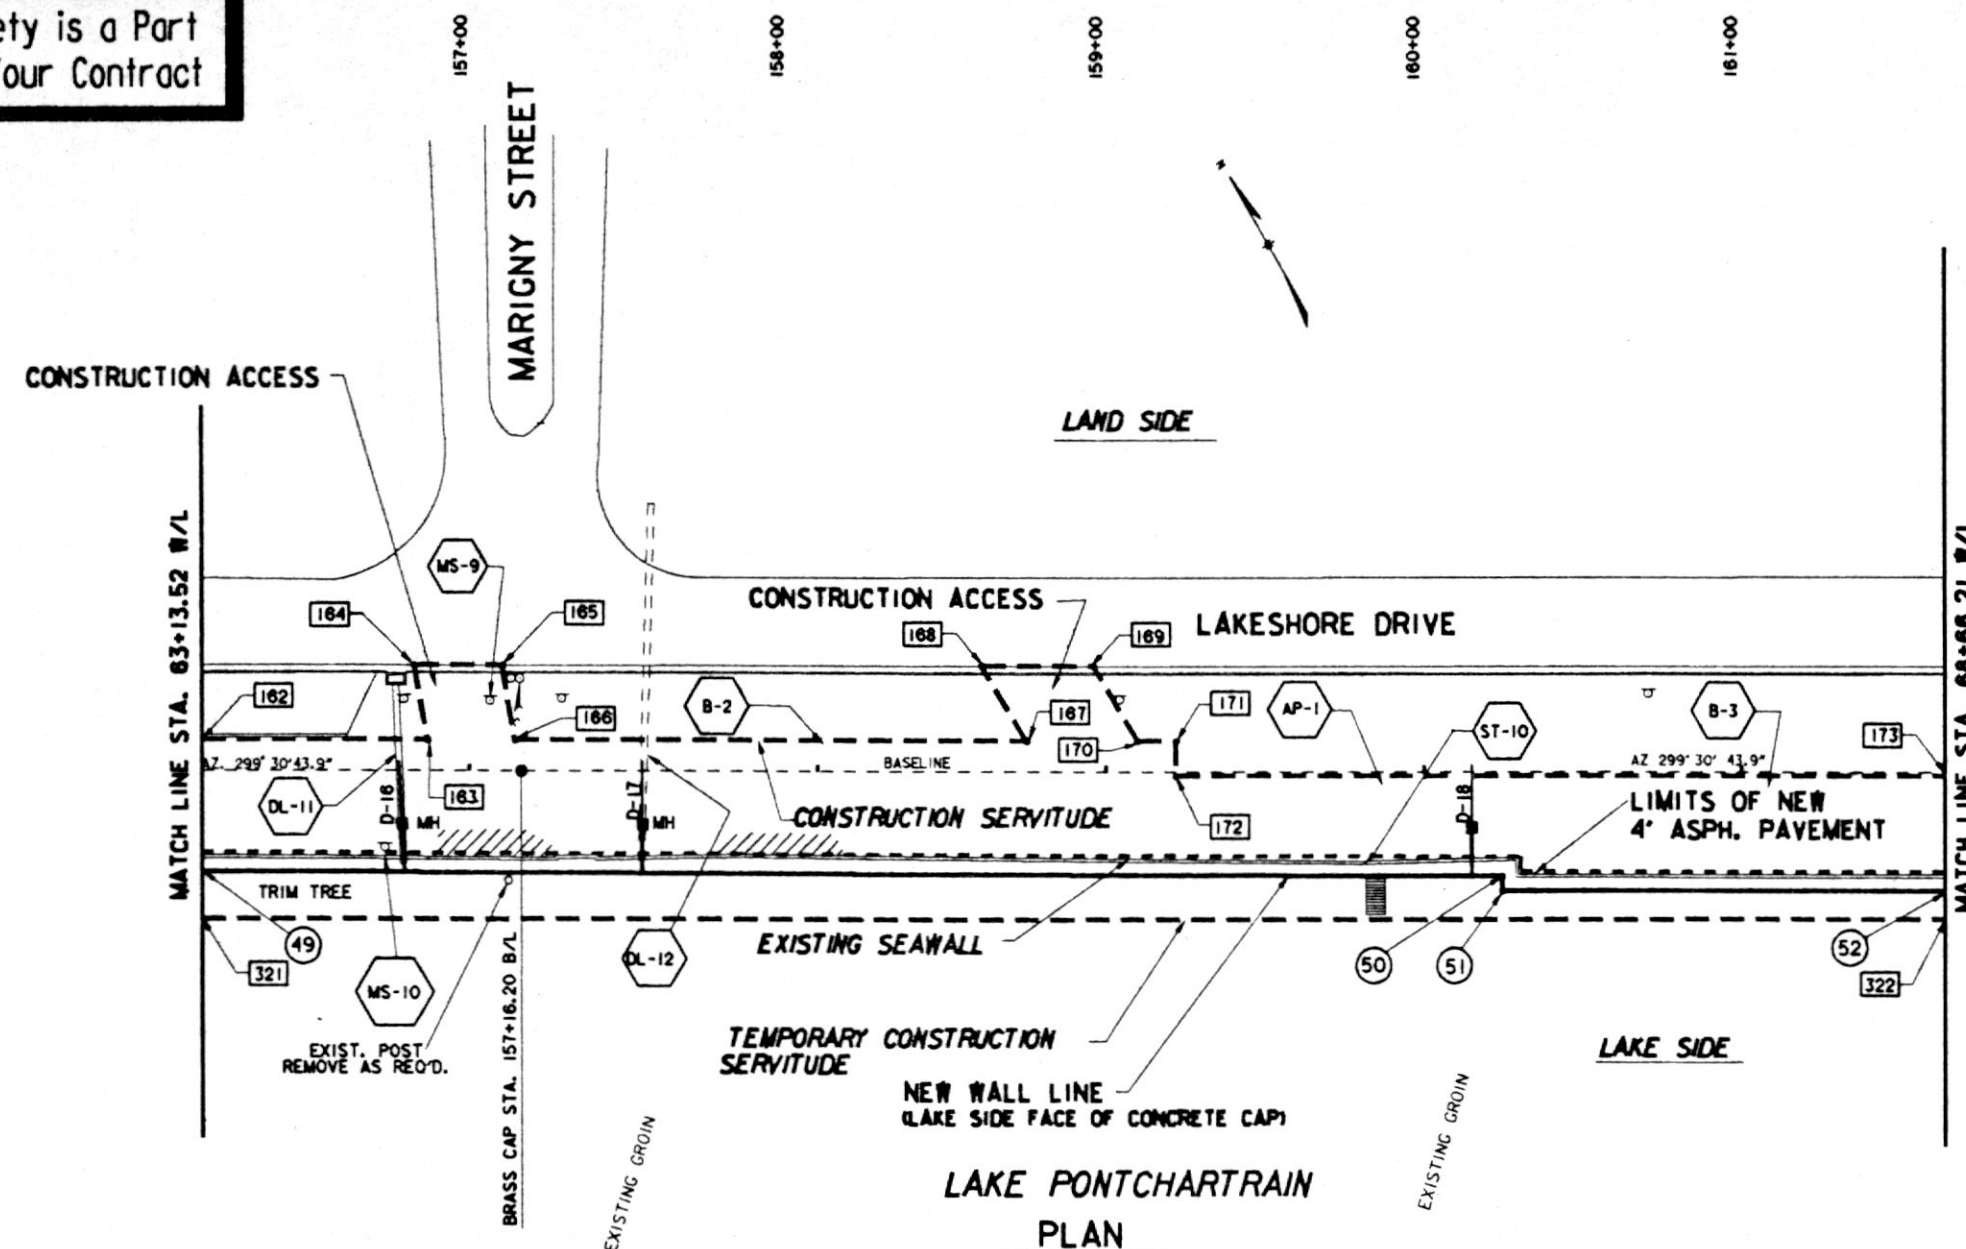STATIONING ALONG PROJECT BASELINE



LAKE PONTCHARTRAIN  
PLAN

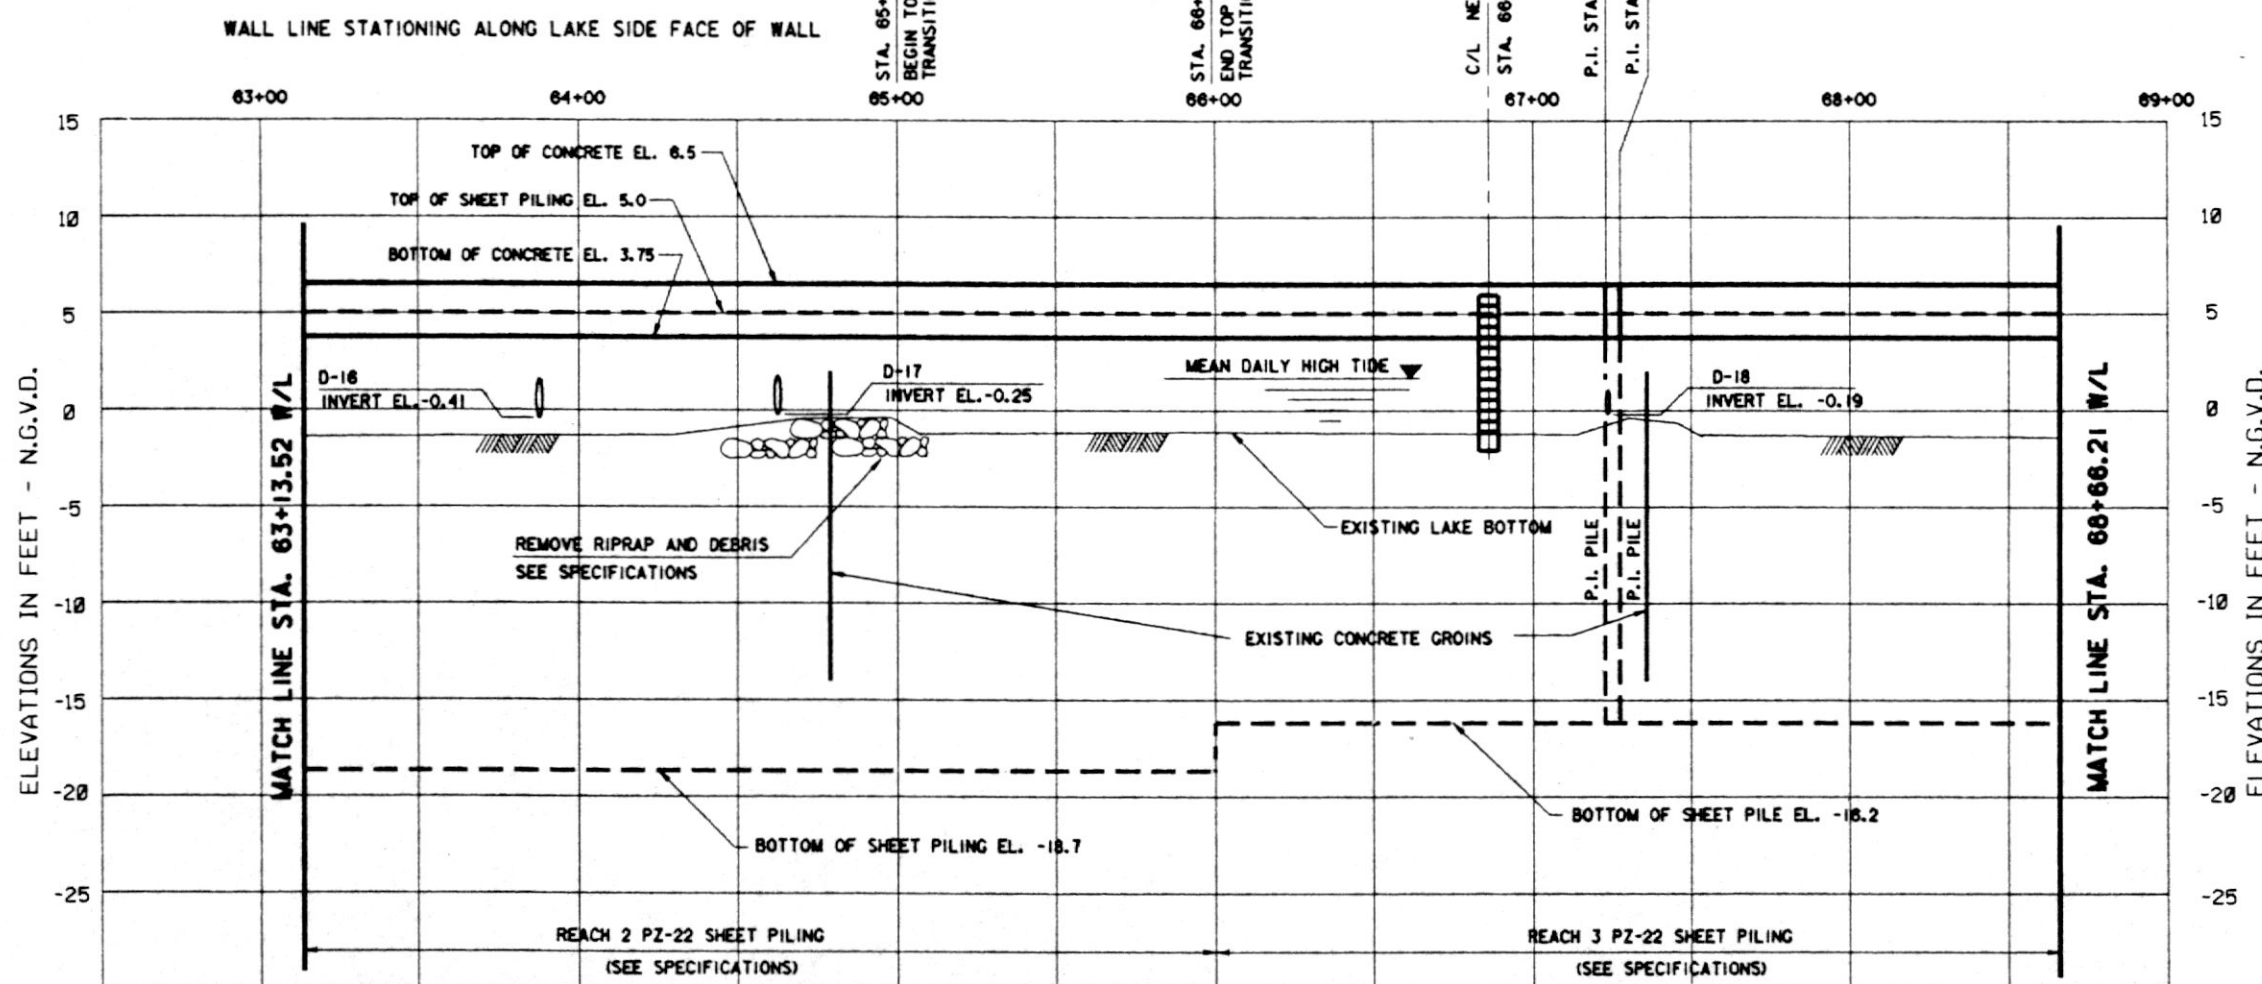SCALE: 1"=30'



PROFILE

SCALE: 1" = 30' HORIZ.  
1" = 5' VERT.

WALL LINE DATA

| P.I. NO. | BASLINE STATION | DISTANCE FROM BASELINE | WALL LINE STATION |
|----------|-----------------|------------------------|-------------------|
| 49       | 156 + 16.00     | 31.91 RT.              | 63 + 13.52        |
| 50       | 160 + 24.00     | 32.18 RT.              | 67 + 22.12        |
| 51       | 160 + 24.55     | 36.80 RT.              | 67 + 26.76        |
| 52       | 161 + 64.00     | 36.91 RT.              | 68 + 66.21        |

CONSTRUCTION SERVITUDE

| LAND SIDE |             |                            | LAKE SIDE |             |                            |
|-----------|-------------|----------------------------|-----------|-------------|----------------------------|
| P.I. NO.  | B/L STATION | DISTANCE MEASURED FROM B/L | P.I. NO.  | B/L STATION | DISTANCE MEASURED FROM B/L |
| 162       | 156+16.0    | 9.6' LT.                   | 321       | 156+16.0    | 46.1' RT.                  |
| 163       | 156+86.7    | 9.6' LT.                   | 322       | 161+64.0    | 45.7' RT.                  |
| 164       | 156+82.6    | 32.9' LT.                  |           |             |                            |
| 165       | 157+10.2    | 32.9' LT.                  |           |             |                            |
| 166       | 157+14.2    | 9.6' LT.                   |           |             |                            |
| 167       | 158+75.0    | 9.6' LT.                   |           |             |                            |
| 168       | 158+60.9    | 32.9' LT.                  |           |             |                            |
| 169       | 158+96.0    | 32.9' LT.                  |           |             |                            |
| 170       | 159+10.1    | 9.6' LT.                   |           |             |                            |
| 171       | 159+22.1    | 9.6' LT.                   |           |             |                            |
| 172       | 159+22.1    | 0.0'                       |           |             |                            |
| 173       | 161+64.0    | 0.0'                       |           |             |                            |

EXISTING FACILITIES

| ITEM  | DESCRIPTION              | B/L STATION      | OWNER              | DISPOSITION   |
|-------|--------------------------|------------------|--------------------|---------------|
| AP-1  | ASPHALT PATH             | 156+16 TO 161+64 | CITY OF MANDEVILLE | TO REMAIN     |
| DL-11 | 24" CLAY PIPE DRAIN LINE | 156+79.4         | CITY OF MANDEVILLE | CONTR. RELOC. |
| MS-9  | METAL SIGN & POST        | 157+06.3         | CITY OF MANDEVILLE | OWNER RELOC.  |
| MS-10 | METAL SIGN & POST        | 156+73.6         | CITY OF MANDEVILLE | OWNER RELOC.  |
| DL-12 | 24" CLAY PIPE DRAIN LINE | 157+54           | CITY OF MANDEVILLE | CONTR. RELOC. |
| B-2   | WOODEN BENCH             | 158+11           | CITY OF MANDEVILLE | TO REMAIN     |
| ST-10 | CONCRETE STEPS           | 159+84.3         | CITY OF MANDEVILLE | CONTR. RELOC. |
| B-3   | WOODEN BENCH             | 161+09           | CITY OF MANDEVILLE | TO REMAIN     |

\* CONTRACTOR NOT TO DISTURB

\*\* CONTRACTOR TO REPAIR CONSTRUCTION DAMAGE

000 DENOTES CONSTRUCTION SERVITUDE P.I. NUMBERS

6 DENOTES WALL LINE P.I. NUMBERS

NOTES:

- FOR GENERAL NOTES, SEE DWG. 2
- FOR LEGEND, SEE DWG. 3
- FOR GROIN MODIFICATIONS, SEE DWG. 24
- FOR WALL TRANSITION DETAILS, SEE DWG. 25
- FOR DRAIN DETAILS, SEE DWG. 26
- FOR STAIR DETAILS, SEE DWG. 27
- FOR SOIL BORING LOGS, SEE DWG. 30
- FOR LAKE HYDROGRAPH, SEE DWG. 31
- STAKES AND GUY WIRES AROUND SMALL TREES NOT SHOWN. CONTRACTOR TO MAINTAIN.
- EXTENT OF RIPRAP ON LAKE BOTTOM AND DEBRIS BEHIND WALL MAY VARY FROM THAT SHOWN.

THIS PLAN ACCOMPANIES  
MODIFICATION P0000  
TO CONTRACT NUMBER  
DACW29-94-C-0031

SCALE: 1" = 30'

30' 0 30' 60' 90' 120'

SCALE: 1" = 5'

5' 0 5' 10' 15' 20'

| SYMBOL | DESCRIPTION                                                              | DATE   | APPROVED |
|--------|--------------------------------------------------------------------------|--------|----------|
|        | REVISED TOP OF WALL AND SHEET PILING AND BOTTOM OF WALL IN PROFILE, MOD. | 4-5-94 | N.O.B.   |

U. S. ARMY ENGINEER DISTRICT, NEW ORLEANS  
CORPS OF ENGINEERS  
NEW ORLEANS, LOUISIANA

BC Brown Cunningham Gannuch  
ENGINEERS • ARCHITECTS • CONSULTANTS


MANDEVILLE SEAWALL, LA.  
REPLACEMENT OF MANDEVILLE SEAWALL  
ST. TAMMANY PARISH, LOUISIANA

PLAN AND PROFILE  
STA. 63+13.52 W/L TO STA. 68+66.21 W/L

|                                     |                                   |                    |                      |
|-------------------------------------|-----------------------------------|--------------------|----------------------|
| DESIGNED BY: R.W.Y.                 | DATE: NOV. 1993                   | PLOT SCALE: 360    | PLOT DATE: NOV. 1993 |
| DRAWN BY: J.S.B.                    | CADD FILE: 40335-13.DGN           | FILE NO: H-4-40335 |                      |
| CHECKED BY: T.P.H.                  | SOLICITATION NO: DACW29-94-B-0024 | DWG. 13 OF 31      |                      |
| SUBMITTED BY: ROBERT W. YOKUM, P.E. | DESIGN ENGINEER                   |                    |                      |



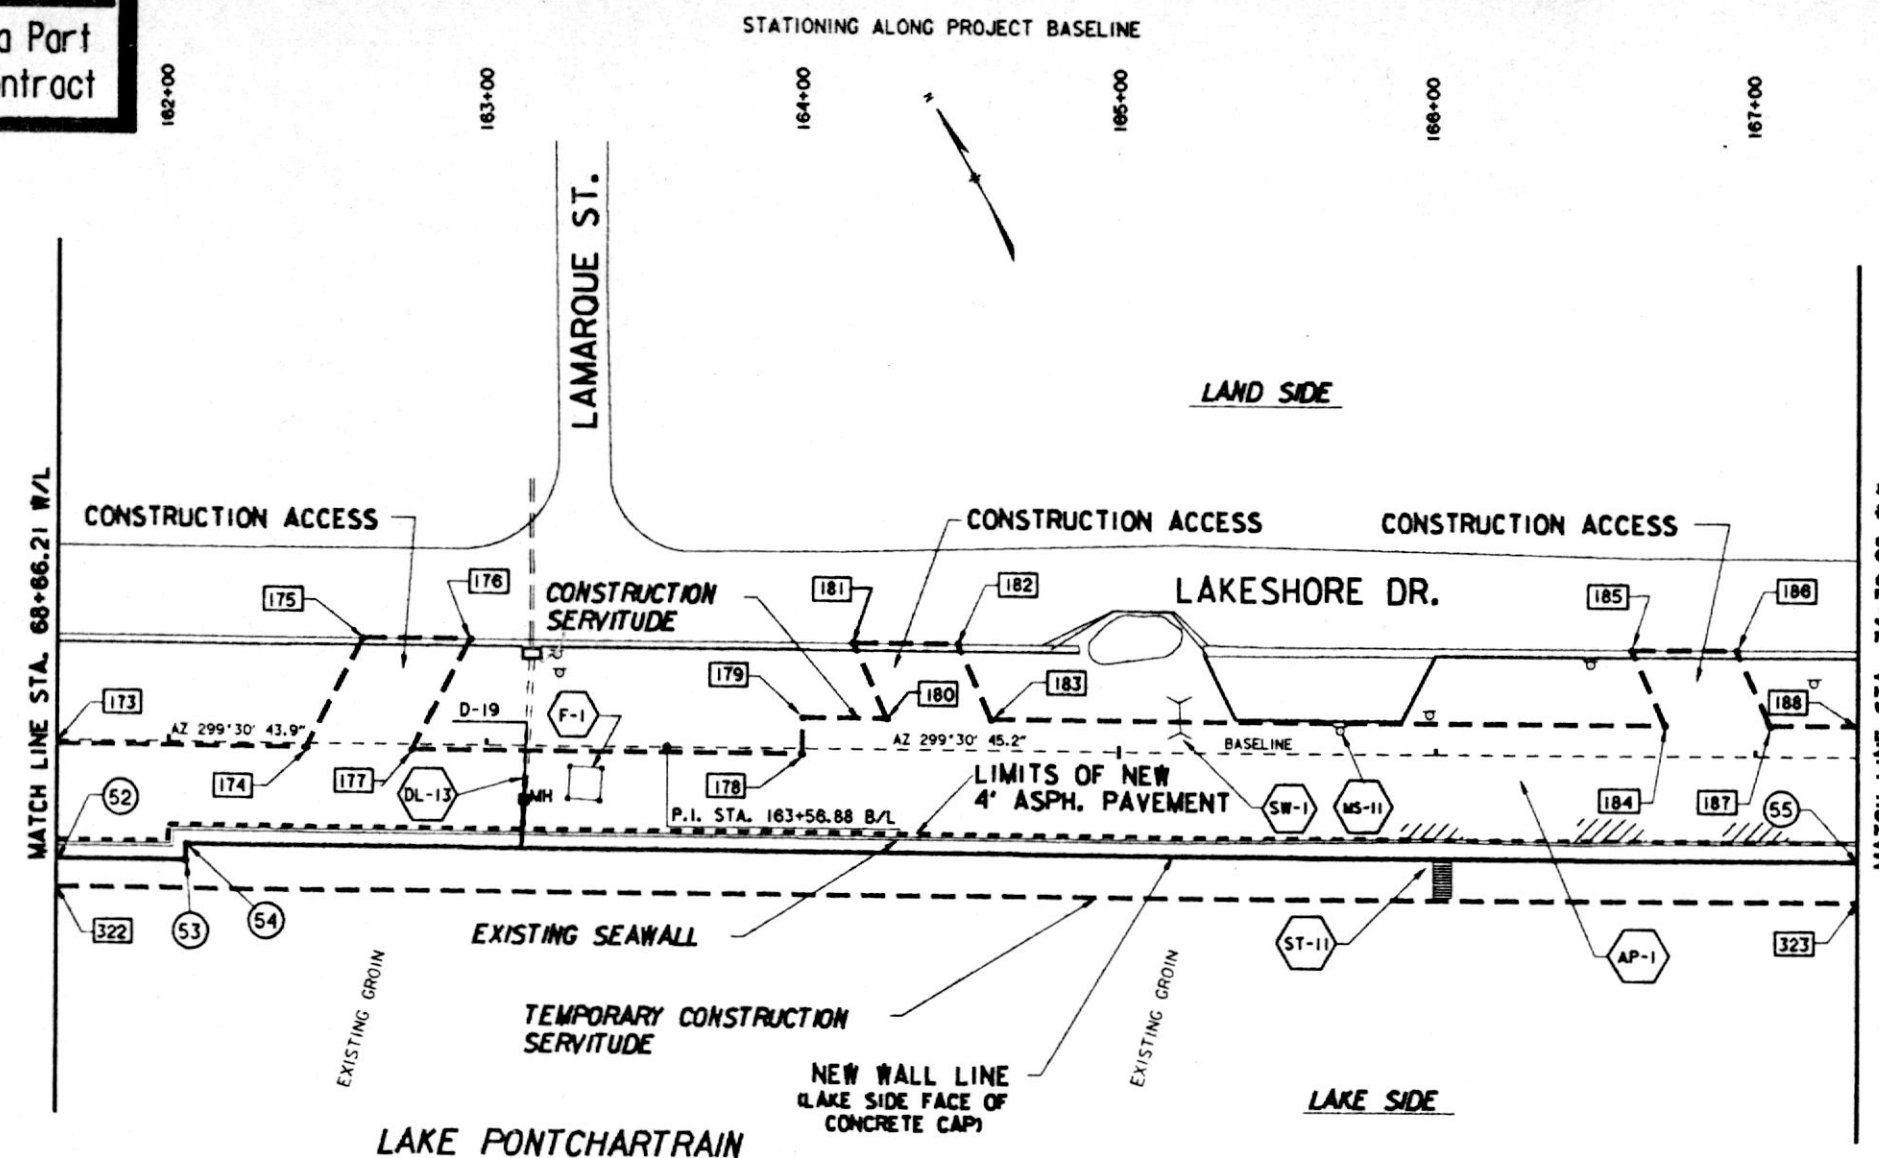Safety is a Part  
of Your Contract



| WALL LINE DATA |                  |                        |                   |            |
|----------------|------------------|------------------------|-------------------|------------|
| P.I. NO.       | BASELINE STATION | DISTANCE FROM BASELINE | WALL LINE STATION |            |
| 52             | 161 + 64.00      | 36.91                  | RT.               | 68 + 66.21 |
| 53             | 162 + 05.64      | 36.95                  | RT.               | 69 + 07.85 |
| 54             | 162 + 05.71      | 31.82                  | RT.               | 69 + 12.98 |
| 55             | 167 + 32.00      | 32.66                  | RT.               | 74 + 39.28 |

| CONSTRUCTION SERVITUDE |             |                            | TEMPORARY CONSTRUCTION SERVITUDE |             |                            |
|------------------------|-------------|----------------------------|----------------------------------|-------------|----------------------------|
| LAND SIDE              |             |                            | LAKE SIDE                        |             |                            |
| P.I. NO.               | B/L STATION | DISTANCE MEASURED FROM B/L | P.I. NO.                         | B/L STATION | DISTANCE MEASURED FROM B/L |
| 173                    | 161+64.0    | 0.0'                       | 322                              | 161+64.0    | 45.7' RT.                  |
| 174                    | 162+43.6    | 0.0'                       | 323                              | 167+32.0    | 45.3' RT.                  |
| 175                    | 162+60.9    | 32.9' LT.                  |                                  |             |                            |
| 176                    | 162+94.8    | 32.9' LT.                  |                                  |             |                            |
| 177                    | 162+77.5    | 0.0'                       |                                  |             |                            |
| 178                    | 164+00.0    | 0.0'                       |                                  |             |                            |
| 179                    | 164+00.0    | 9.6' LT.                   |                                  |             |                            |
| 180                    | 164+26.9    | 9.6' LT.                   |                                  |             |                            |
| 181                    | 164+15.8    | 32.9' LT.                  |                                  |             |                            |
| 182                    | 164+49.2    | 32.9' LT.                  |                                  |             |                            |
| 183                    | 164+59.7    | 9.6' LT.                   |                                  |             |                            |
| 184                    | 166+71.6    | 9.6' LT.                   |                                  |             |                            |
| 185                    | 166+61.1    | 32.9' LT.                  |                                  |             |                            |
| 186                    | 166+94.0    | 32.9' LT.                  |                                  |             |                            |
| 187                    | 167+04.5    | 9.6' LT.                   |                                  |             |                            |
| 188                    | 167+32.0    | 9.6' LT.                   |                                  |             |                            |

| EXISTING FACILITIES |                          |                  |                    |               |
|---------------------|--------------------------|------------------|--------------------|---------------|
| ITEM                | DESCRIPTION              | B/L STATION      | OWNER              | DISPOSITION   |
| AP-1                | ASPHALT PATH             | 161+64 TO 167+32 | CITY OF MANDEVILLE | TO REMAIN     |
| DL-13               | 18" CLAY PIPE DRAIN LINE | 163+11.2         | CITY OF MANDEVILLE | CONTR. RELOC. |
| F-1                 | SPLIT RAIL FENCE         | 163+31.1         | CITY OF MANDEVILLE | NOT AFFECTED  |
| SW-1                | SWING                    | 165+18.7         | CITY OF MANDEVILLE | OWNER RELOC.  |
| MS-11               | METAL SIGN & POST        | 165+69.4         | CITY OF MANDEVILLE | OWNER RELOC.  |
| ST-11               | CONCRETE STEPS           | 166+02.4         | CITY OF MANDEVILLE | CONTR. REMOVE |


- CONTRACTOR TO REPAIR CONSTRUCTION DAMAGE
- CONTRACTOR NOT TO DISTURB

000 DENOTES CONSTRUCTION SERVITUDE P.I. NUMBERS


6 DENOTES WALL LINE P.I. NUMBERS

#### NOTES:

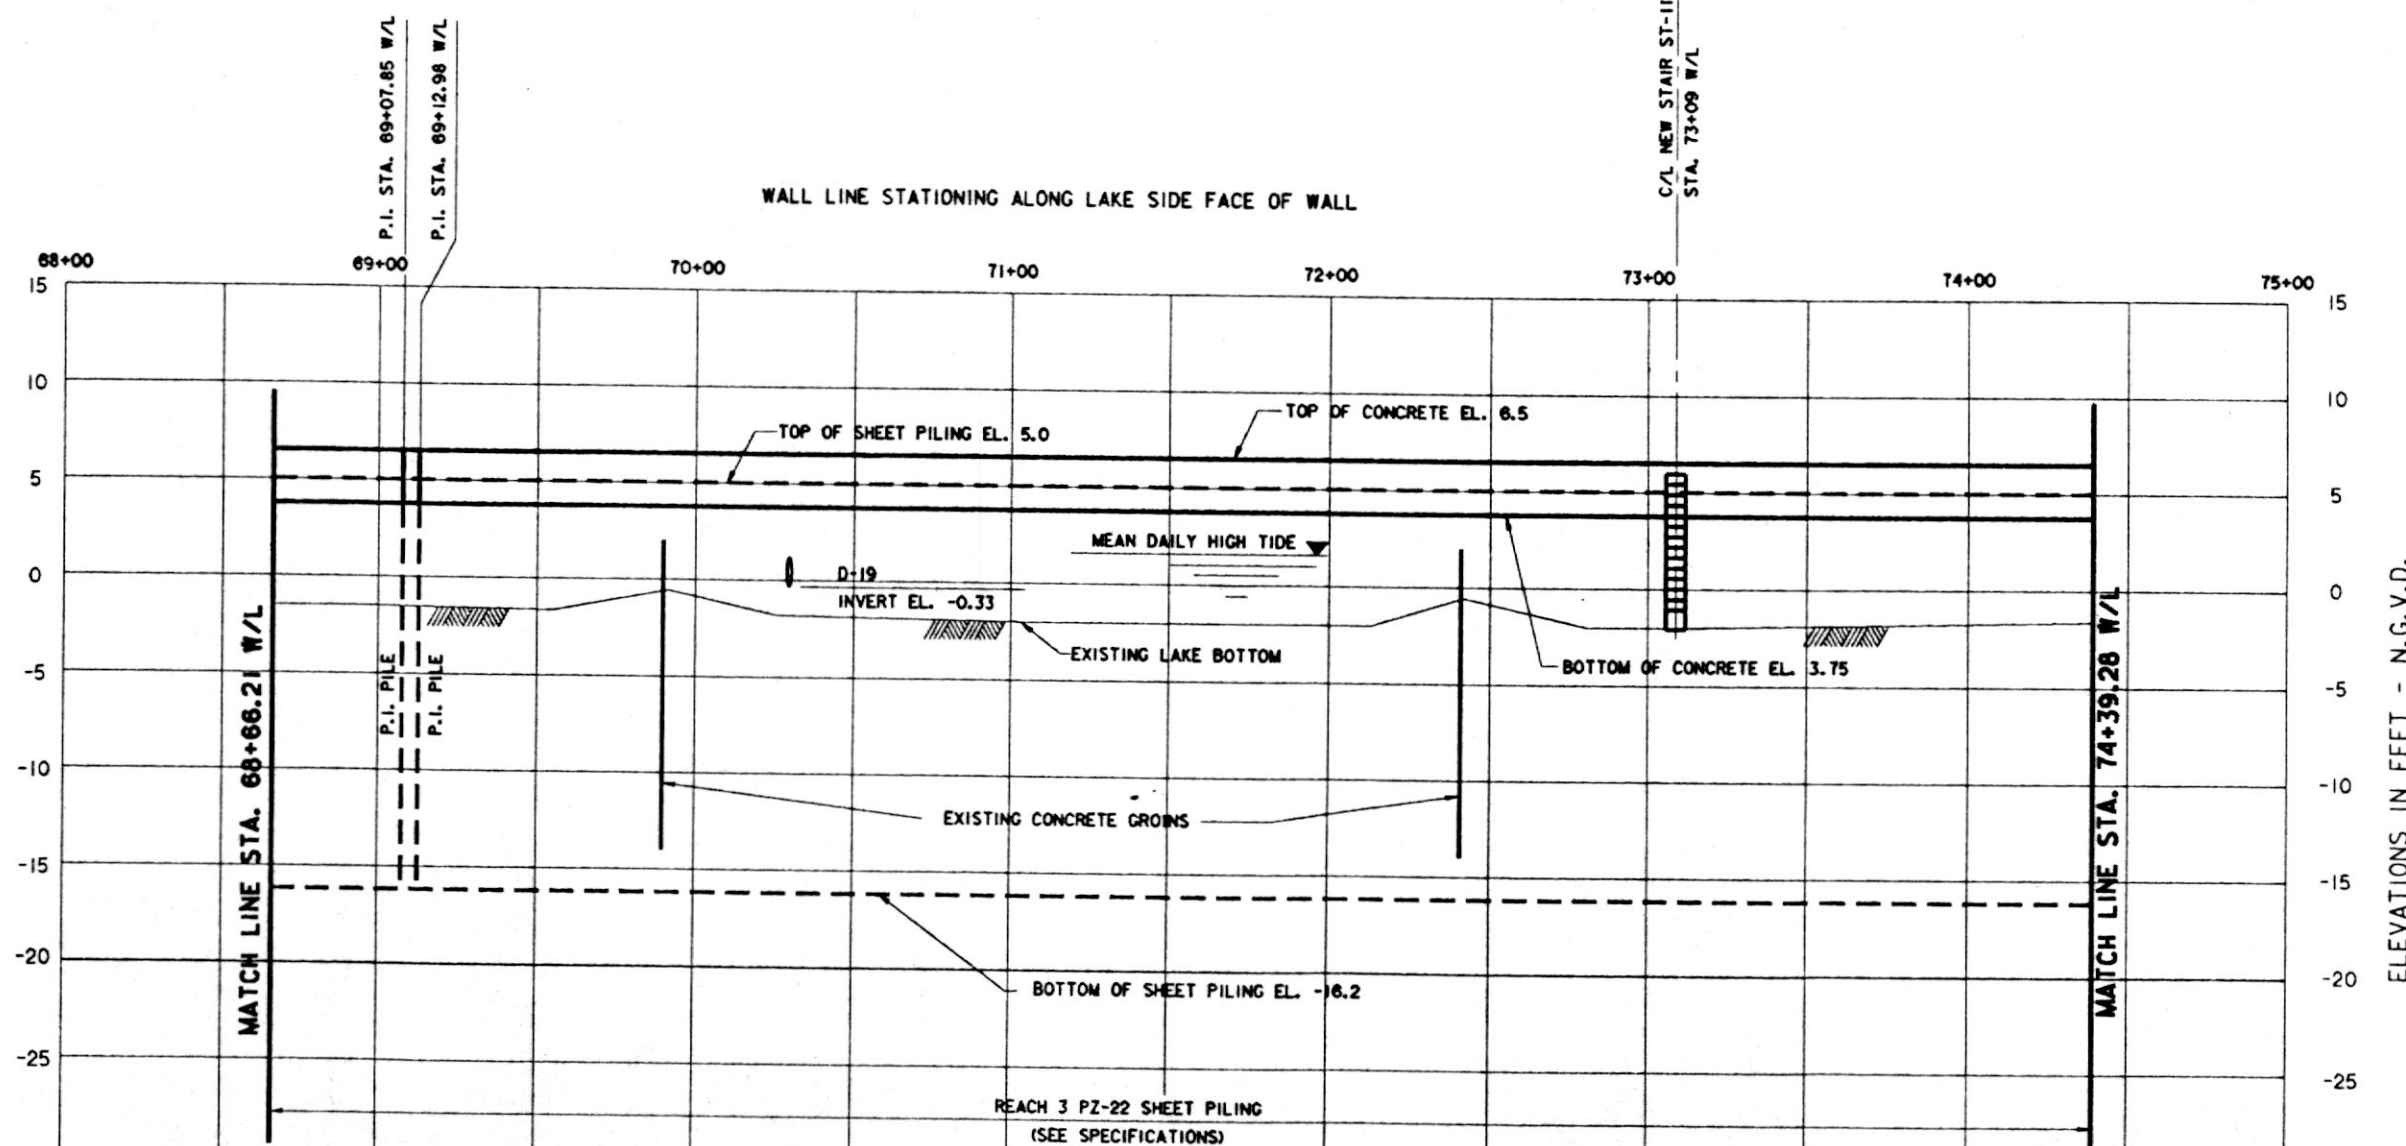- FOR GENERAL NOTES, SEE DWG. 2
- FOR LEGEND, SEE DWG. 3
- FOR GROIN MODIFICATIONS, SEE DWG. 24
- FOR WALL TRANSITION DETAILS, SEE DWG. 25
- FOR DRAIN DETAILS, SEE DWG. 26
- FOR STAIR DETAILS, SEE DWG. 27
- FOR SOIL BORING LOGS, SEE DWG. 30
- FOR LAKE HYDROGRAPH, SEE DWG. 31
- STAKES AND GUY WIRES AROUND SMALL TREES NOT SHOWN. CONTRACTOR TO MAINTAIN. EXTENT OF RIPRAP ON LAKE BOTTOM AND DEBRIS BEHIND WALL MAY VARY FROM THAT SHOWN.



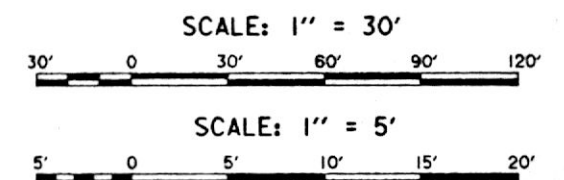
THIS PLAN ACCOMPANIES  
MODIFICATION P0000  
TO CONTRACT NUMBER  
DACW29-94-C-0031



| SYMBOL                                                                                                                                                            | REVISIONS                                                                              | DATE               | APPROVED             |
|-------------------------------------------------------------------------------------------------------------------------------------------------------------------|----------------------------------------------------------------------------------------|--------------------|----------------------|
|                                                                                                                                                                   | REVISED TOP OF WALL AND SHEET PILING IN PROFILE AND B/L DIST. IN W/L DATA SCHED.; MOD. | 4-5-94             | W.O.B.               |
| REVISIONS                                                                                                                                                         |                                                                                        |                    |                      |
| U. S. ARMY ENGINEER DISTRICT, NEW ORLEANS<br>CORPS OF ENGINEERS<br>NEW ORLEANS, LOUISIANA                                                                         |                                                                                        |                    |                      |
| Brown Cunningham Gannuch<br>ENGINEERS - ARCHITECTS - CONSULTANTS<br>MANDEVILLE SEAWALL, LA.<br>REPLACEMENT OF MANDEVILLE SEAWALL<br>ST. TAMMANY PARISH, LOUISIANA |                                                                                        |                    |                      |
| PLAN AND PROFILE<br>STA. 68+66.21 W/L TO STA. 74+39.28 W/L                                                                                                        |                                                                                        |                    |                      |
| DESIGNED BY: R.W.Y.                                                                                                                                               | DATE: NOV. 1993                                                                        | PLOT SCALE: 360    | PLOT DATE: NOV. 1993 |
| DRAWN BY: J.S.B.                                                                                                                                                  |                                                                                        |                    |                      |
| CHECKED BY: T.P.H.                                                                                                                                                |                                                                                        |                    |                      |
| SUBMITTED BY: ROBERT W. YOKUM, P.E.                                                                                                                               | SOLICITATION NO. DACW29-94-B-0024                                                      | FILE NO. H-4-40335 | DWG. 14 OF 31        |
| DESIGN ENGINEER                                                                                                                                                   |                                                                                        |                    |                      |



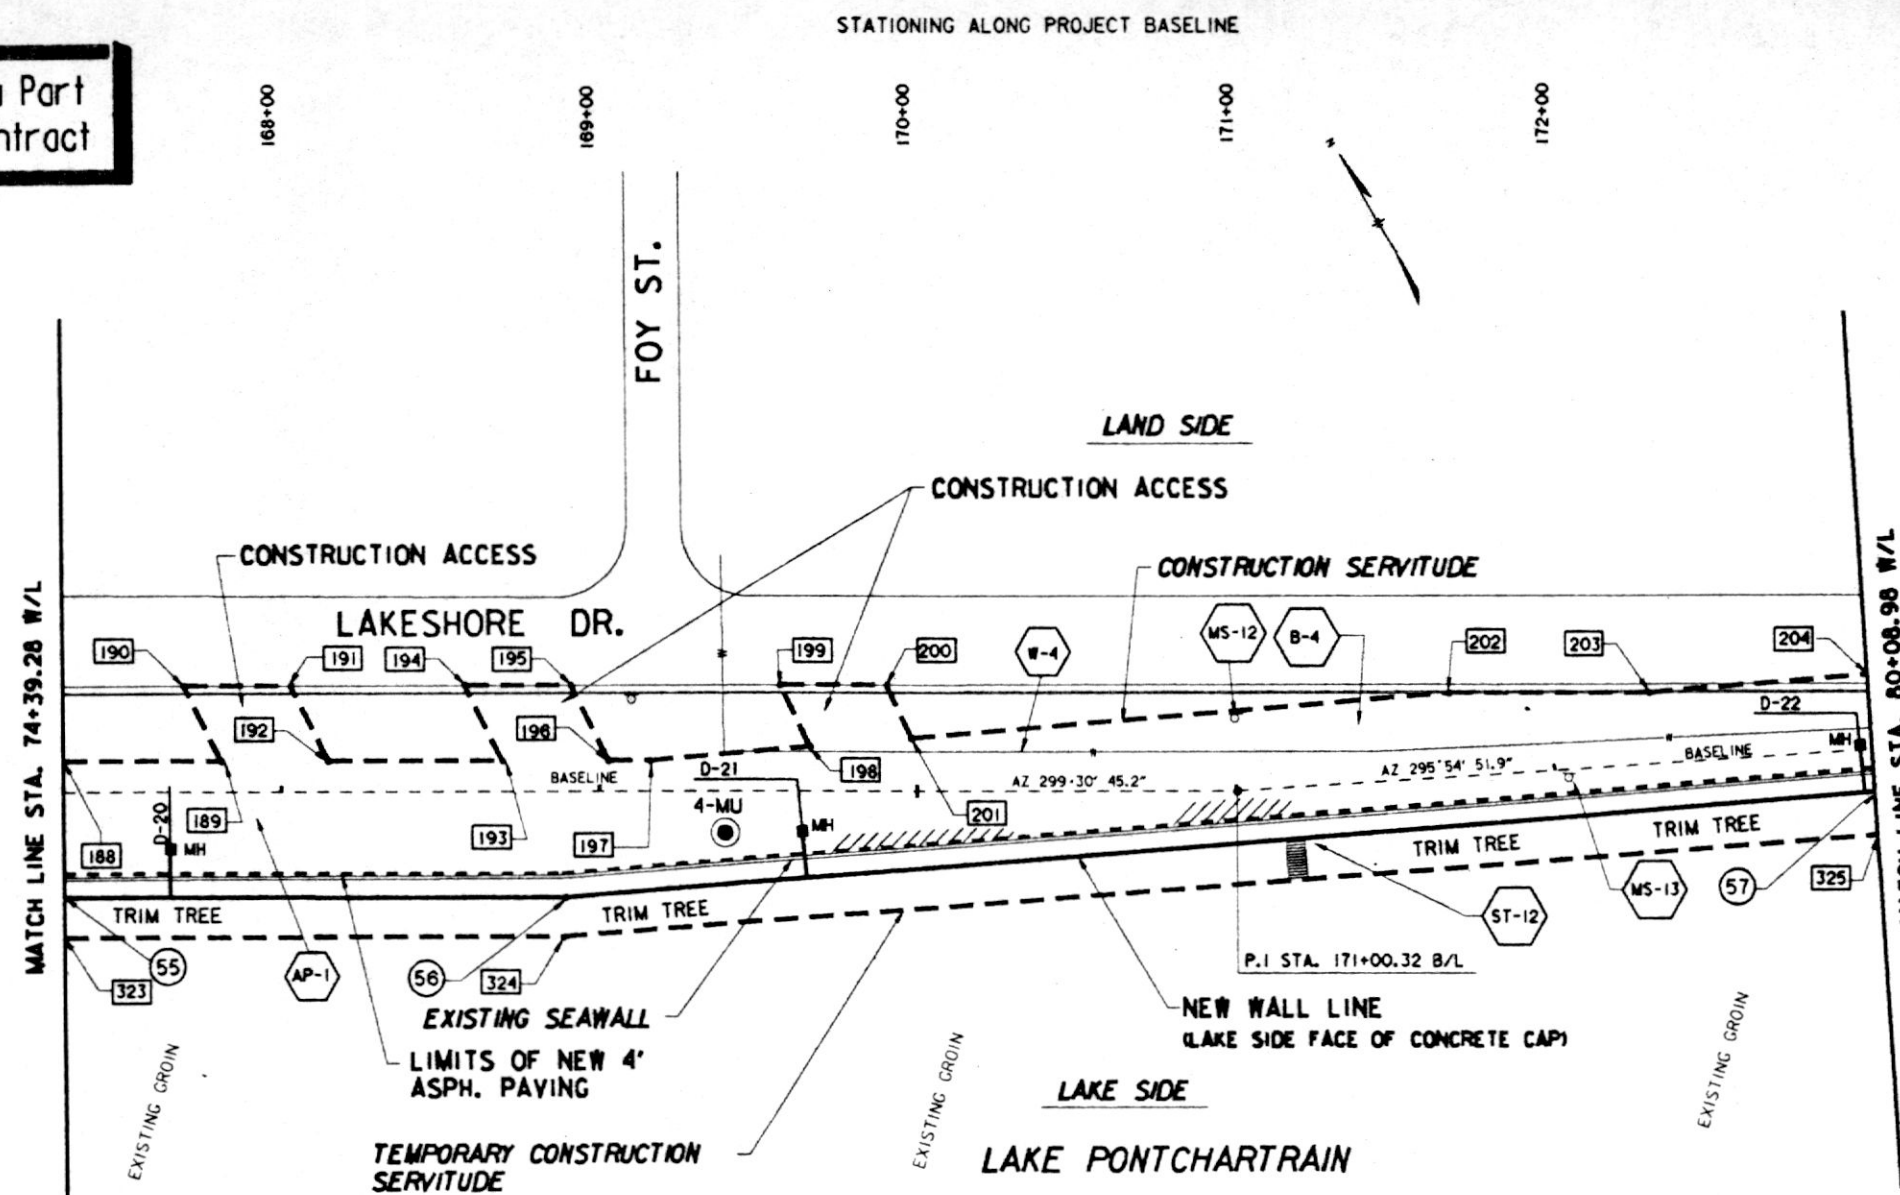Safety is a Part  
of Your Contract



| WALL LINE DATA |                  |                        |                   |            |
|----------------|------------------|------------------------|-------------------|------------|
| P.I. NO.       | BASELINE STATION | DISTANCE FROM BASELINE | WALL LINE STATION |            |
| 55             | 167 + 32.00      | 32.66                  | RT.               | 74 + 39.28 |
| 56             | 168 + 88.53      | 32.91                  | RT.               | 75 + 95.81 |
| 57             | 173 + 00.00      | 13.15                  | RT.               | 80 + 08.98 |

| CONSTRUCTION SERVITUDE |             |                            | TEMPORARY CONSTRUCTION SERVITUDE |             |                            |
|------------------------|-------------|----------------------------|----------------------------------|-------------|----------------------------|
| LAND SIDE              |             |                            | LAKE SIDE                        |             |                            |
| P.I. NO.               | B/L STATION | DISTANCE MEASURED FROM B/L | P.I. NO.                         | B/L STATION | DISTANCE MEASURED FROM B/L |
| 188                    | 167+32.0    | 9.6' LT.                   | 323                              | 167+32.0    | 45.3' RT.                  |
| 189                    | 167+81.2    | 9.6' LT.                   | 324                              | 168+88.2    | 45.2' RT.                  |
| 190                    | 167+69.6    | 33.0' LT.                  | 325                              | 172+98.7    | 26.6' RT.                  |
| 191                    | 168+03.1    | 33.0' LT.                  |                                  |             |                            |
| 192                    | 168+14.7    | 9.6' LT.                   |                                  |             |                            |
| 193                    | 168+69.2    | 9.6' LT.                   |                                  |             |                            |
| 194                    | 168+57.6    | 33.3' LT.                  |                                  |             |                            |
| 195                    | 168+91.0    | 33.1' LT.                  |                                  |             |                            |
| 196                    | 169+02.7    | 9.6' LT.                   |                                  |             |                            |
| 197                    | 169+15.7    | 9.6' LT.                   |                                  |             |                            |
| 198                    | 169+66.1    | 13.8' LT.                  |                                  |             |                            |
| 199                    | 169+56.8    | 33.1' LT.                  |                                  |             |                            |
| 200                    | 169+90.2    | 33.0' LT.                  |                                  |             |                            |
| 201                    | 169+98.1    | 16.5' LT.                  |                                  |             |                            |
| 202                    | 171+68.1    | 26.3' LT.                  |                                  |             |                            |
| 203                    | 172+31.3    | 22.3' LT.                  |                                  |             |                            |
| 204                    | 173+01.9    | 23.4' LT.                  |                                  |             |                            |

| EXISTING FACILITIES |                       |                    |                    |               |
|---------------------|-----------------------|--------------------|--------------------|---------------|
| ITEM                | DESCRIPTION           | B/L STATION        | OWNER              | DISPOSITION   |
| AP-1                | ASPHALT PATH          | 167+32 TO 169+16   | CITY OF MANDEVILLE | TO REMAIN     |
| W-4                 | 8" WATER MAIN         | 169+47.5 TO 173+00 | CITY OF MANDEVILLE | NOT AFFECTED  |
| MS-12               | METAL SIGN & POST     | 170+99.5           | CITY OF MANDEVILLE | OWNER RELOC.  |
| ST-12               | CONCRETE STEPS        | 171+17.3           | CITY OF MANDEVILLE | CONTR. REMOVE |
| B-4                 | CONCRETE SLAB & BENCH | 171+37.5           | CITY OF MANDEVILLE | TO REMAIN     |
| MS-13               | METAL SIGN & POST     | 172+04.6           | CITY OF MANDEVILLE | OWNER RELOC.  |

- \* CONTRACTOR NOT TO DISTURB
- \*\* CONTRACTOR TO REPAIR CONSTRUCTION DAMAGE
- 0000 DENOTES CONSTRUCTION SERVITUDE P.I. NUMBERS
- 6 DENOTES WALL LINE P.I. NUMBERS

#### NOTES:

- FOR GENERAL NOTES, SEE DWG. 2
- FOR LEGEND, SEE DWG. 3
- FOR GROIN MODIFICATIONS, SEE DWG. 24
- FOR WALL TRANSITION DETAILS, SEE DWG. 25
- FOR DRAIN DETAILS, SEE DWG. 26
- FOR STAIR DETAILS, SEE DWG. 27
- FOR SOIL BORING LOGS, SEE DWG. 30
- FOR LAKE HYDROGRAPH, SEE DWG. 31
- STAKES AND GUY WIRES AROUND SMALL TREES NOT SHOWN. CONTRACTOR TO MAINTAIN. EXTENT OF RIPRAP ON LAKE BOTTOM AND DEBRIS BEHIND WALL MAY VARY FROM THAT SHOWN.

SCALE: 1" = 30'

30' 0 30' 60' 90' 120'

SCALE: 1" = 5'

5' 0 5' 10' 15' 20'

| SYMBOL | DESCRIPTION                                                             | DATE   | APPROVED |
|--------|-------------------------------------------------------------------------|--------|----------|
| Δ      | REVISED TOP OF WALL AND SHEET PILING IN PROFILE AND W/L STATIONING MOD. | 4-5-94 | W.O.B.   |

| REVISIONS |  |  |  |
|-----------|--|--|--|
| 1         |  |  |  |

U. S. ARMY ENGINEER DISTRICT, NEW ORLEANS  
CORPS OF ENGINEERS  
NEW ORLEANS, LOUISIANA

BC Brown Cunningham Gannuch  
ENGINEERS - ARCHITECTS - CONSULTANTS  
MANDEVILLE SEAWALL, LA.  
REPLACEMENT OF MANDEVILLE SEAWALL  
ST. TAMMANY PARISH, LOUISIANA

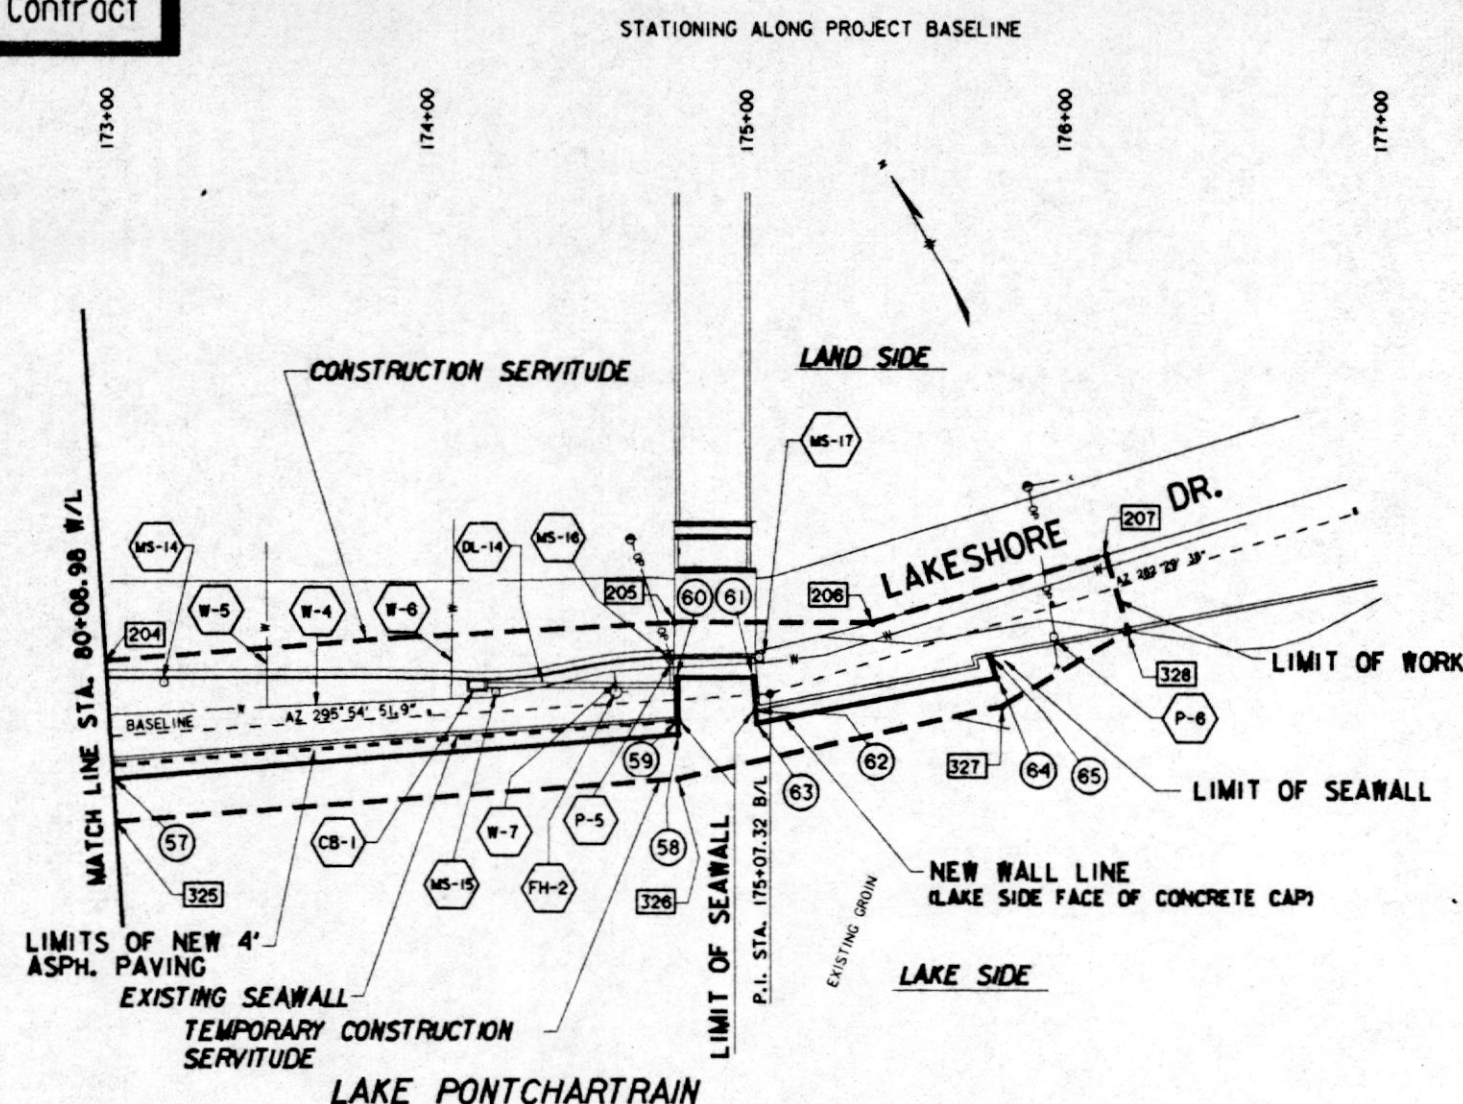
#### PLAN AND PROFILE

STA. 74+39.28 W/L TO STA. 80+08.98 W/L

|                                     |                                   |                    |                      |
|-------------------------------------|-----------------------------------|--------------------|----------------------|
| DESIGNED BY: R.W.Y.                 | DATE: NOV. 1993                   | PLOT SCALE: 360    | PLOT DATE: NOV. 1993 |
| DRAWN BY: J.S.B.                    | CADD FILE: 40335-15.DGN           | FILE NO: H-4-40335 |                      |
| CHECKED BY: T.P.H.                  | SOLICITATION NO. DACW29-94-B-0024 | DWG. 15 OF 31      |                      |
| SUBMITTED BY: ROBERT W. YOKUM, P.E. | DESIGN ENGINEER                   |                    |                      |




Safety is a Part  
of Your Contract



| WALL LINE DATA |                  |                        |                   |            |
|----------------|------------------|------------------------|-------------------|------------|
| P.I. NO.       | BASELINE STATION | DISTANCE FROM BASELINE | WALL LINE STATION |            |
| 57             | 173 + 00.00      | 13.15                  | RT.               | 80 + 08.98 |
| 58             | 174 + 77.37      | 10.41                  | RT.               | 81 + 86.37 |
| 59             | 174 + 77.61      | 6.41                   | RT.               | 81 + 90.38 |
| 60             | 174 + 78.41      | 6.90                   | LT.               | 82 + 03.71 |
| 61             | 175 + 02.13      | 5.63                   | LT.               | 82 + 27.47 |
| 62             | 175 + 02.24      | 4.68                   | RT.               | 82 + 37.79 |
| 63             | 175 + 02.47      | 8.70                   | RT.               | 82 + 41.80 |
| 64             | 175 + 76.43      | 15.94                  | RT.               | 83 + 18.13 |
| 65             | 175 + 76.42      | 8.98                   | RT.               | 83 + 25.09 |

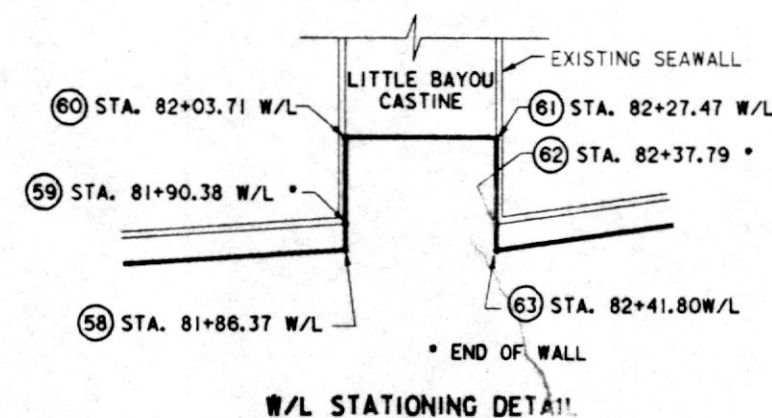\* LIMIT OF NEW SEAWALL



| CONSTRUCTION SERVITUDE |             |                            | TEMPORARY CONSTRUCTION SERVITUDE |             |                            |
|------------------------|-------------|----------------------------|----------------------------------|-------------|----------------------------|
| LAND SIDE              |             |                            | LAKE SIDE                        |             |                            |
| P.I. NO.               | B/L STATION | DISTANCE MEASURED FROM B/L | P.I. NO.                         | B/L STATION | DISTANCE MEASURED FROM B/L |
| 204                    | 173+01.9    | 23.4' LT.                  | 325                              | 172+98.7    | 26.6' RT.                  |
| 205                    | 174+78.5    | 24.2' LT.                  | 326                              | 174+76.5    | 24.4' RT.                  |
| 206                    | 175+44.5    | 11.8' LT.                  | 327                              | 175+75.5    | 24.8' RT.                  |
| 207                    | 176+20.7    | 10.8' LT.                  | 328                              | 176+20.5    | 14.0' RT.                  |

| EXISTING FACILITIES |                                    |                      |                    |              |
|---------------------|------------------------------------|----------------------|--------------------|--------------|
| ITEM                | DESCRIPTION                        | B/L STATION          | OWNER              | DISPOSITION  |
| * W-4               | 8" WATER MAIN                      | 173+00 TO 176+20.7   | CITY OF MANDEVILLE | NOT AFFECTED |
| MS-14               | METAL SIGN & POST                  | 173+17.9             | CITY OF MANDEVILLE | OWNER RELOC. |
| * W-5               | 2" WATER LINE                      | 173+50.4             | CITY OF MANDEVILLE | NOT AFFECTED |
| * W-6               | 2" WATER LINE                      | 174+08.5             | CITY OF MANDEVILLE | NOT AFFECTED |
| * CB-1              | CATCH BASIN                        | 174+15.5             | CITY OF MANDEVILLE | NOT AFFECTED |
| * DL-14             | 18" RCP DRAIN LINE                 | 174+18.5 TO 174+78.3 | CITY OF MANDEVILLE | NOT AFFECTED |
| MS-15               | METAL SIGN & POST                  | 174+21.1             | CITY OF MANDEVILLE | OWNER RELOC. |
| * W-7               | 2" WATER LINE                      | 173+50.4             | CITY OF MANDEVILLE | NOT AFFECTED |
| * FH-2              | FIRE HYDRANT                       | 174+58.6             | CITY OF MANDEVILLE | NOT AFFECTED |
| MS-16               | METAL SIGN & POST                  | 174+75.9             | CITY OF MANDEVILLE | OWNER RELOC. |
| P-5                 | UTILITY POLE & GUY WIRE W/O P LINE | 174+76.5             | CITY OF MANDEVILLE | OWNER RELOC. |
| MS-17               | METAL SIGN & POST                  | 175+04.2             | CITY OF MANDEVILLE | OWNER RELOC. |
| P-6                 | UTILITY POLE & GUY WIRE W/O P LINE | 175+97.4             | CITY OF MANDEVILLE | OWNER RELOC. |


\* CONTRACTOR NOT TO DISTURB

000 DENOTES CONSTRUCTION SERVITUDE P.I. NUMBERS


6 DENOTES WALL LINE P.I. NUMBERS

#### NOTES:

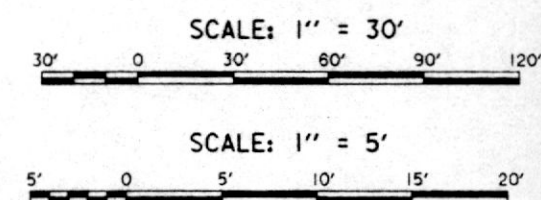- FOR GENERAL NOTES, SEE DWG. 2
- FOR LEGEND, SEE DWG. 3
- FOR GROIN MODIFICATIONS, SEE DWG. 24
- FOR WALL TRANSITION DETAILS, SEE DWG. 25
- FOR DRAIN DETAILS, SEE DWG. 26
- FOR STAIR DETAILS, SEE DWG. 27
- FOR SOIL BORING LOGS, SEE DWG. 30
- FOR LAKE HYDROGRAPH, SEE DWG. 31
- STAKES AND GUY WIRES AROUND SMALL TREES NOT SHOWN. CONTRACTOR TO MAINTAIN. EXTENT OF RIPRAP ON LAKE BOTTOM AND DEBRIS BEHIND WALL MAY VARY FROM THAT SHOWN.







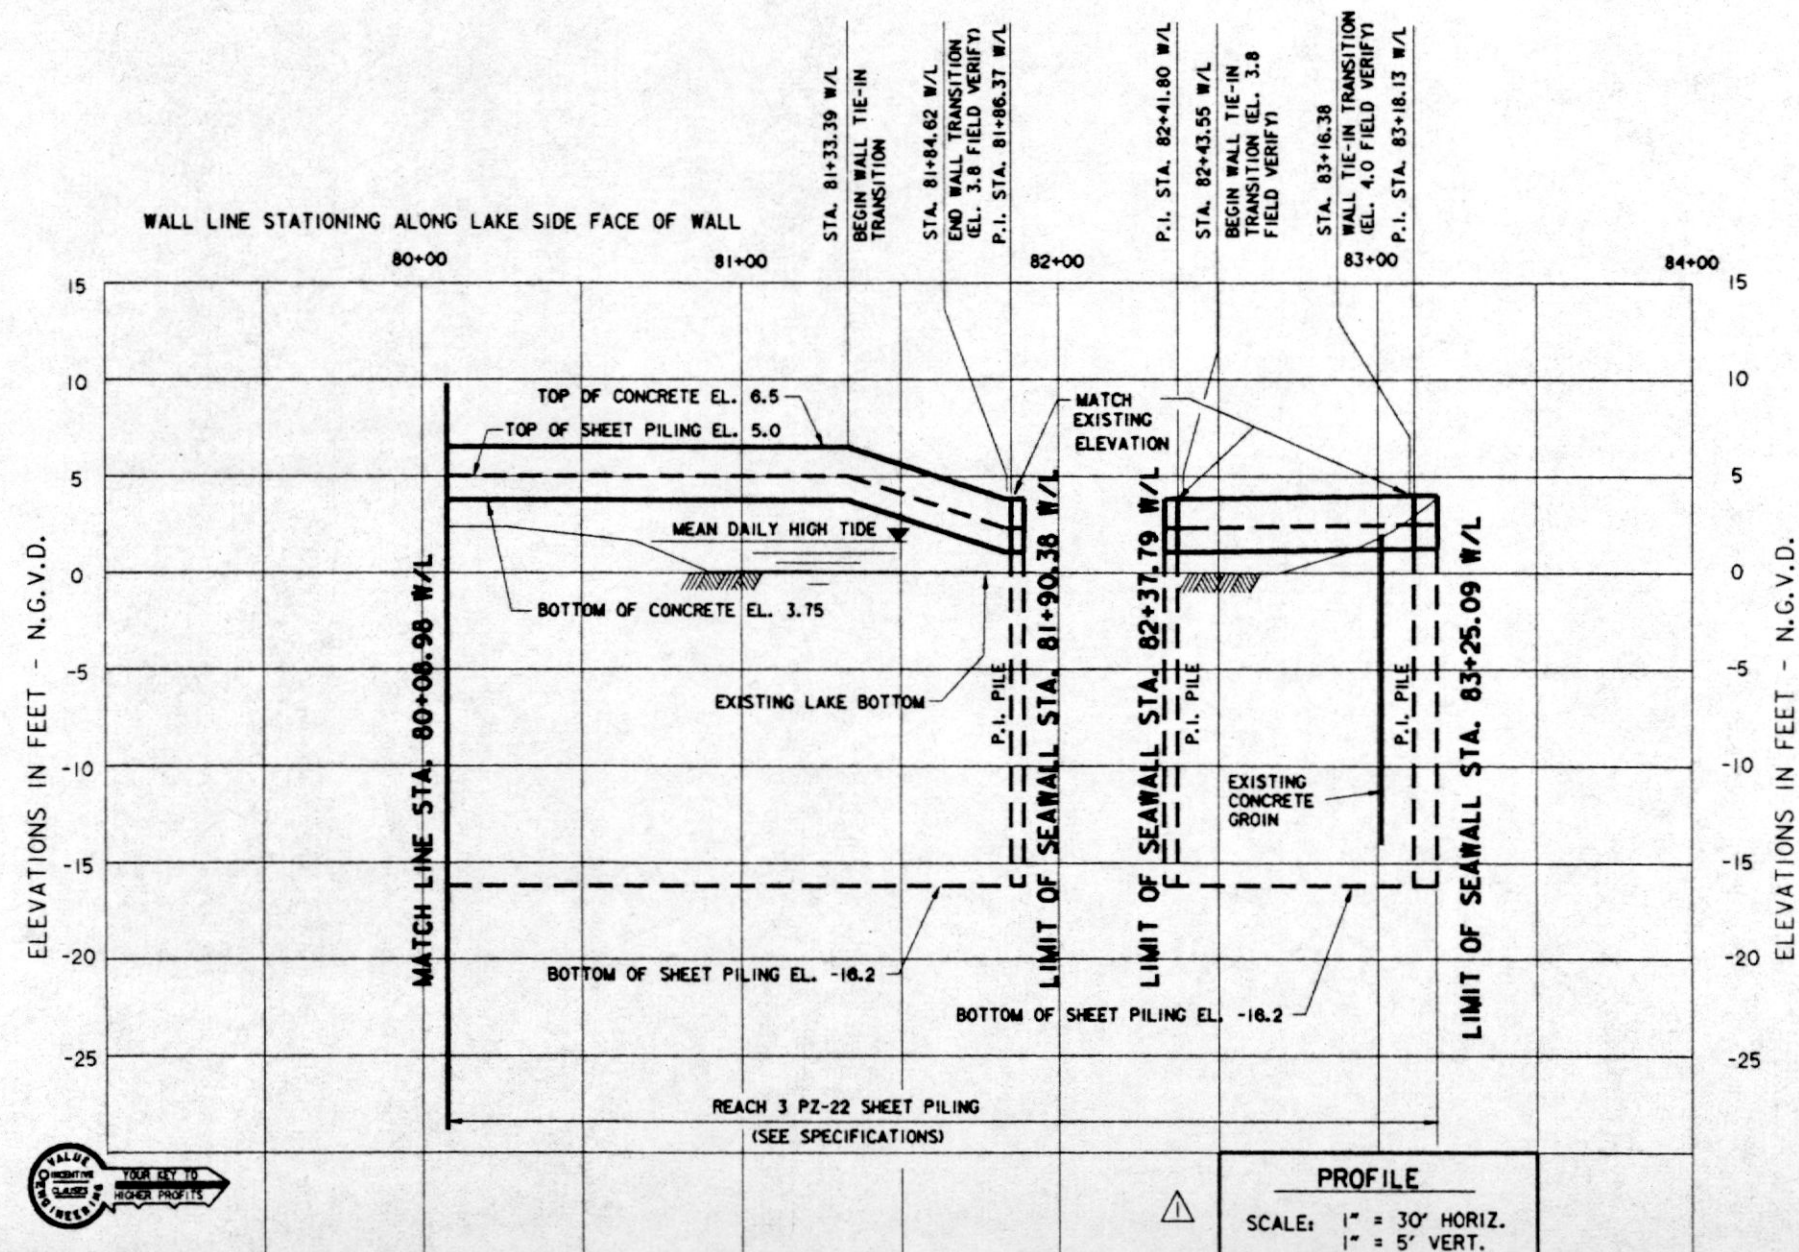THIS PLAN ACCOMPANIES  
MODIFICATION P0000  
TO CONTRACT NUMBER  
DACW29-94-C-0031




| REVISIONS                                                                                     |                                                                        | DATE               | DESCRIPTION          | APPROVED |
|-----------------------------------------------------------------------------------------------|------------------------------------------------------------------------|--------------------|----------------------|----------|
| Δ                                                                                             | REVISED TOP OF WALL AND SHEET PILING IN PROFILE AND W/L STATIONS, MOD. | 4-5-94             | W.O.B.               |          |
| U. S. ARMY ENGINEER DISTRICT, NEW ORLEANS<br>CORPS OF ENGINEERS<br>NEW ORLEANS, LOUISIANA     |                                                                        |                    |                      |          |
| Brown Cunningham Gannuch<br>ENGINEERS - ARCHITECTS - CONSULTANTS                              |                                                                        |                    |                      |          |
| MANDEVILLE SEAWALL, LA.<br>REPLACEMENT OF MANDEVILLE SEAWALL<br>ST. TAMMANY PARISH, LOUISIANA |                                                                        |                    |                      |          |
| PLAN AND PROFILE<br>STA. 80+08.98 W/L TO STA. 83+25.09 W/L                                    |                                                                        |                    |                      |          |
| DESIGNED BY: R.W.Y.                                                                           | DATE: NOV. 1993                                                        | PLOT SCALE: 360    | PLOT DATE: NOV. 1993 |          |
| DRAWN BY: J.S.B.                                                                              |                                                                        |                    |                      |          |
| CHECKED BY: T.P.H.                                                                            |                                                                        |                    |                      |          |
| SUBMITTED BY: ROBERT W. YOKUM, P.E.                                                           | SOLICITATION NO. DACW29-94-B-0024                                      | FILE NO. H-4-40335 | DWG. 16 OF 31        |          |



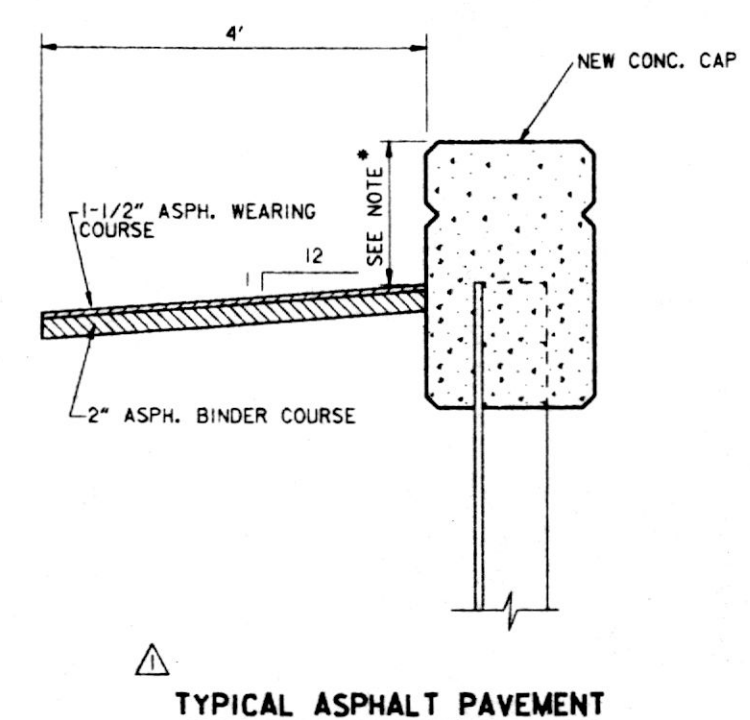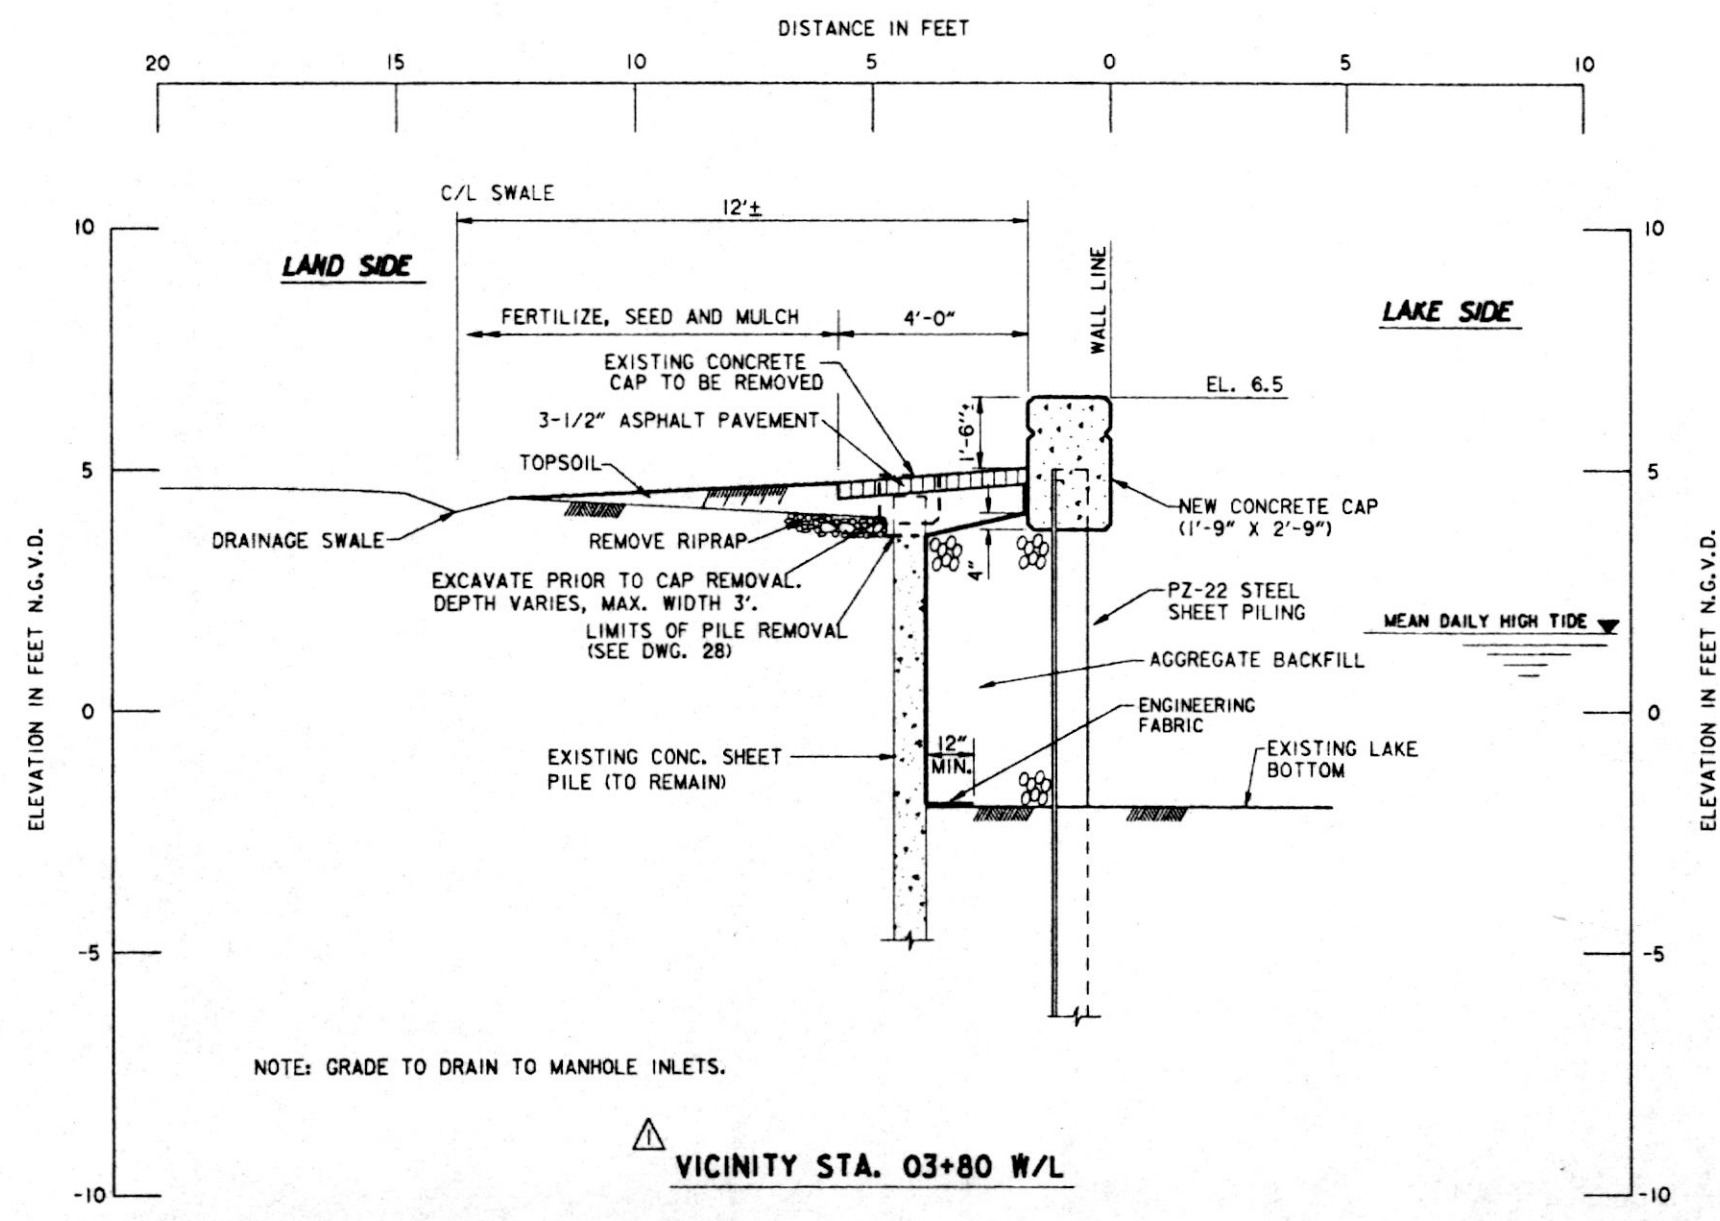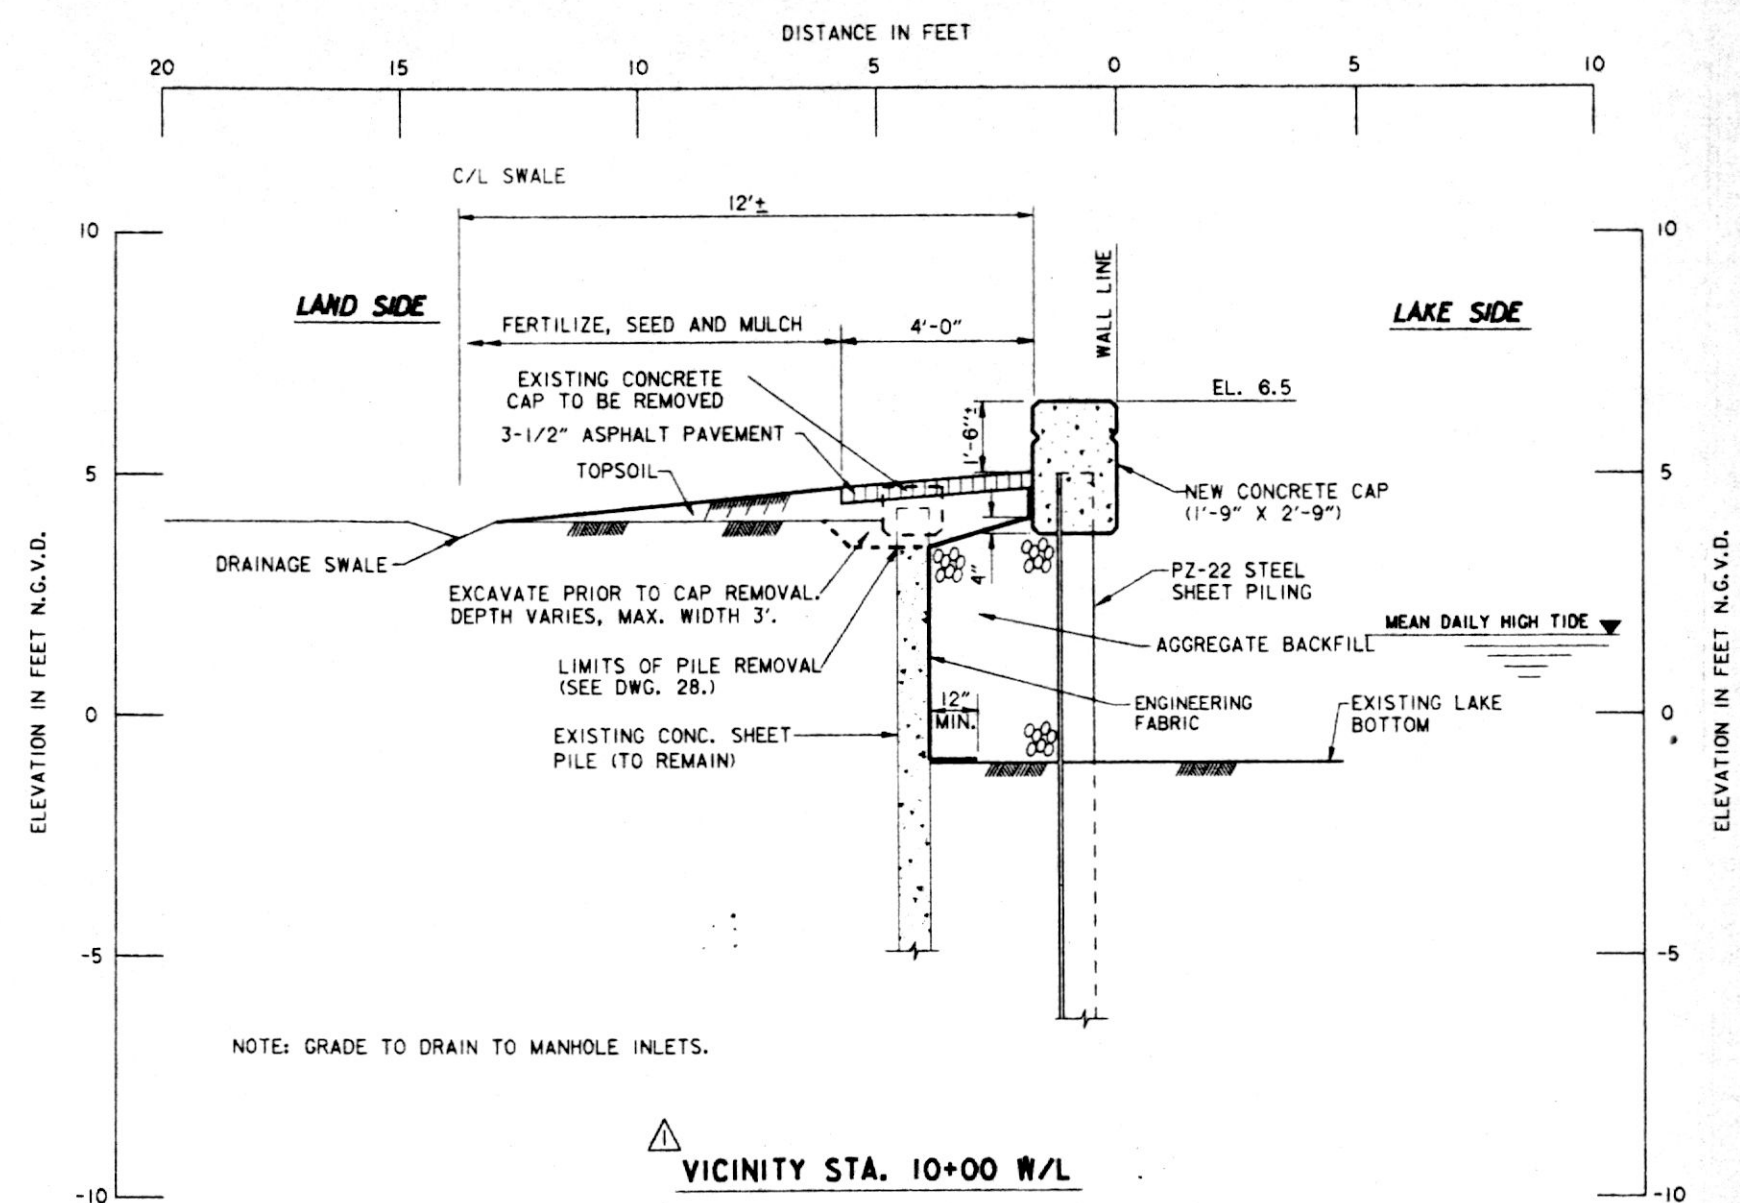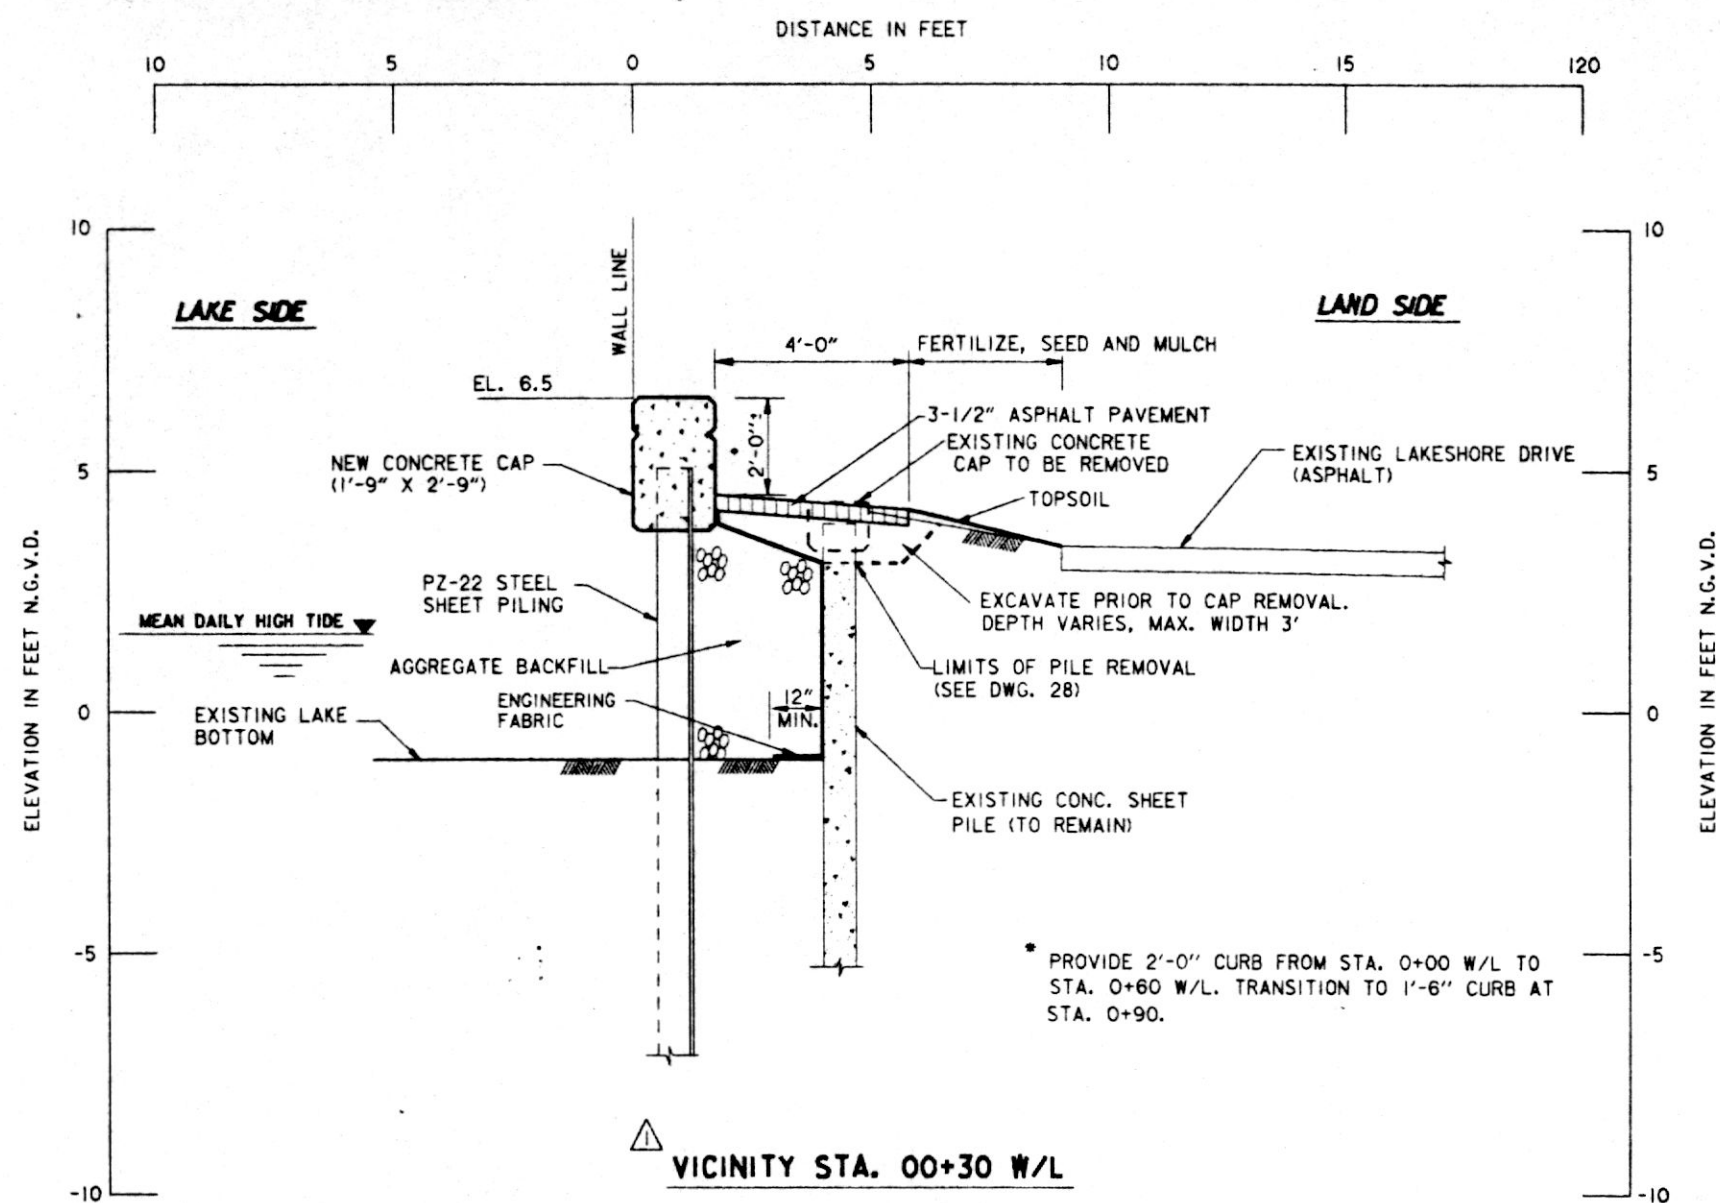




 
THIS PLAN ACCOMPANIES  
MODIFICATION P0000  
TO CONTRACT NUMBER  
DACW29-94-C-0031



|                                                                                               |                                   |                      |
|-----------------------------------------------------------------------------------------------|-----------------------------------|----------------------|
| REVISIONS                                                                                     | DATE                              | APPROVED             |
| REVISOR                                                                                       | DATE                              | APPROVED             |
| U. S. ARMY ENGINEER DISTRICT, NEW ORLEANS<br>CORPS OF ENGINEERS<br>NEW ORLEANS, LOUISIANA     | 4-5-94                            | W.O.B.               |
| Brown Cunningham Gannuch<br>ENGINEERS • ARCHITECTS • CONSULTANTS                              |                                   |                      |
| MANDEVILLE SEAWALL, LA.<br>REPLACEMENT OF MANDEVILLE SEAWALL<br>ST. TAMMANY PARISH, LOUISIANA |                                   |                      |
| TYPICAL SECTIONS<br>STA. 00+30 W/L TO STA. 10+00 W/L                                          |                                   |                      |
| DESIGNED BY: T.P.H.                                                                           | DATE: NOV. 1993                   | PLOT SCALE: 24       |
| DRAWN BY: S.F.S.                                                                              |                                   | PLOT DATE: NOV. 1993 |
| CHECKED BY: R.W.Y.                                                                            |                                   | FILE NO. H-4-40335   |
| SUBMITTED BY: ROBERT W. YOKUM, P.E.                                                           | SOLICITATION NO. DACW29-94-B-0024 | DWG. 17 OF 31        |
| DESIGN ENGINEER                                                                               |                                   |                      |

 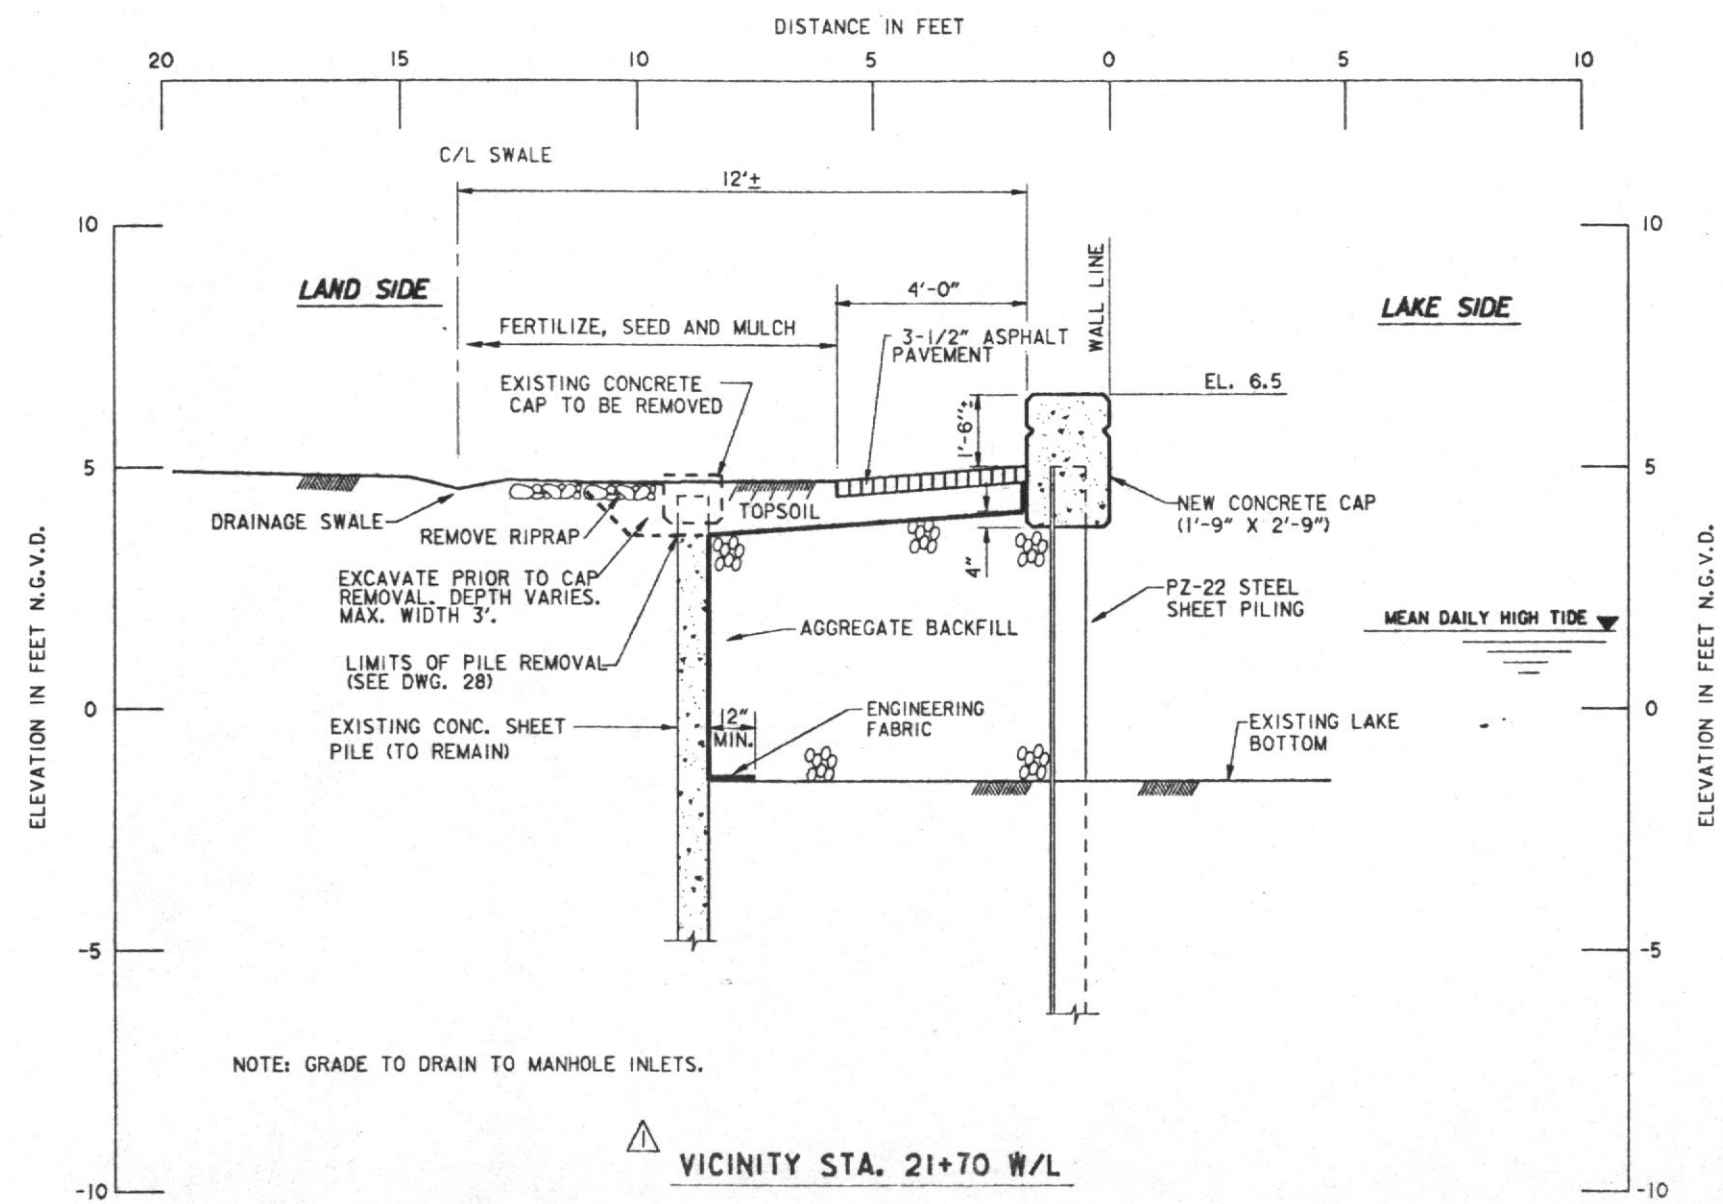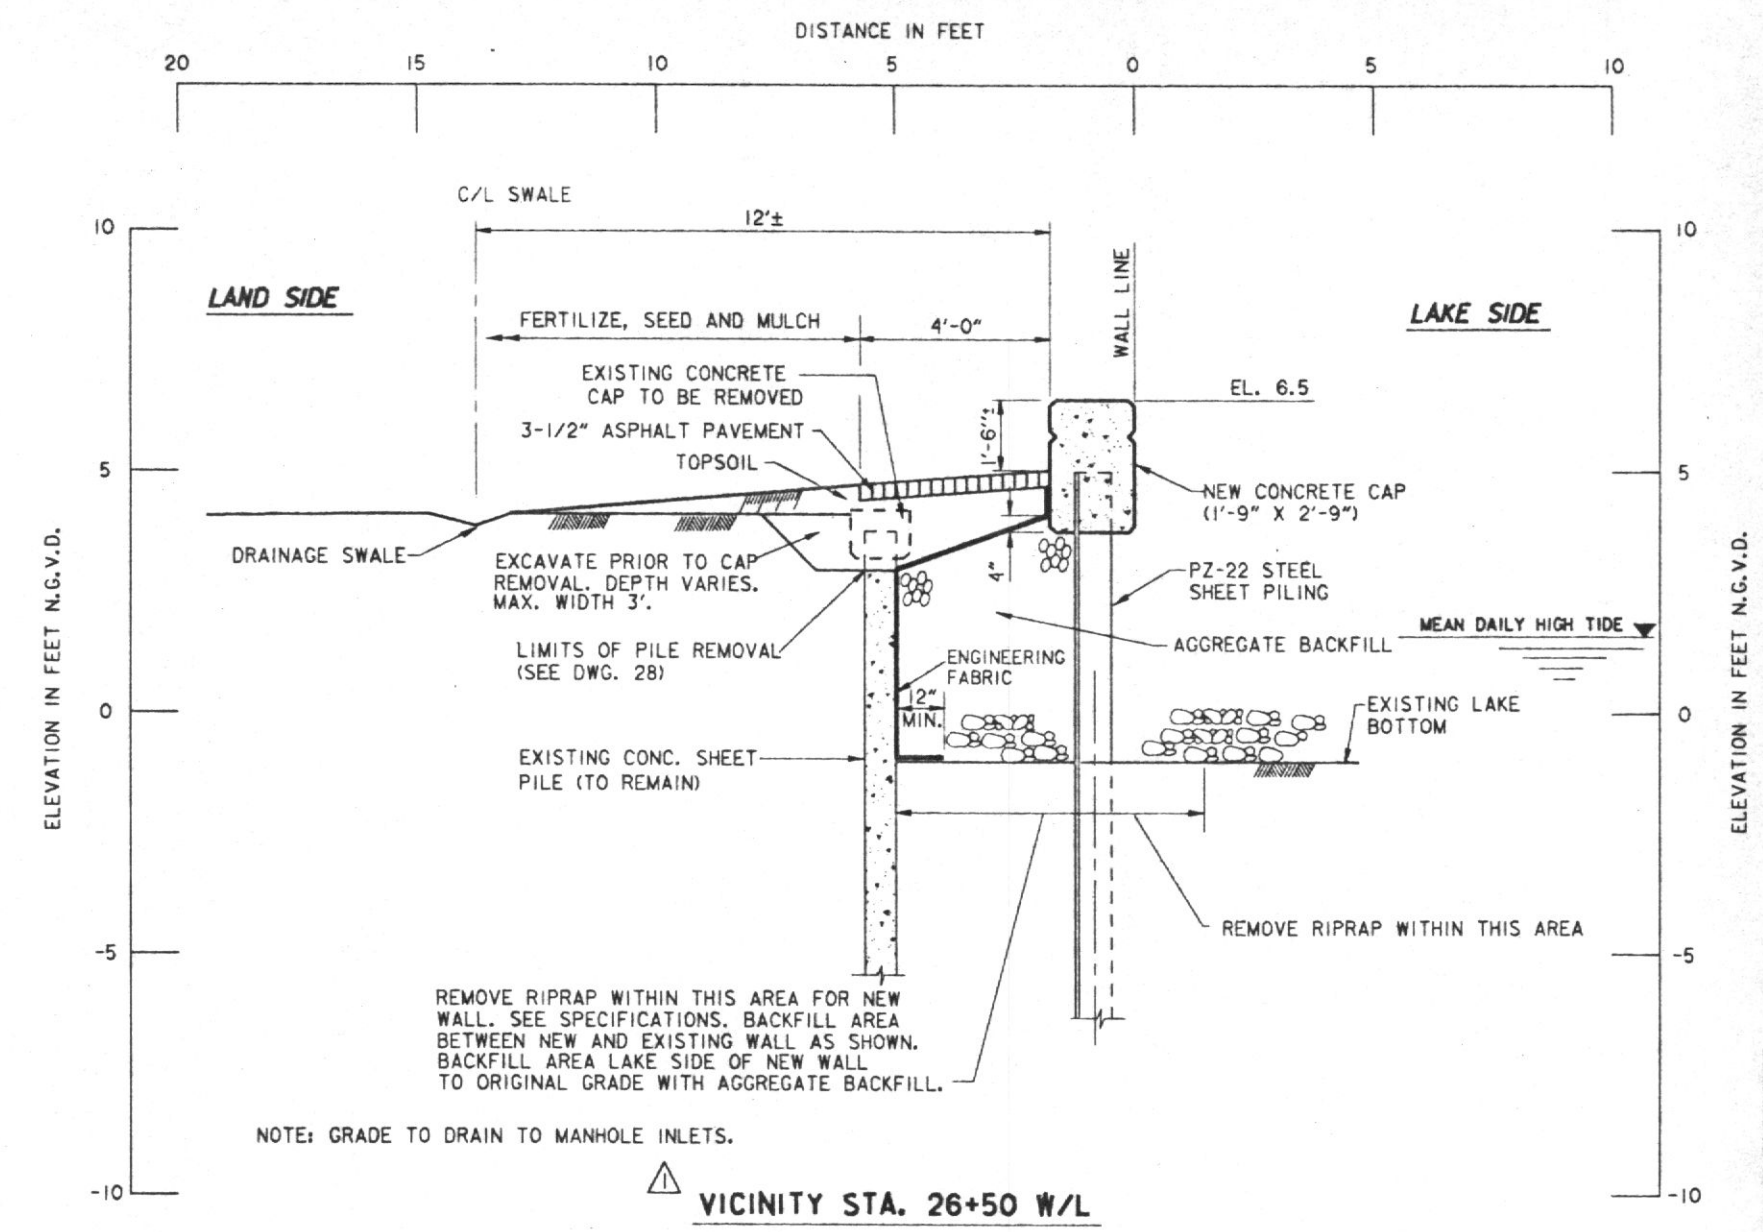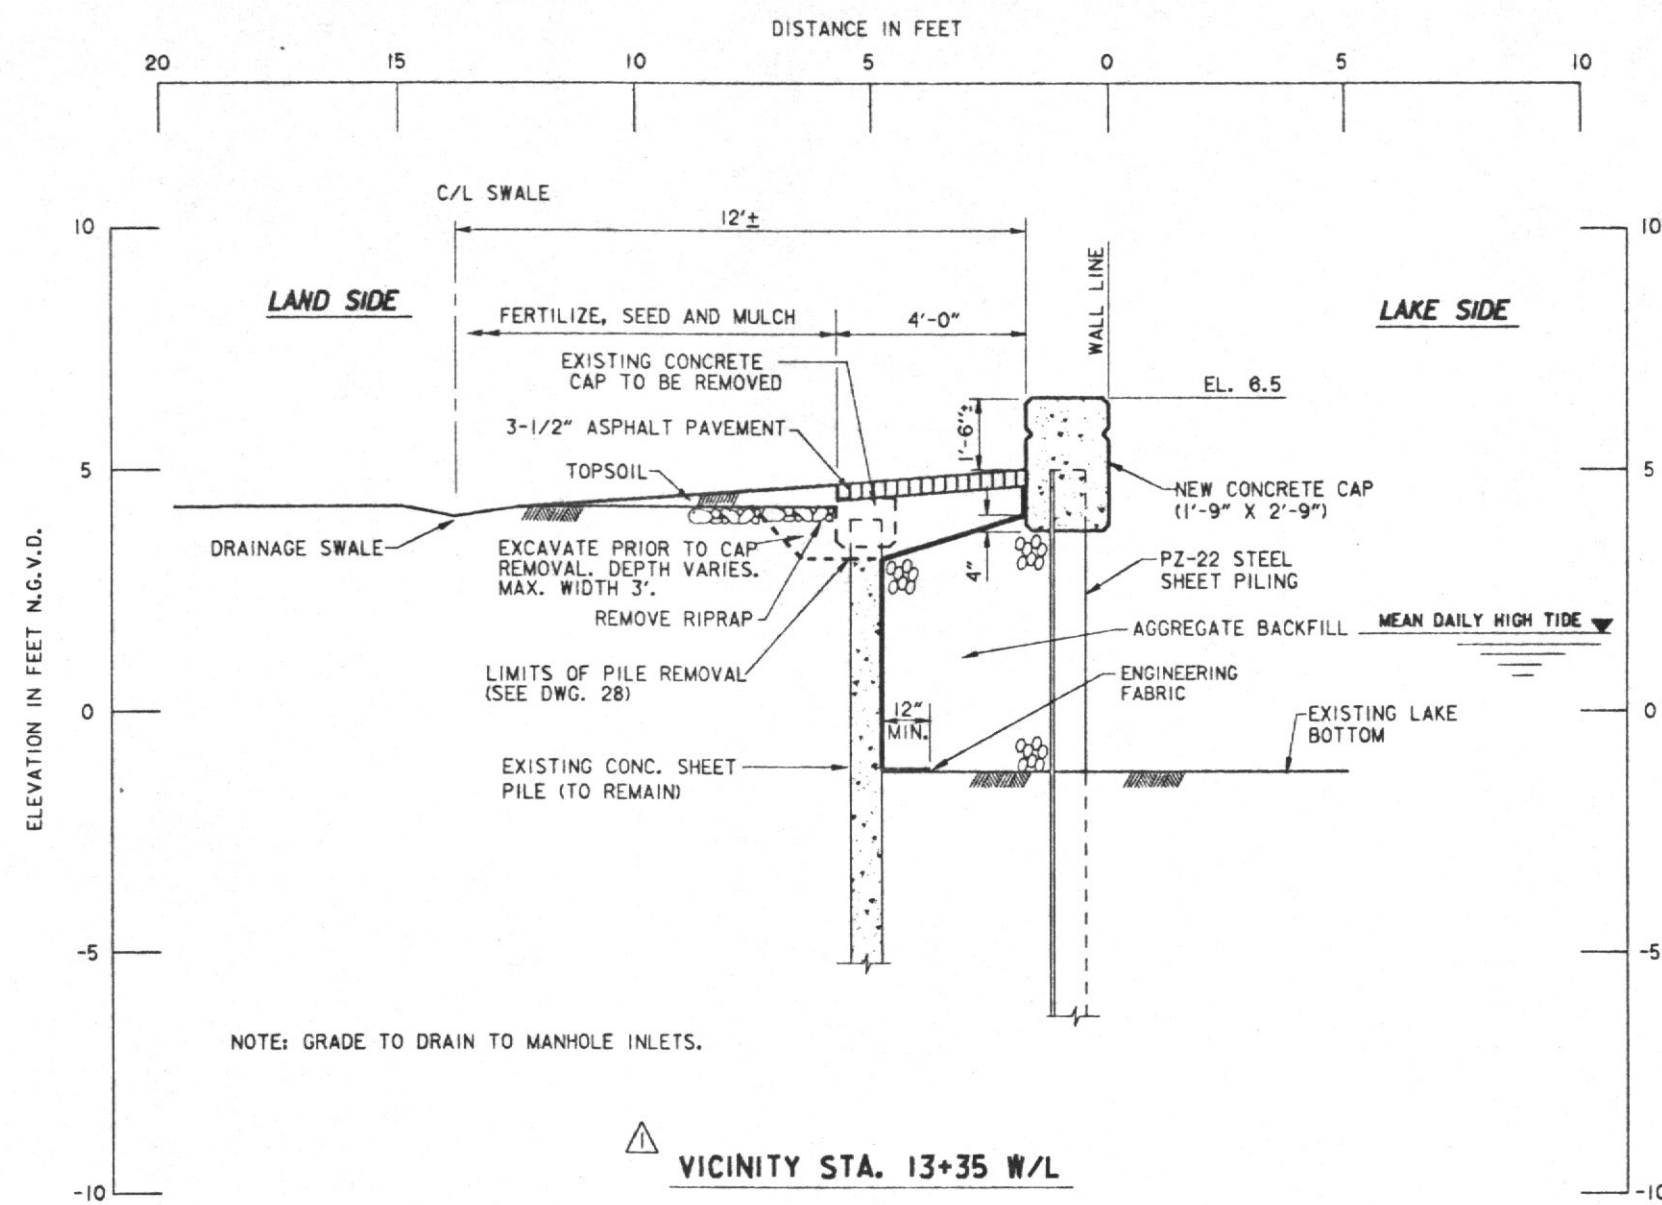Safety is a Part  
of Your Contract





THIS PLAN ACCOMPANIES  
MODIFICATION P0000  
TO CONTRACT NUMBER  
DACW29-94-C-0031

Safety is a Part  
of Your Contract



|                                                                                                  |                                                                          |
|--------------------------------------------------------------------------------------------------|--------------------------------------------------------------------------|
| <b>REVISIONS</b><br>SYMBOL DESCRIPTION DATE APPROVED                                             |                                                                          |
|                                                                                                  | REVISED TOP OF WALL AND SHEET PILING IN SECTIONS; MOD.<br>4-5-94 W.O.B.  |
| <b>U. S. ARMY ENGINEER DISTRICT, NEW ORLEANS</b><br>CORPS OF ENGINEERS<br>NEW ORLEANS, LOUISIANA |                                                                          |
| <b>Brown Cunningham Gannuch</b><br>ENGINEERS • ARCHITECTS • CONSULTANTS                          |                                                                          |
| MANDEVILLE SEAWALL, LA.<br>REPLACEMENT OF MANDEVILLE SEAWALL<br>ST. TAMMANY PARISH, LOUISIANA    |                                                                          |
| <b>TYPICAL SECTIONS</b><br>STA. 13+35 W/L TO STA. 26+50 W/L                                      |                                                                          |
| DESIGNED BY: T.P.H.<br>DRAWN BY: S.F.S.<br>CHECKED BY: R.W.Y.                                    | DATE: NOV. 1993<br>PLOT SCALE: 24<br>PLOT DATE: NOV. 1993                |
| SUBMITTED BY:<br>ROBERT W. YOKUM, P.E.<br>DESIGN ENGINEER                                        | SOLICITATION NO. DACW29-94-B-0024<br>FILE NO. H-4-40335<br>DWG. 18 OF 31 |

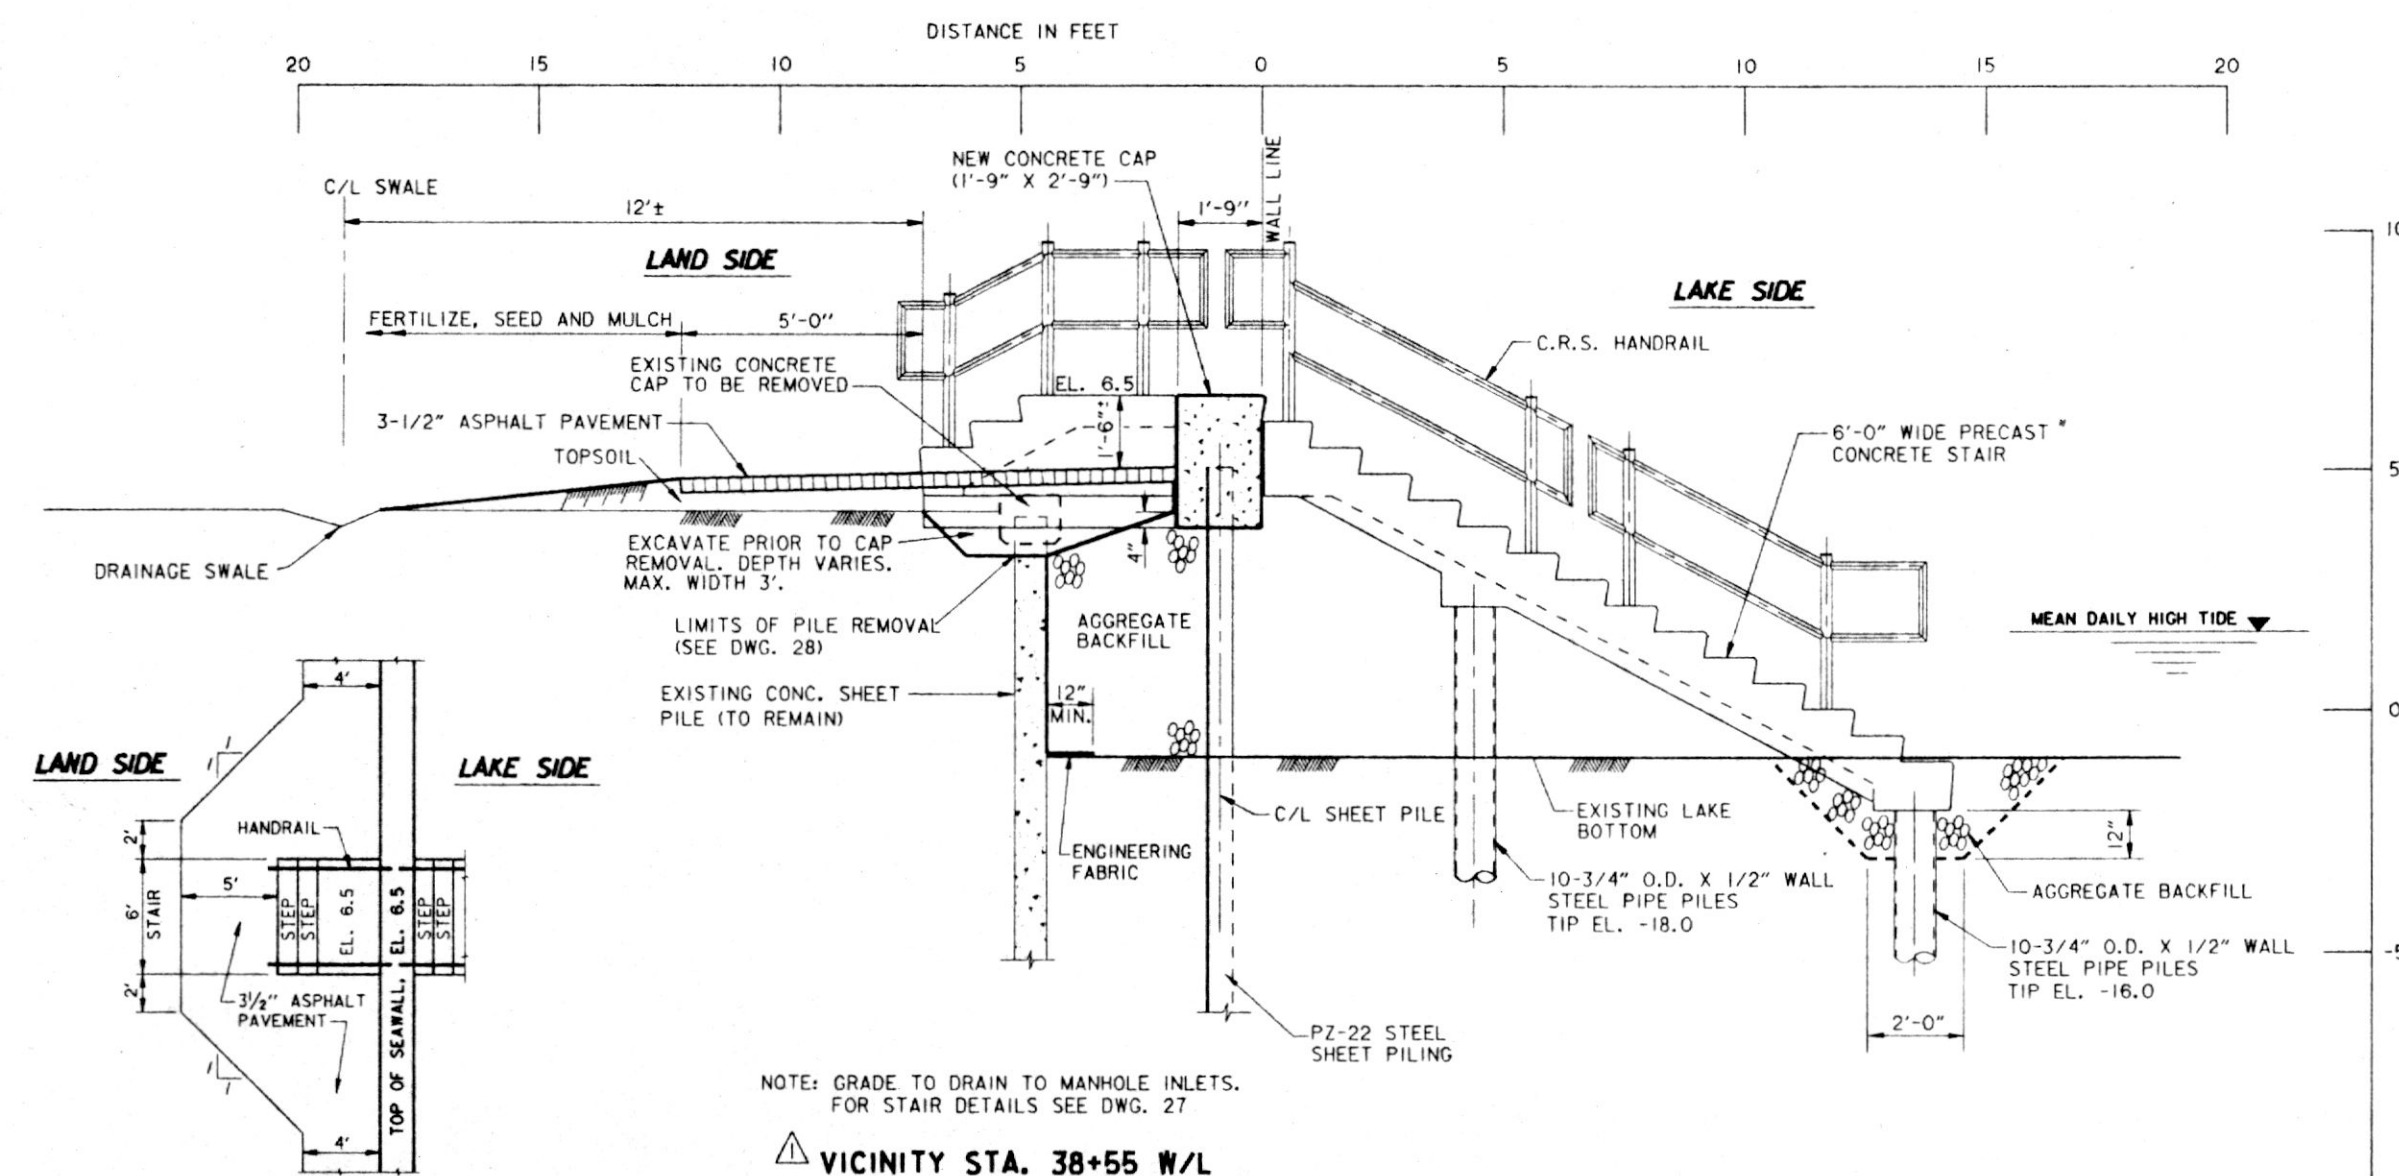
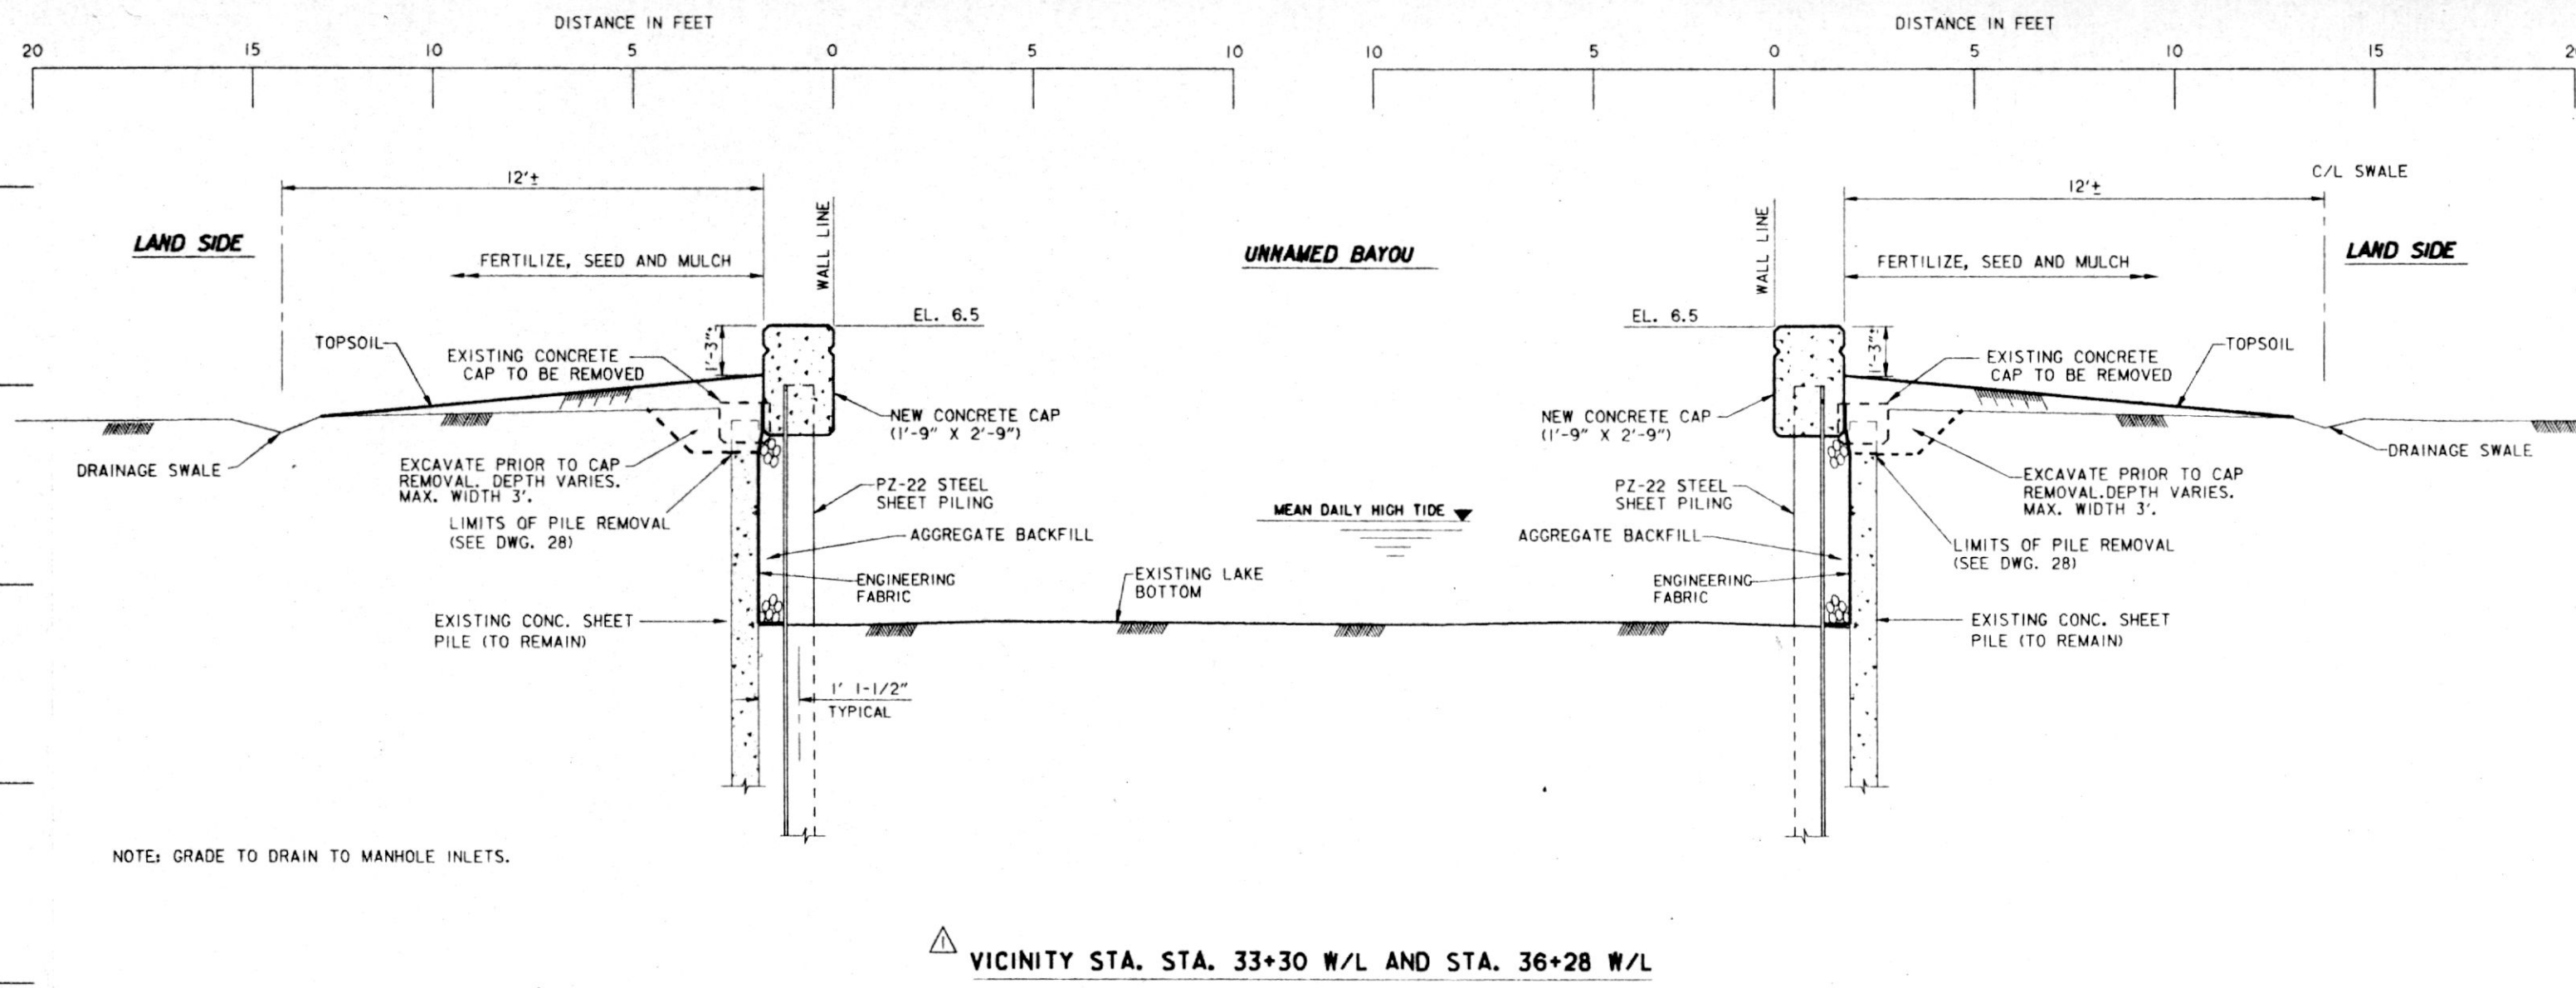


ELEVATION IN FEET N.G.V.D.

ELEVATION IN FEET N.G.V.D.

ELEVATION IN FEET N.G.V.D.


ELEVATION IN FEET N.G.V.D.



PART PLAN SHOWING ASPHALT PAVEMENT CONFIGURATION AT STAIRS  
SCALE: 1" = 5'

**Safety is a Part of Your Contract**

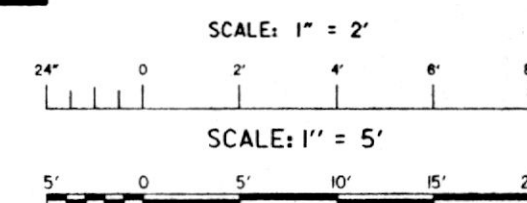THIS PLAN ACCOMPANIES  
MODIFICATION P0000  
TO CONTRACT NUMBER  
DACW29-94-C-0031






| SYMBOL | DESCRIPTION                                                              | DATE   | APPROVED |
|--------|--------------------------------------------------------------------------|--------|----------|
| △      | REVISED TOP OF WALL AND SHEET PILING IN SECTIONS AND STAIR DETAILS; MOD. | 4-5-94 | W.O.B.   |

|                                                                                               |                                   |                    |                      |
|-----------------------------------------------------------------------------------------------|-----------------------------------|--------------------|----------------------|
| U. S. ARMY ENGINEER DISTRICT, NEW ORLEANS<br>CORPS OF ENGINEERS<br>NEW ORLEANS, LOUISIANA     |                                   |                    |                      |
| Brown Cunningham Gannuch<br>ENGINEERS • ARCHITECTS • CONSULTANTS                              |                                   |                    |                      |
| MANDEVILLE SEAWALL, LA.<br>REPLACEMENT OF MANDEVILLE SEAWALL<br>ST. TAMMANY PARISH, LOUISIANA |                                   |                    |                      |
| TYPICAL SECTIONS<br>STA. 33+30 W/L TO STA. 38+55 W/L                                          |                                   |                    |                      |
| DESIGNED BY: T.P.H.                                                                           | DATE: NOV. 1993                   | PLOT SCALE: 24     | PLOT DATE: NOV. 1993 |
| DRAWN BY: S.F.S.                                                                              | CADD FILE: 40335-19.DGN           | FILE NO. H-4-40335 |                      |
| CHECKED BY: R.W.Y.                                                                            | SOLICITATION NO. DACW29-94-B-0024 | DWG. 19 OF 31      |                      |
| SUBMITTED BY: ROBERT W. YOKUM, P.E. DESIGN ENGINEER                                           |                                   |                    |                      |



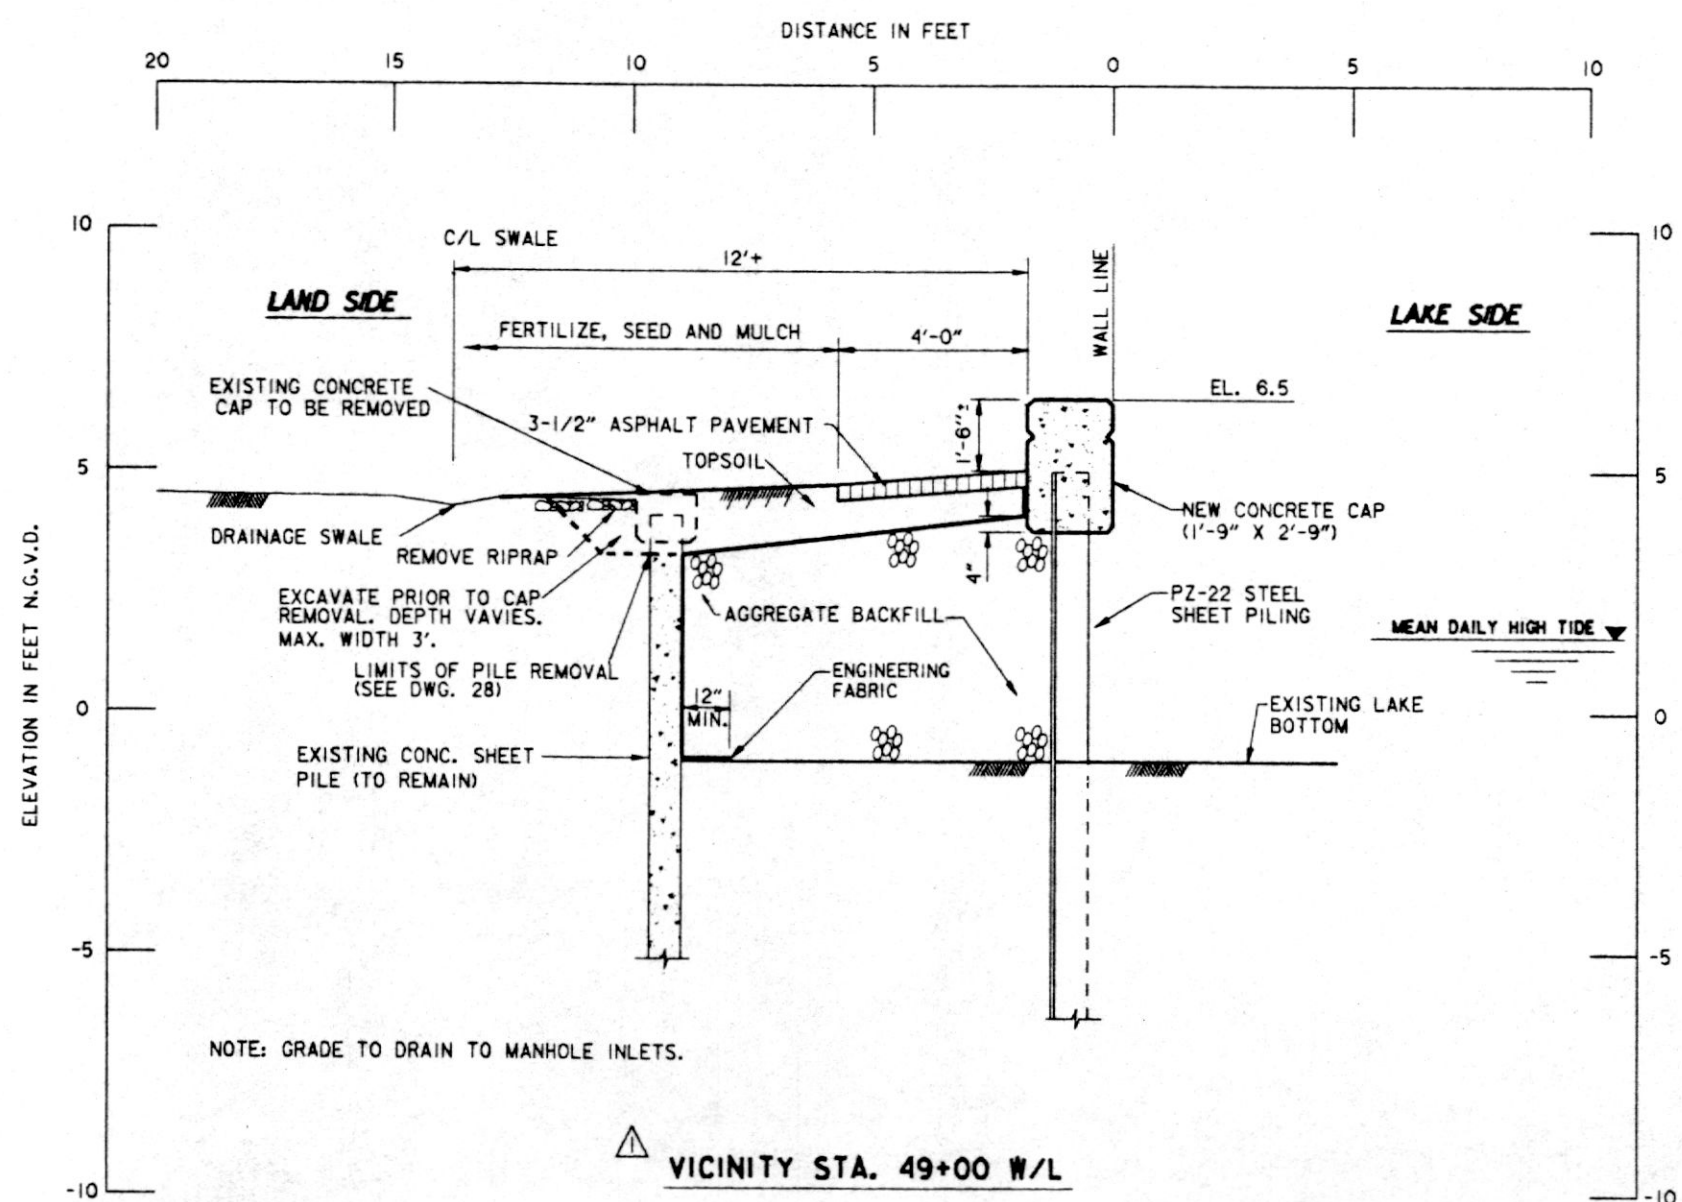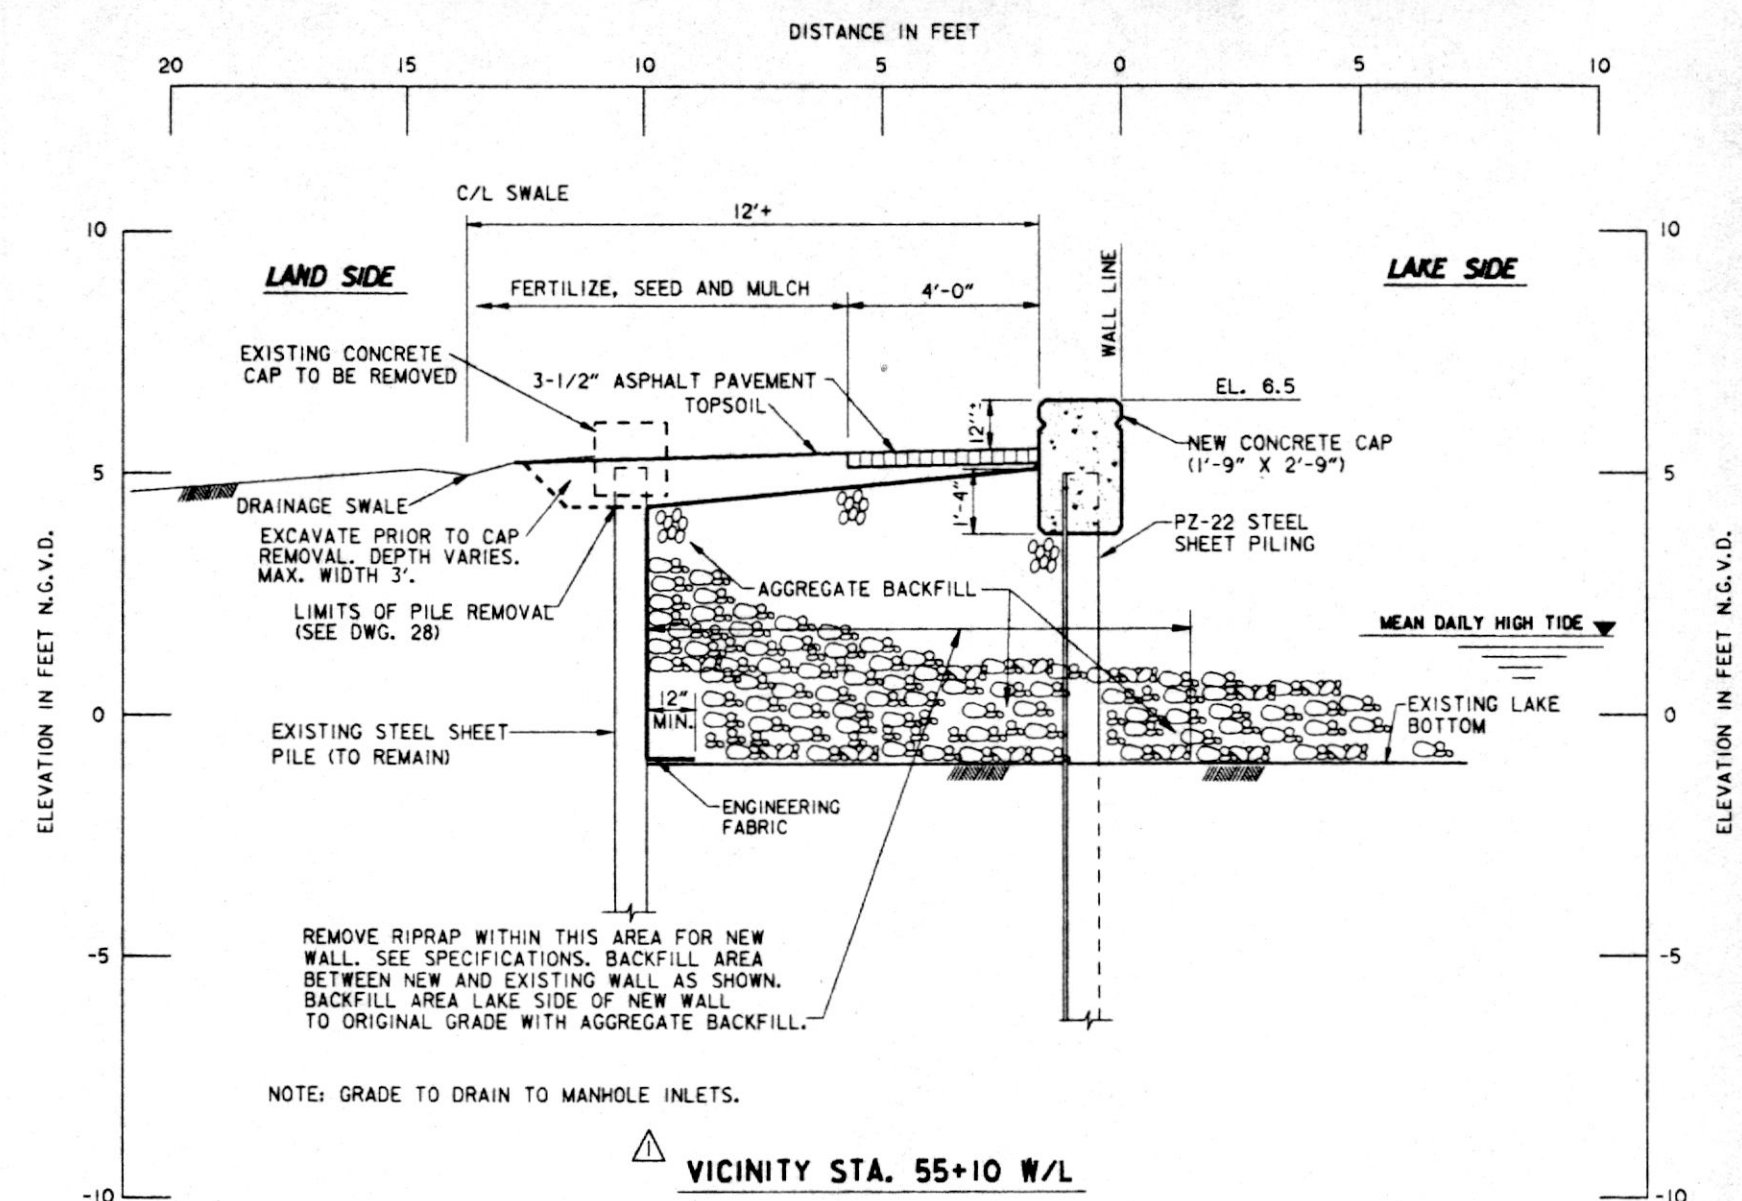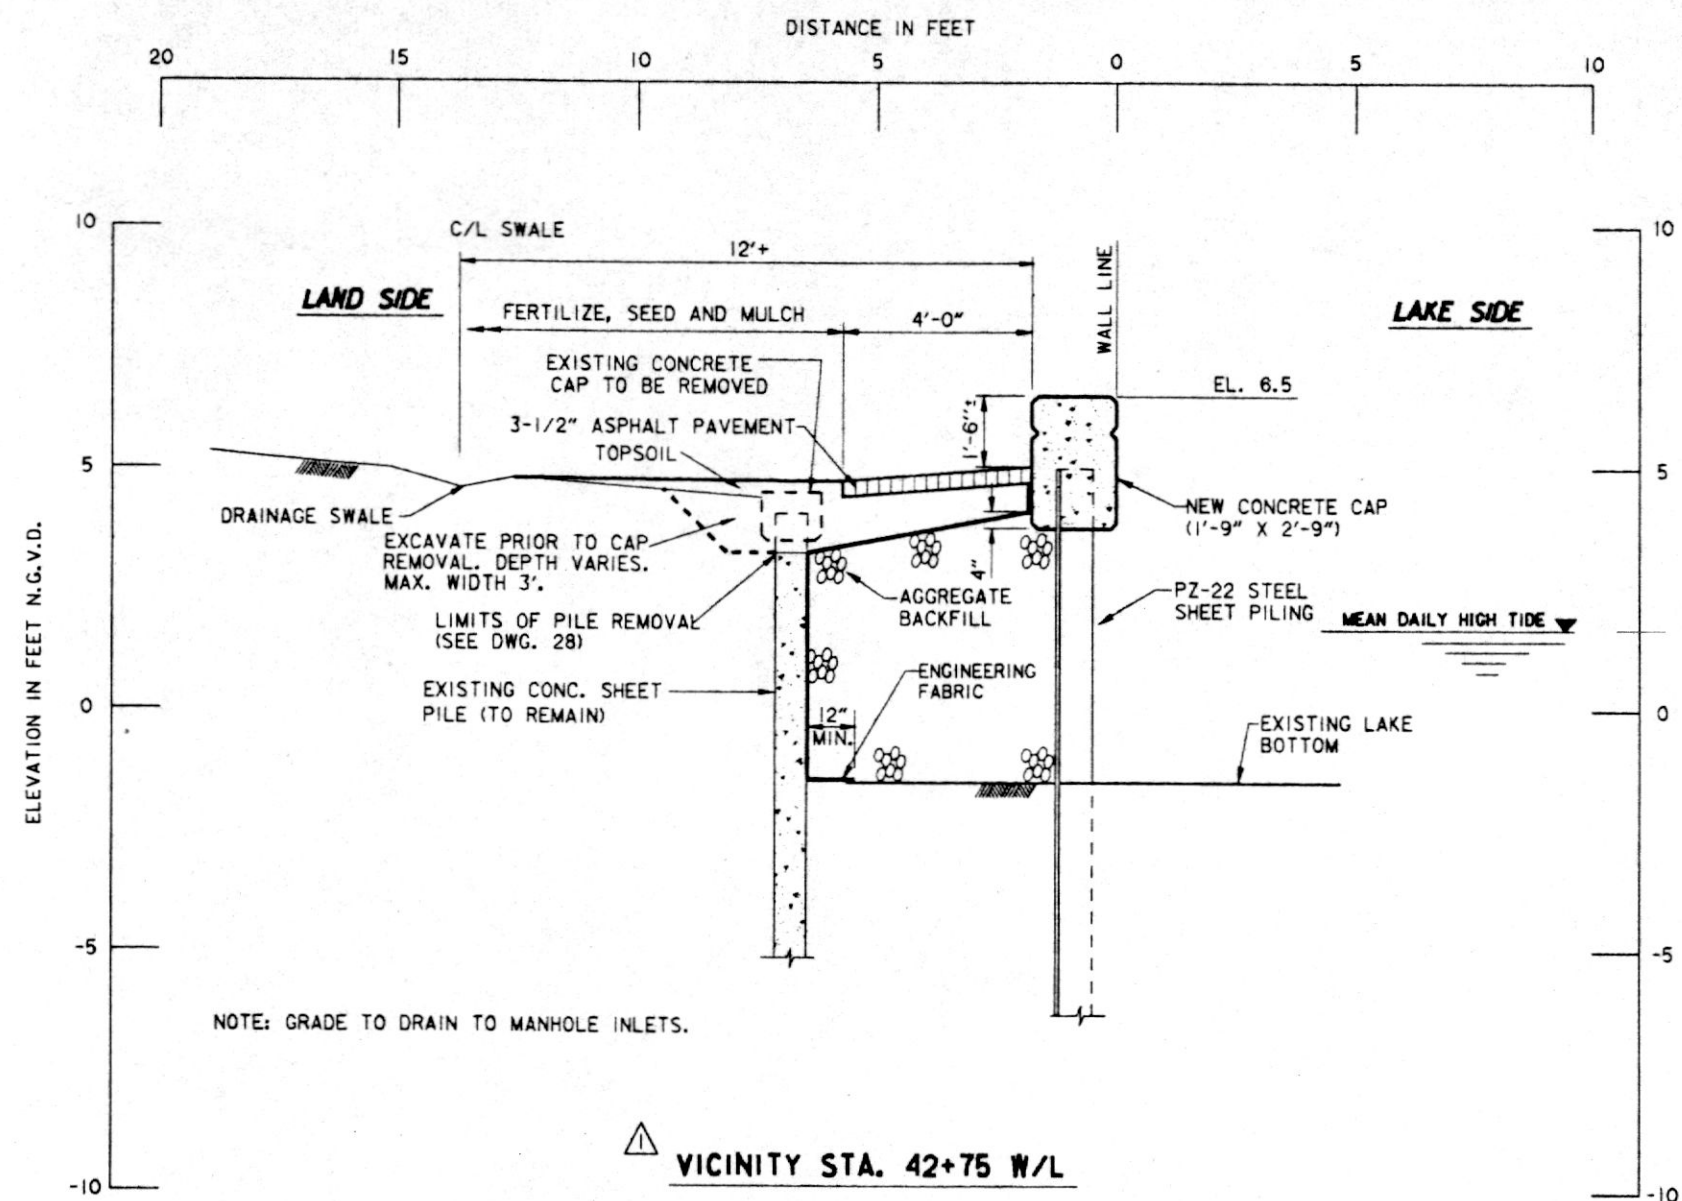

NOTE:  
TRANSITION TOP OF ASPHALT PAVEMENT FROM EL. 5.0 TO  
EL. 5.5 BETWEEN STA. 50+00 W/L AND STA. 51+00 W/L.

THIS PLAN ACCOMPANIES  
MODIFICATION P0000  
TO CONTRACT NUMBER  
DACW29-94-C-0031

SCALE: 1" = 2'




24" 0 2' 4' 6' 8'

Safety is a Part  
of Your Contract



|                                                                                               |                                                                             |                                   |                      |
|-----------------------------------------------------------------------------------------------|-----------------------------------------------------------------------------|-----------------------------------|----------------------|
| REVISOR                                                                                       | REVISED TOP OF WALL AND SHEET PILING AND<br>BOTTOM OF WALL IN SECTIONS MOD. | 4-5-94                            | W.O.B.               |
| SYMBOL                                                                                        | DESCRIPTION                                                                 | DATE                              | APPROVED             |
| REVISIONS                                                                                     |                                                                             |                                   |                      |
| U. S. ARMY ENGINEER DISTRICT, NEW ORLEANS<br>CORPS OF ENGINEERS<br>NEW ORLEANS, LOUISIANA     |                                                                             |                                   |                      |
| Brown Cunningham Gannuch<br>ENGINEERS - ARCHITECTS - CONSULTANTS                              |                                                                             |                                   |                      |
| MANDEVILLE SEAWALL, LA.<br>REPLACEMENT OF MANDEVILLE SEAWALL<br>ST. TAMMANY PARISH, LOUISIANA |                                                                             |                                   |                      |
| TYPICAL SECTIONS<br>STA. 42+75 W/L TO STA. 55+10 W/L                                          |                                                                             |                                   |                      |
| DESIGNED BY: T.P.H.                                                                           | DATE: NOV. 1993                                                             | PLOT SCALE: 24                    | PLOT DATE: NOV. 1993 |
| DRAWN BY: S.F.S.                                                                              | CADD FILE: 40335-20.000                                                     | FILE NO: H-4-40335                |                      |
| CHECKED BY: R.W.Y.                                                                            | SUBMITTED BY: ROBERT W. YOKUM, P.E.<br>DESIGN ENGINEER                      | SOLICITATION NO: DACW29-94-B-0024 | DWG. 20 OF 31        |



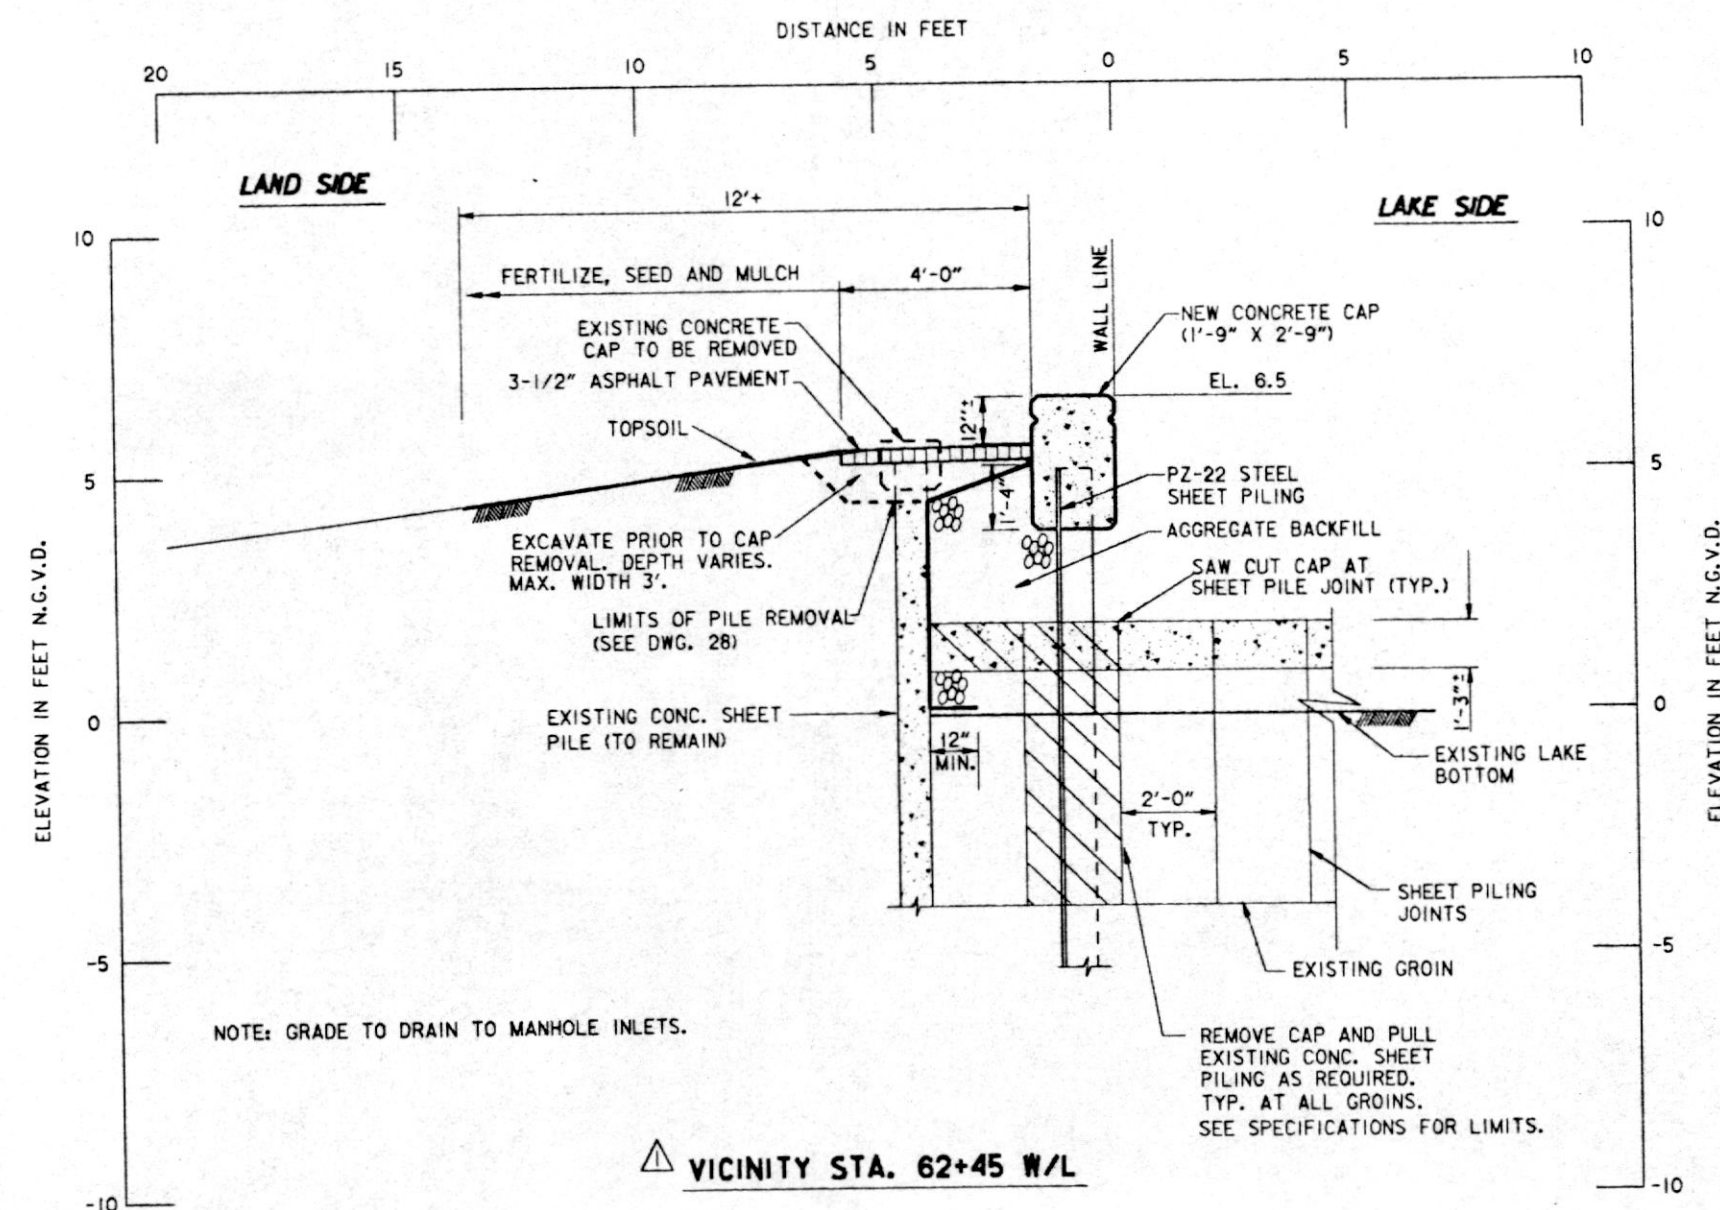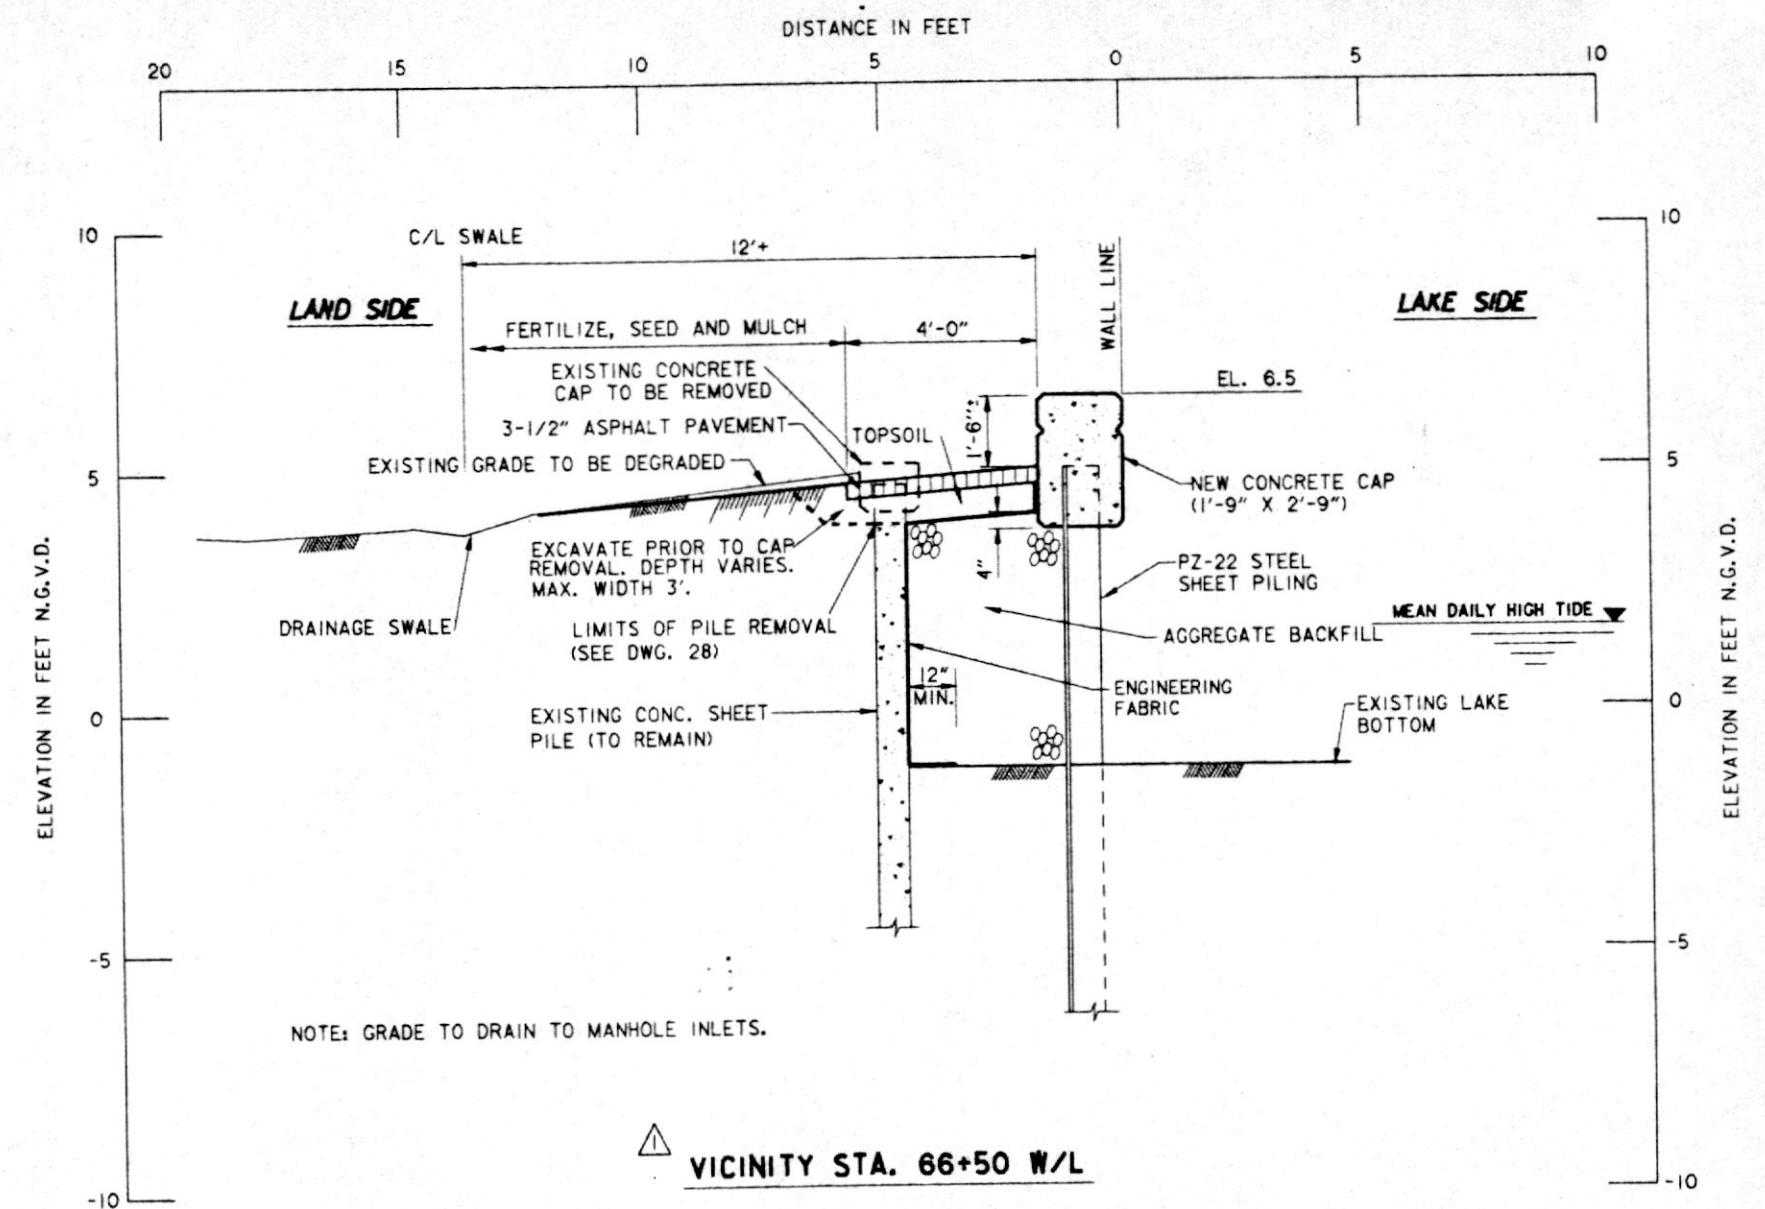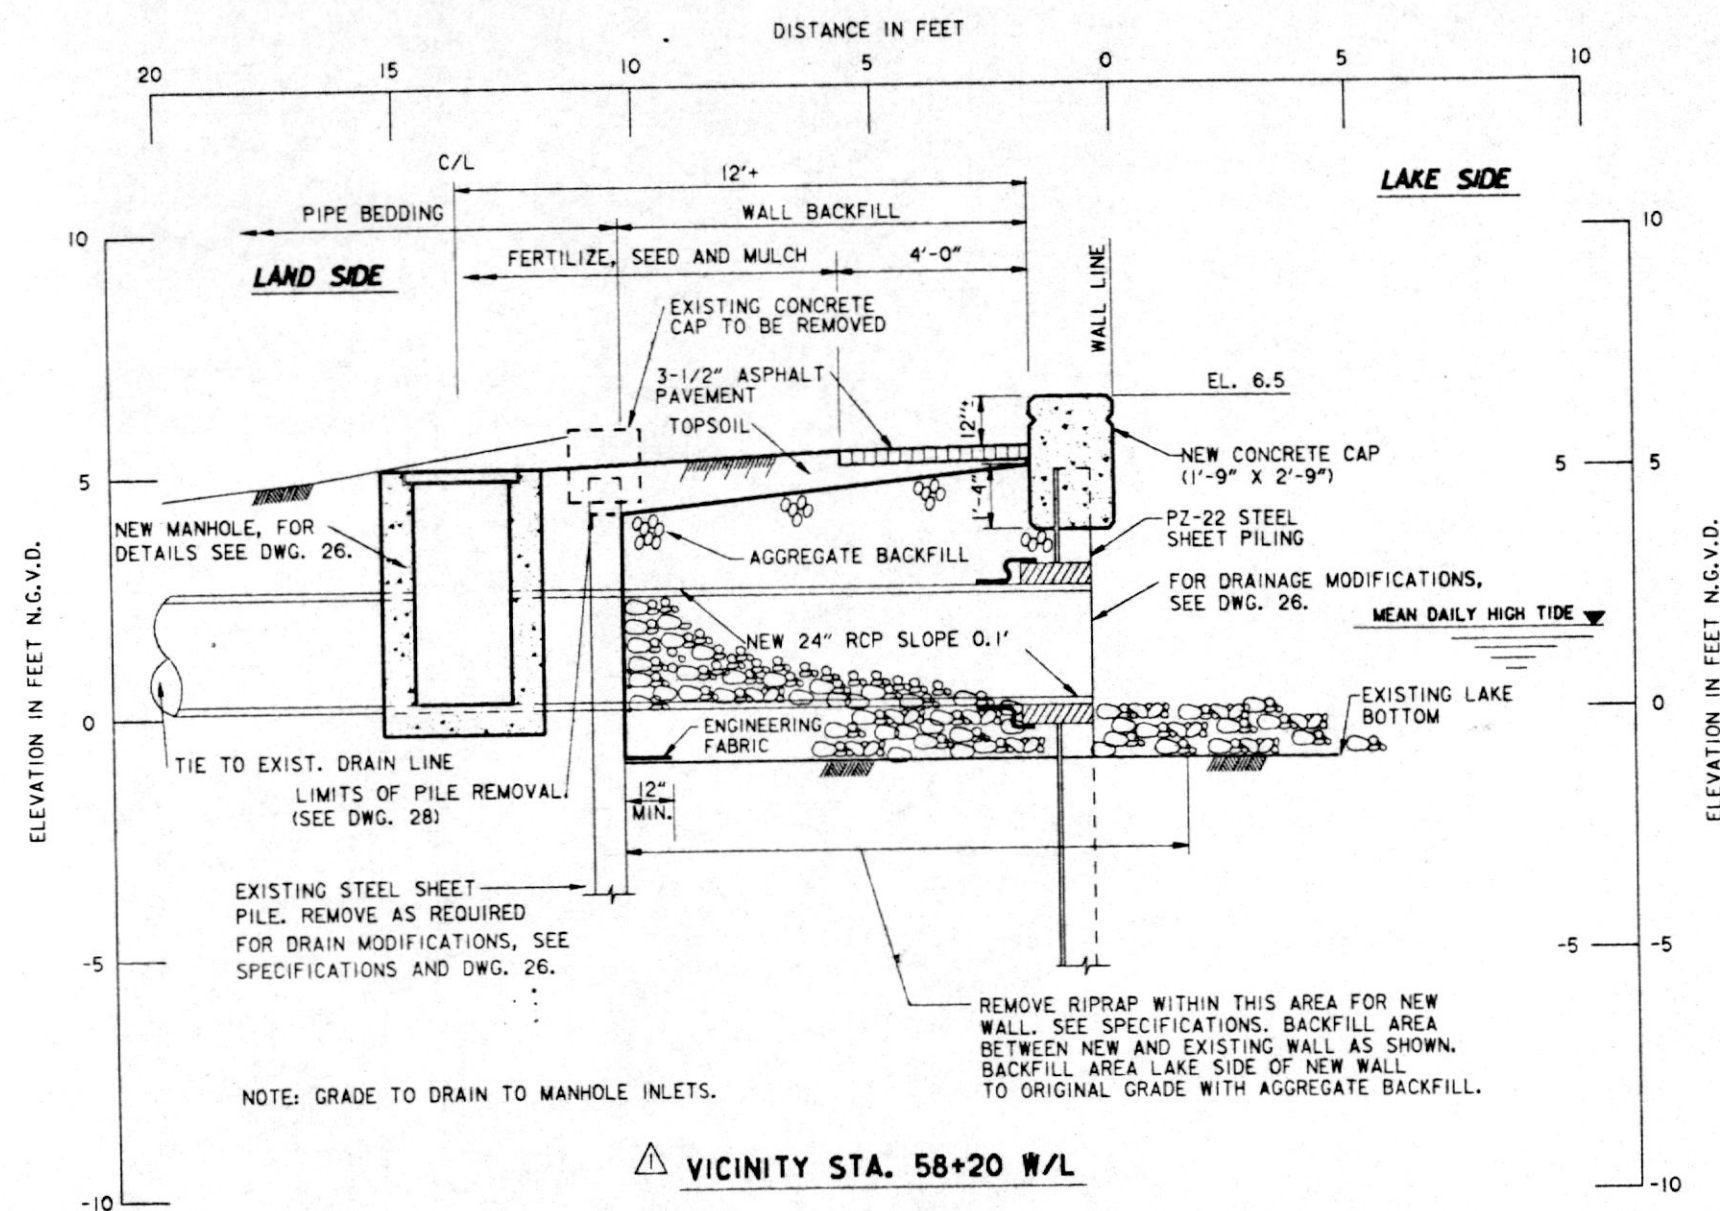

NOTE:  
TRANSITION TOP OF ASPHALT PAVEMENT FROM EL. 5.5 TO  
EL. 5.0 BETWEEN STA. 65+00 W/L AND STA. 66+00 W/L.

THIS PLAN ACCOMPANIES  
MODIFICATION P0000  
TO CONTRACT NUMBER  
DACW29-94-C-0031




SCALE: 1" = 2'

Safety is a Part  
of Your Contract



| REVISIONS                           |                                                                           | DATE                              | APPROVED |
|-------------------------------------|---------------------------------------------------------------------------|-----------------------------------|----------|
| 1                                   | REVISED TOP OF WALL AND SHEET PILING AND BOTTOM OF WALL IN SECTIONS, MOD. | 4-5-94                            | W.O.B.   |
| DESIGNED BY: T.P.H.                 |                                                                           |                                   |          |
| DRAWN BY: S.F.S.                    |                                                                           |                                   |          |
| CHECKED BY: R.W.Y.                  |                                                                           |                                   |          |
| SUBMITTED BY: ROBERT W. YOKUM, P.E. |                                                                           |                                   |          |
| DESIGN ENGINEER                     |                                                                           |                                   |          |
| DATE: NOV. 1993                     |                                                                           | PLOT DATE: NOV. 1993              |          |
| PLOT SCALE: 24                      |                                                                           | FILE NO. H-4-40335                |          |
| CADD FILE: 40335-21.DGN             |                                                                           | SOLICITATION NO. DACW29-94-B-0024 |          |
| DWG. 21                             |                                                                           | OF 31                             |          |



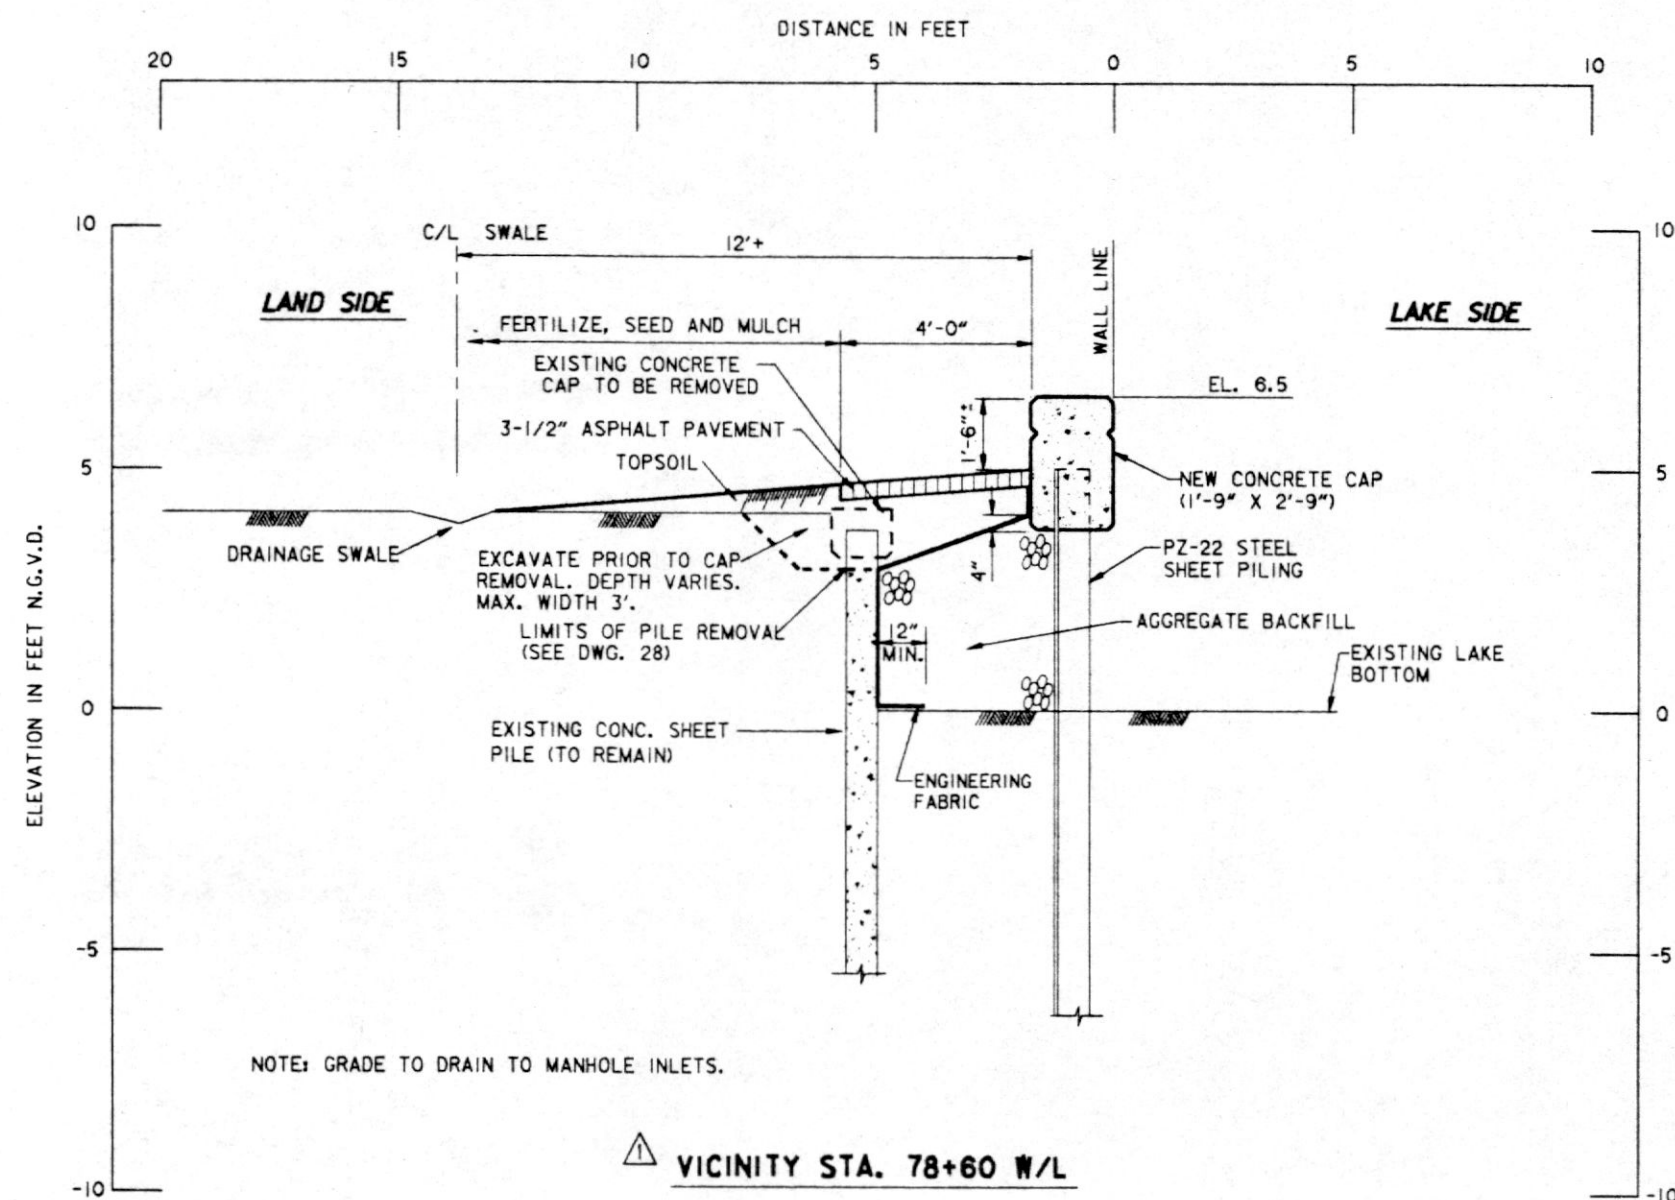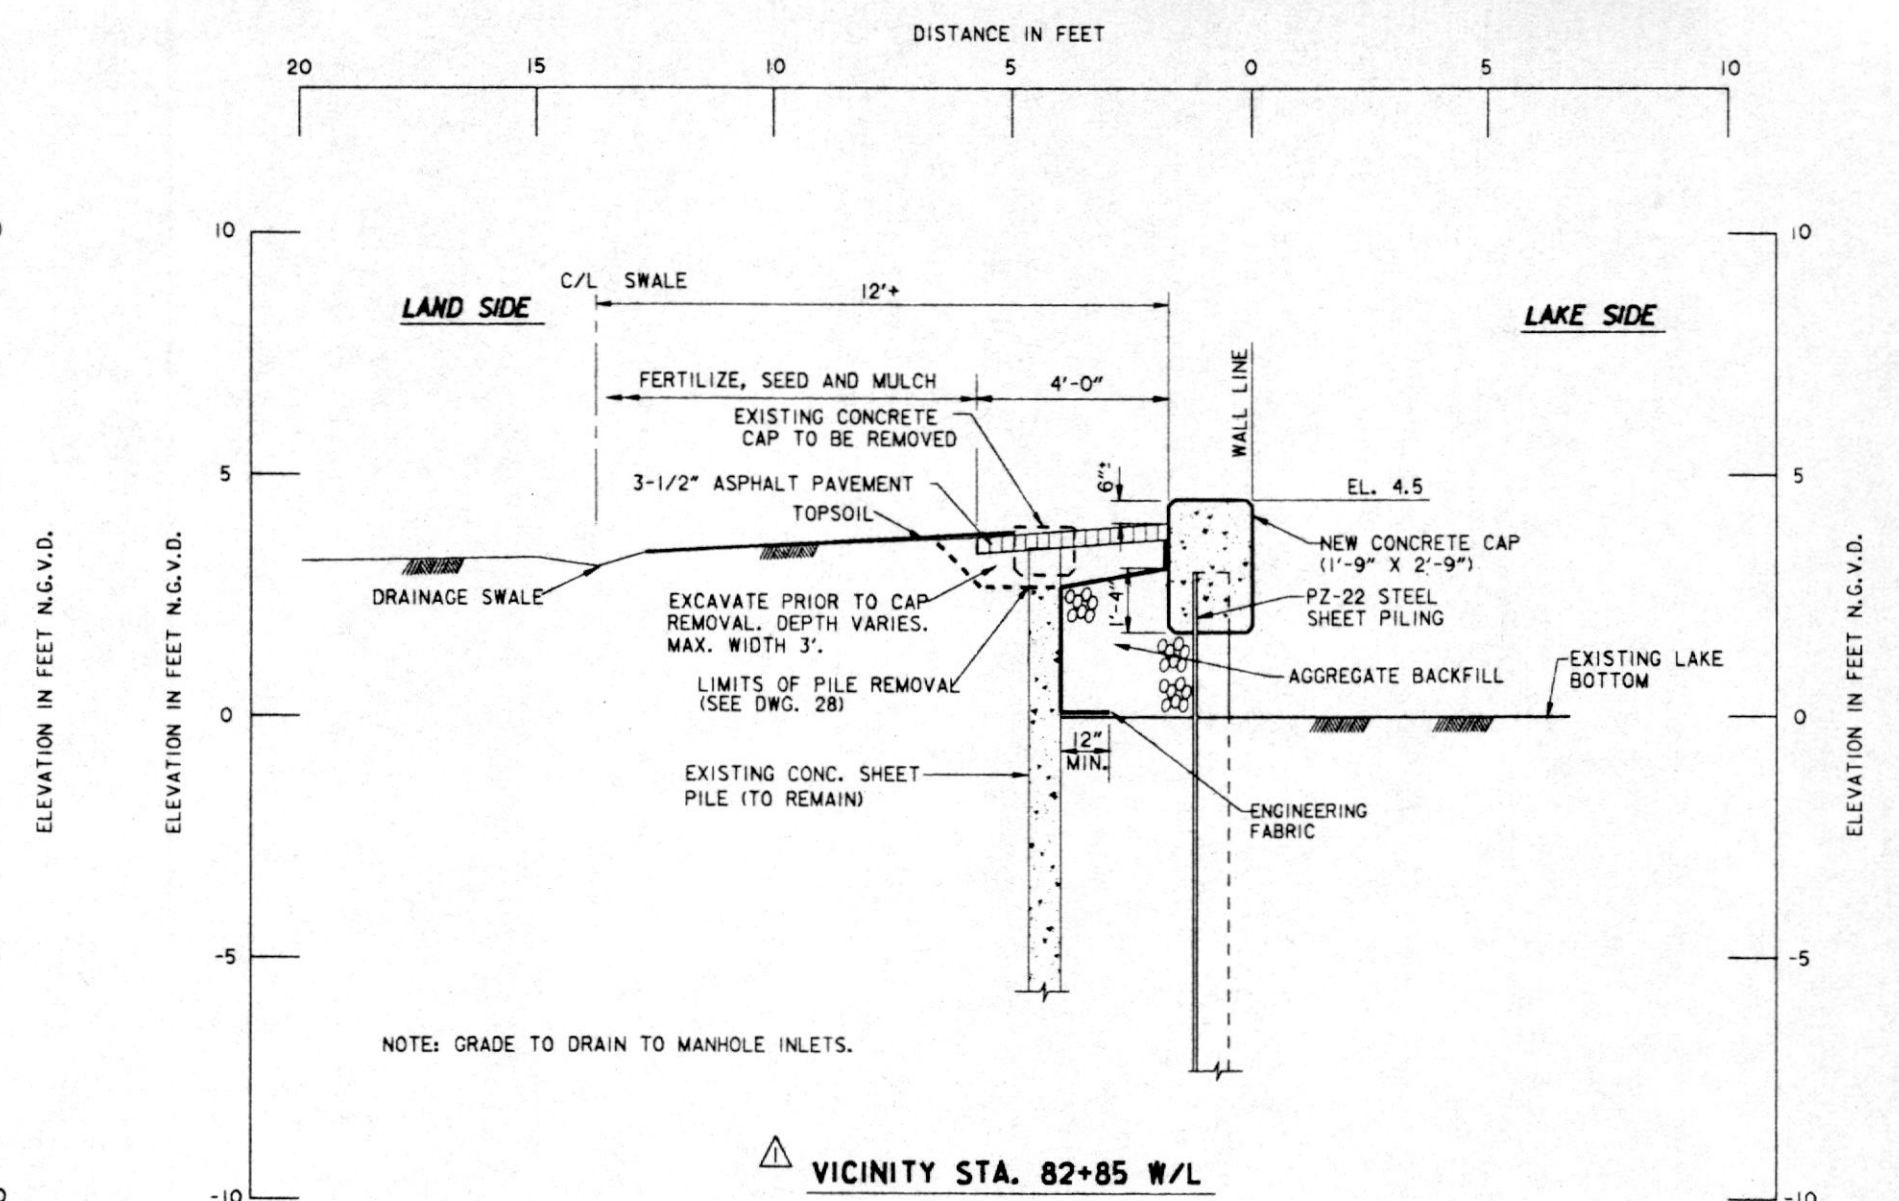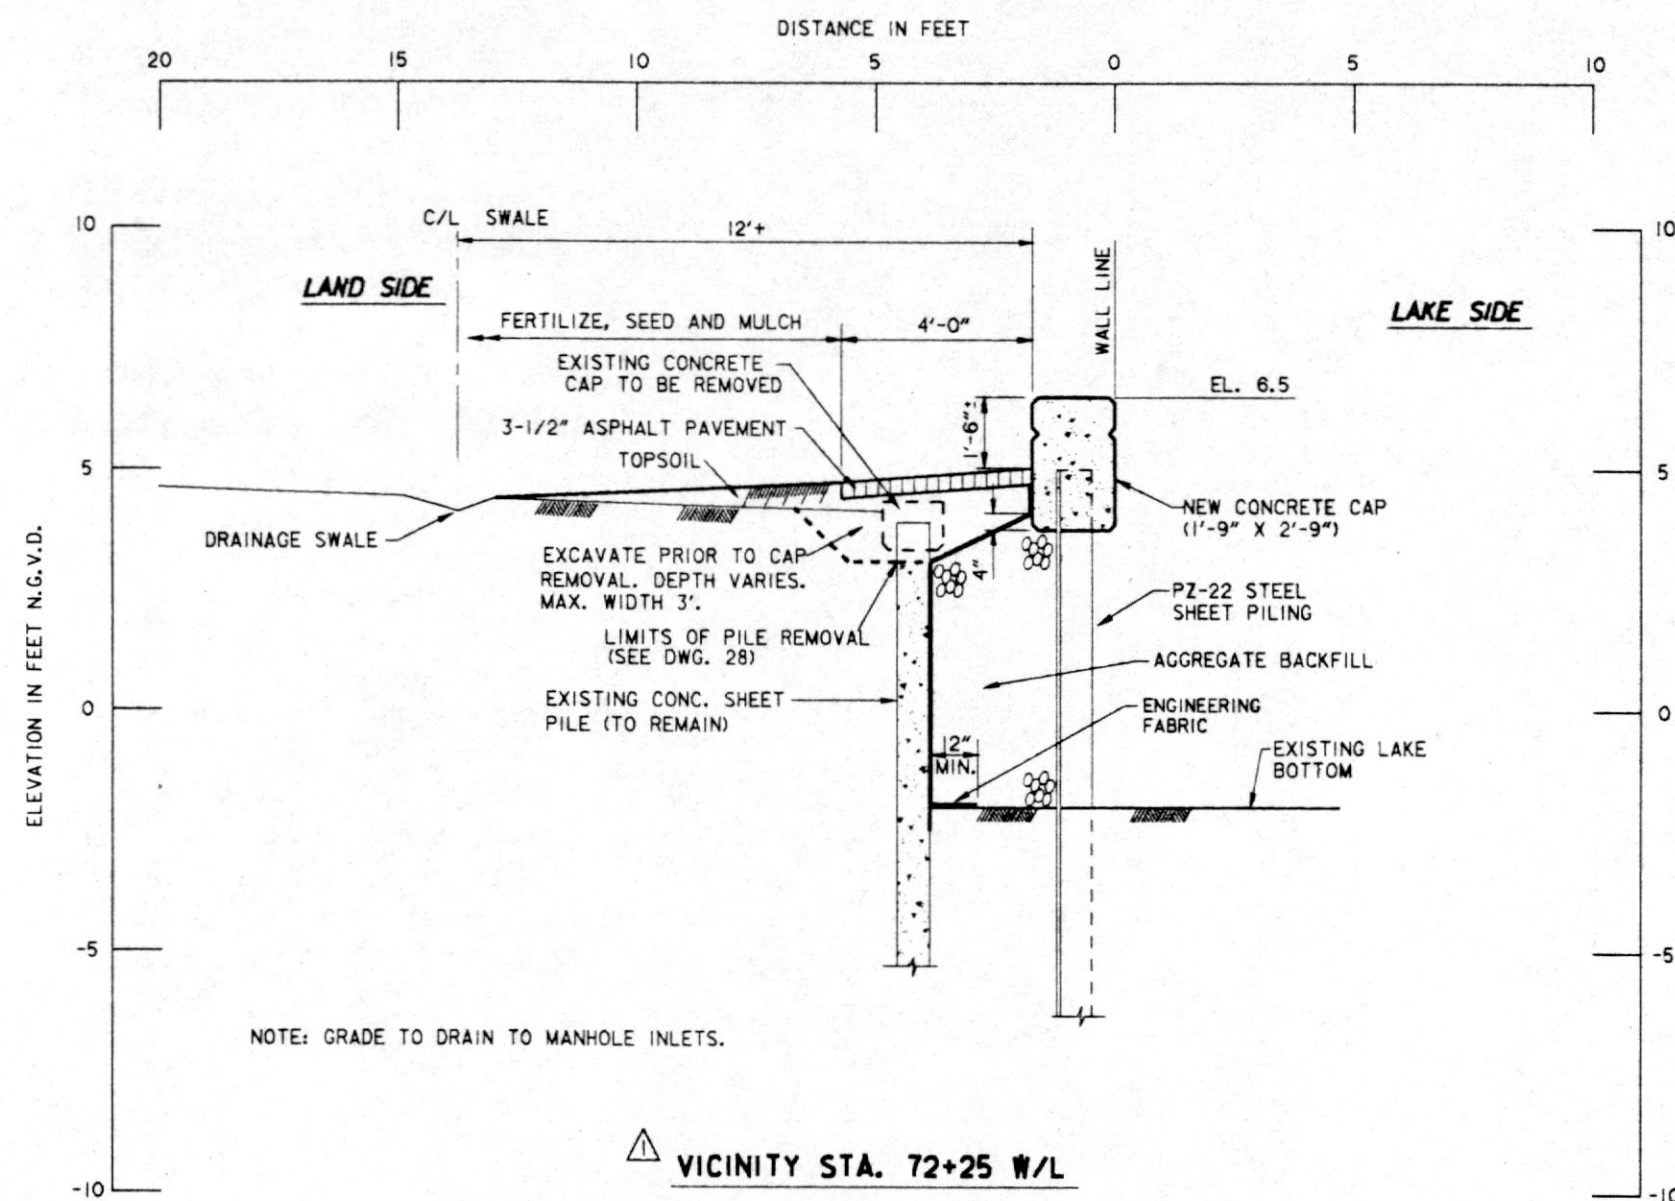

THIS PLAN ACCOMPANIES  
MODIFICATION 0000  
TO CONTRACT NUMBER  
DACW29-94-C-0031

SCALE: 1" = 2'

Safety is a Part  
of Your Contract


| SYMBOL                                                                                        | DESCRIPTION                                           | DATE               | APPROVED             |
|-----------------------------------------------------------------------------------------------|-------------------------------------------------------|--------------------|----------------------|
| △                                                                                             | REVISED TOP OF WALL AND SHEET PILING IN SECTIONS MOD. | 4-5-94             | W.O.B.               |
| REVISIONS                                                                                     |                                                       |                    |                      |
| U. S. ARMY ENGINEER DISTRICT, NEW ORLEANS<br>CORPS OF ENGINEERS<br>NEW ORLEANS, LOUISIANA     |                                                       |                    |                      |
| BCG Brown Cunningham Gannuch<br>ENGINEERS • ARCHITECTS • CONSULTANTS                          |                                                       |                    |                      |
| MANDEVILLE SEAWALL, LA.<br>REPLACEMENT OF MANDEVILLE SEAWALL<br>ST. TAMMANY PARISH, LOUISIANA |                                                       |                    |                      |
| TYPICAL SECTIONS<br>STA. 72+25 W/L TO STA. 82+85 W/L                                          |                                                       |                    |                      |
| DESIGNED BY: T.P.H.                                                                           | DATE: NOV. 1993                                       | PLOT SCALE: 24     | PLOT DATE: NOV. 1993 |
| DRAWN BY: S.F.S.                                                                              | CADD FILE: 40339-22.DGN                               | FILE NO: H-4-40335 |                      |
| CHECKED BY: R.W.Y.                                                                            | SOLICITATION NO. DACW29-94-B-0024                     | DWG. 22 OF 31      |                      |
| SUBMITTED BY: ROBERT W. YOKUM, P.E.<br>DESIGN ENGINEER                                        |                                                       |                    |                      |




Safety is a Part  
of Your Contract

LAKE SIDE

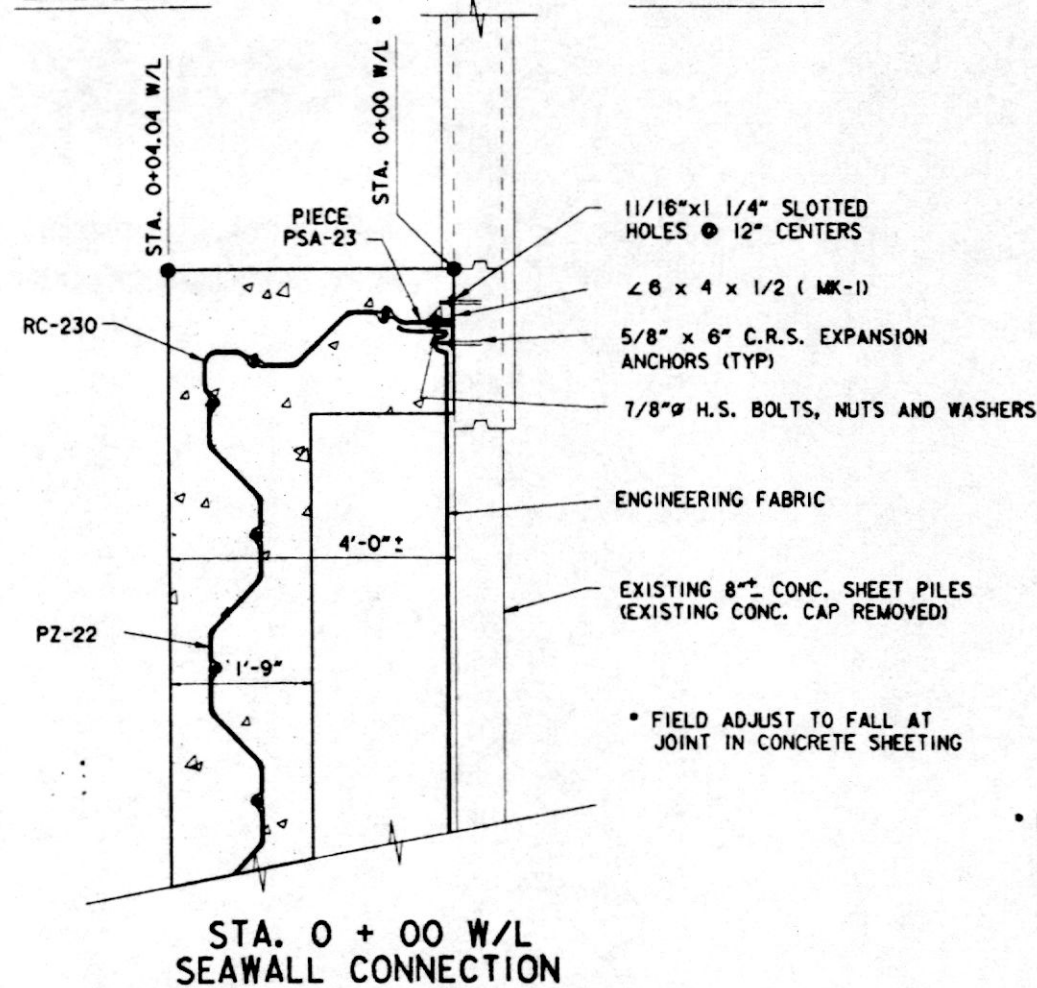LAND SIDE




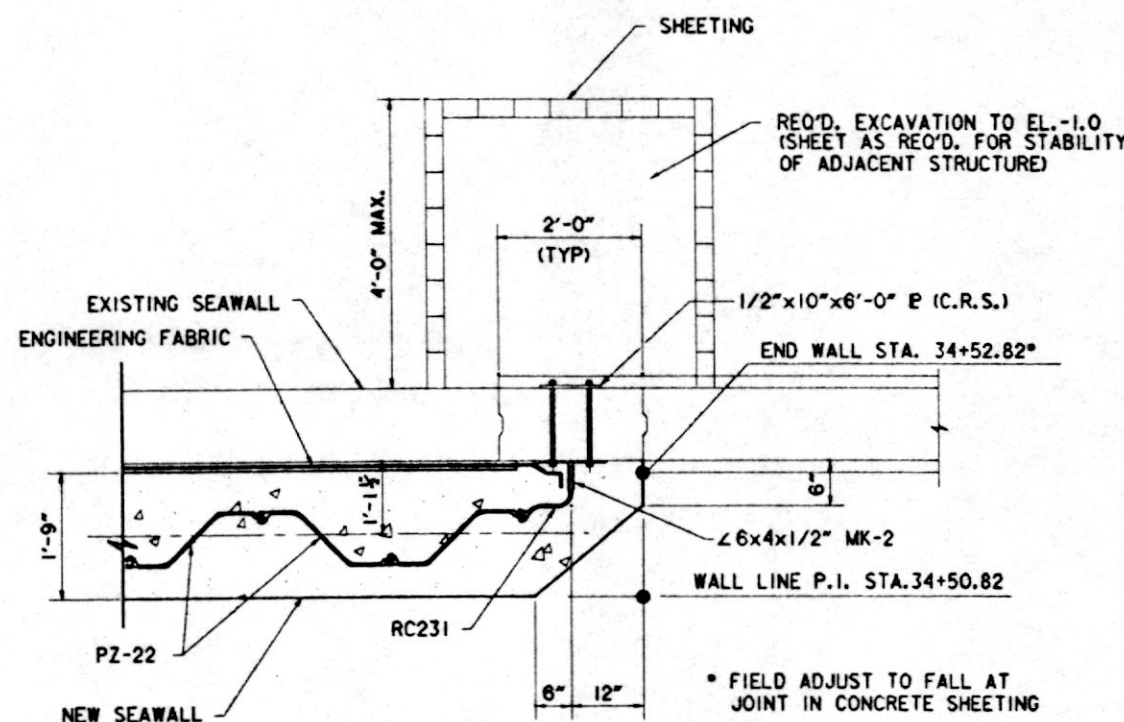SCALE: 3/4" = 1'-0"  
NOTE: CONNECTION AT W/L STATIONS 81+90.38, 82+37.79 AND 83+25.09 SIMILAR



STA. 34+52.82 W/L  
SEAWALL CONNECTION DETAILS  
SCALE: 3/4" = 1'-0"

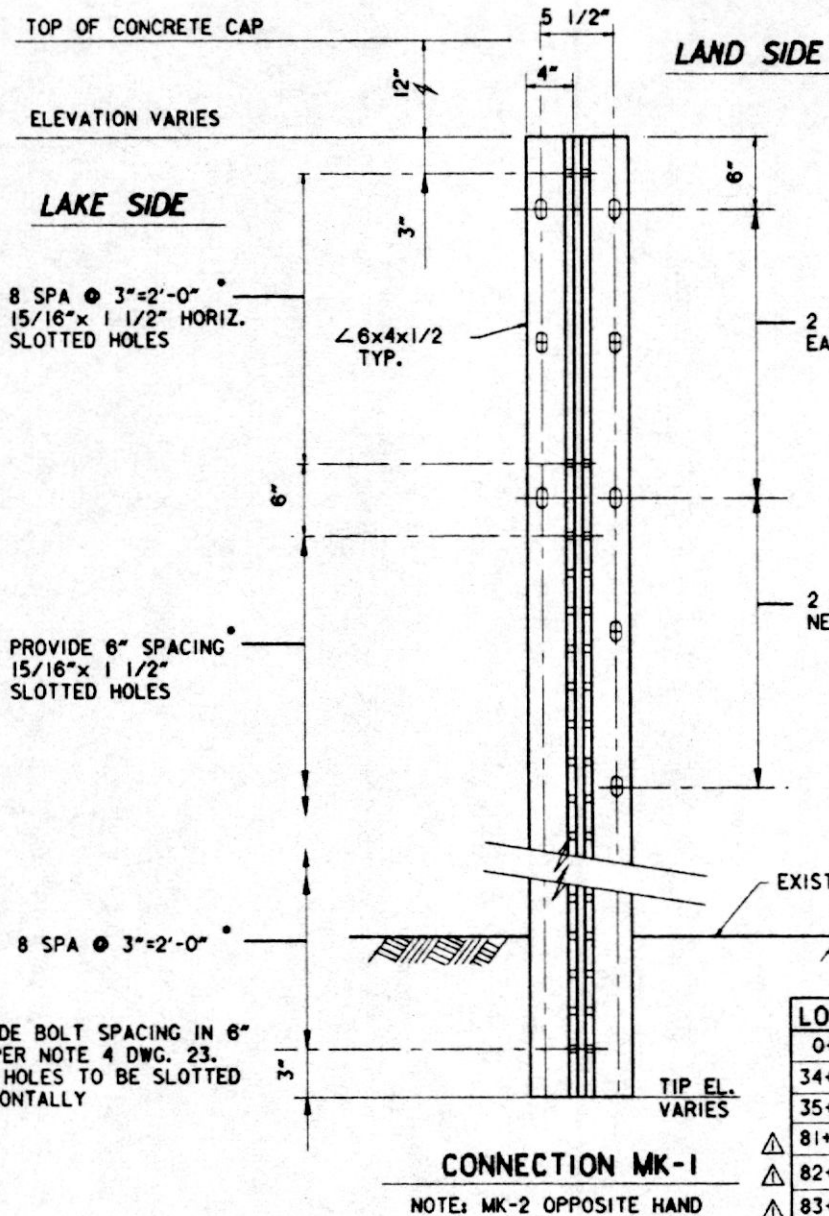
NOTE: CONNECTION STA. 35+04.27 W/L SIMILAR



| LOCATION     | END CONNECTION | CONNECTORS            |
|--------------|----------------|-----------------------|
| 0+00.00 W/L  | MK-1           | 5/8 EXPANSION ANCHORS |
| 34+52.82 W/L | MK-2           | 5/8x10" BOLTS         |
| 35+04.27 W/L | MK-1           | 5/8x10" BOLTS         |
| 81+90.38 W/L | MK-2           | 5/8 EXPANSION ANCHORS |
| 82+37.79 W/L | MK-1           | 5/8 EXPANSION ANCHORS |
| 83+25.09 W/L | MK-2           | 5/8 EXPANSION ANCHORS |

### SHEET PILE END CONNECTION DETAILS

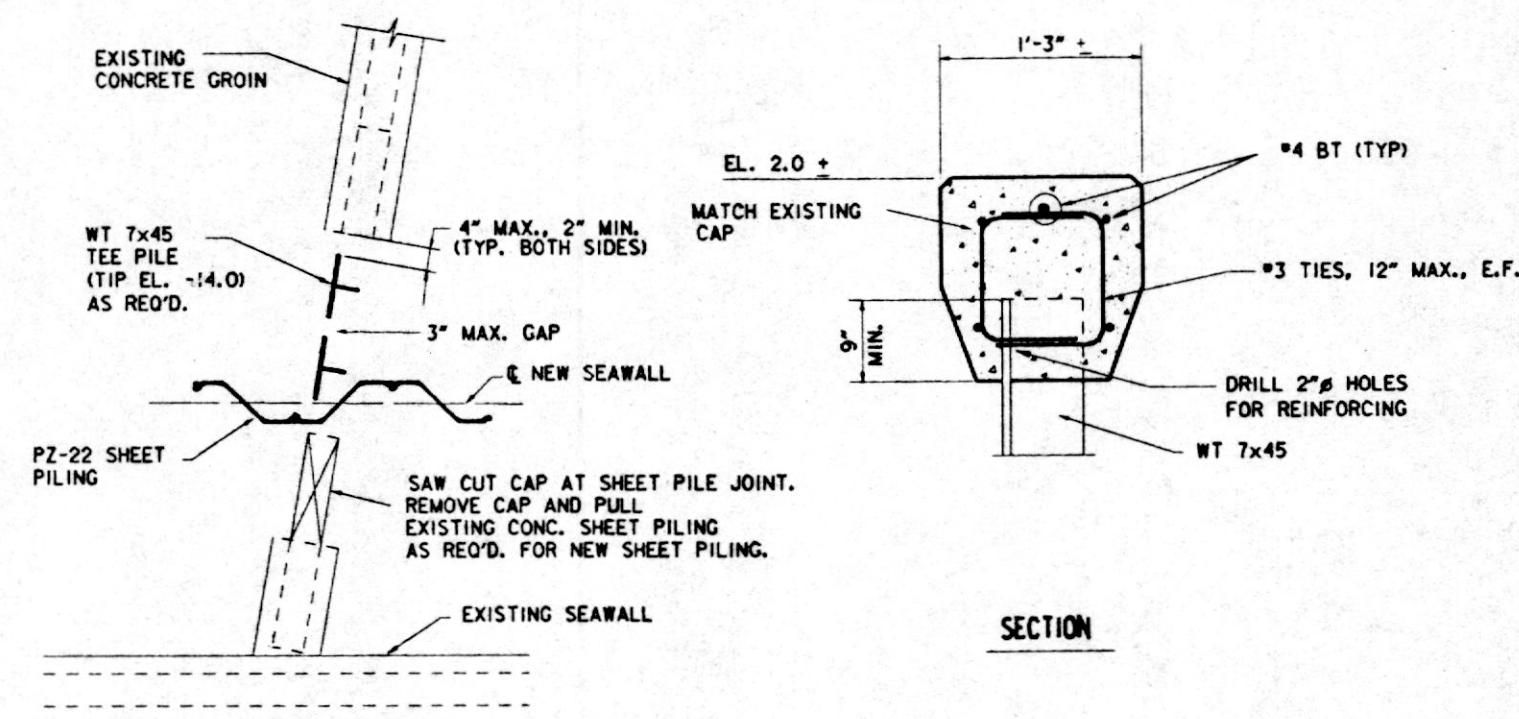SCALE: 1 1/2" = 1'-0"




NOTE: FILL VOIDS RESULTING FROM GROIN REMOVAL. SEE SPECIFICATIONS.

PLAN

### GROIN MODIFICATIONS

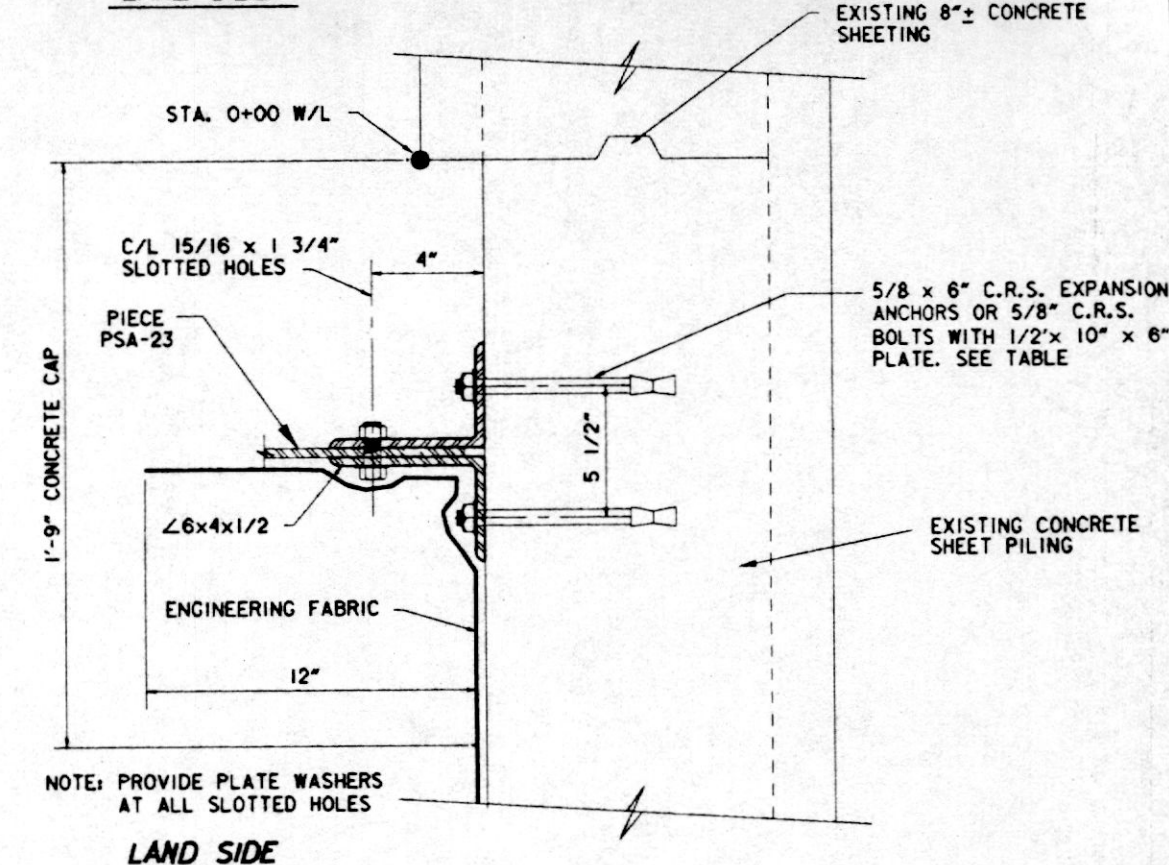
N.T.S.

LAKE SIDE




PLAN  
N.T.S.

 SCALE: 3/4" = 1'-0"




SCALE: 1 1/2" = 1'-0"

 

THIS PLAN ACCOMPANIES  
MODIFICATION 0000  
TO CONTRACT NUMBER  
DACW29-94-C-0031


|                                     |                                   |                    |                      |
|-------------------------------------|-----------------------------------|--------------------|----------------------|
| DESIGNED BY: R.W.Y.                 | DATE: NOV. 1993                   | PLOT SCALE: 16     | PLOT DATE: NOV. 1993 |
| DRAWN BY: J.S.B.                    | CADD FILE: 40335-24.DGN           | FILE NO. H-4-40335 |                      |
| CHECKED BY: T.P.H.                  | SOLICITATION NO. DACW29-94-B-0024 | DWG. 24 OF 31      |                      |
| SUBMITTED BY: ROBERT W. YOKUM, P.E. | DESIGN ENGINEER                   |                    |                      |



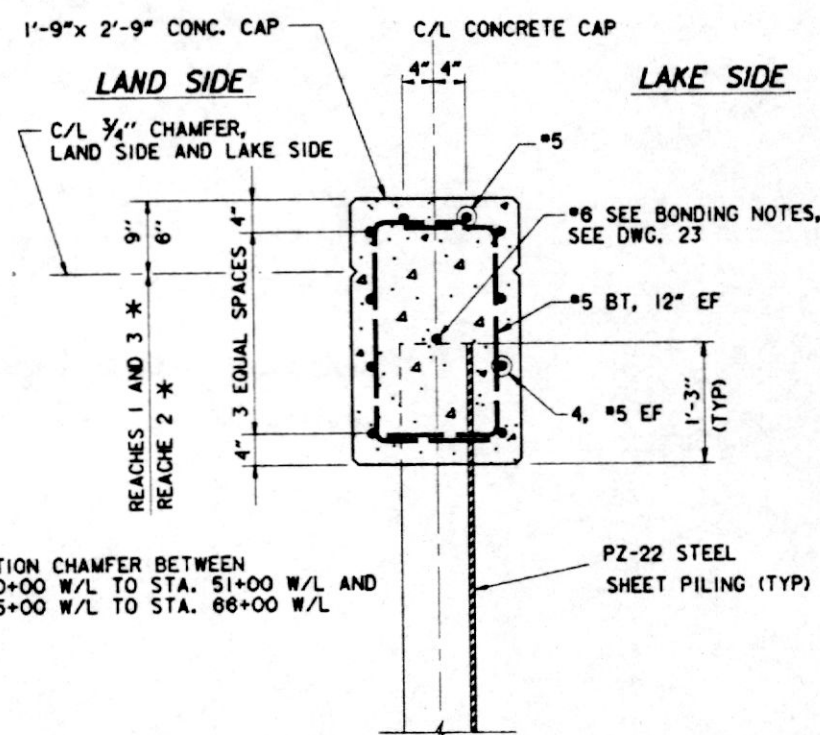


**TYPICAL SEAWALL SECTION**

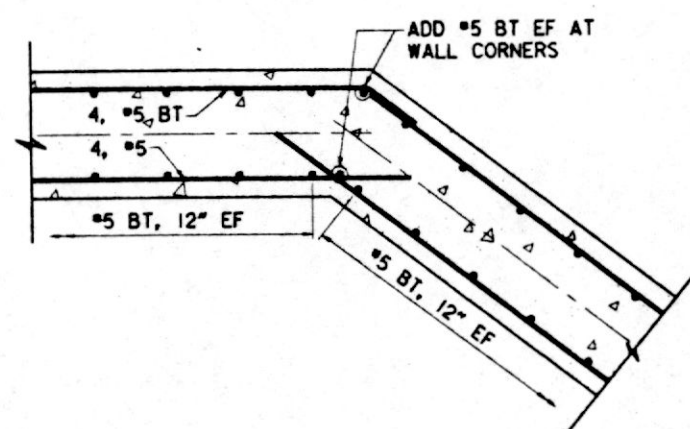SCALE: 1" = 1'-0"




**TYPICAL REINFORCEMENT PLAN AT POINTS OF INTERSECTION**

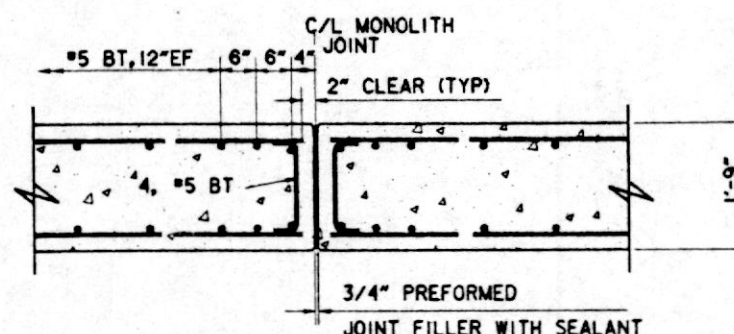SCALE: 3/4" = 1'-0"



**TYPICAL REINFORCEMENT AT MONOLITH JOINT**

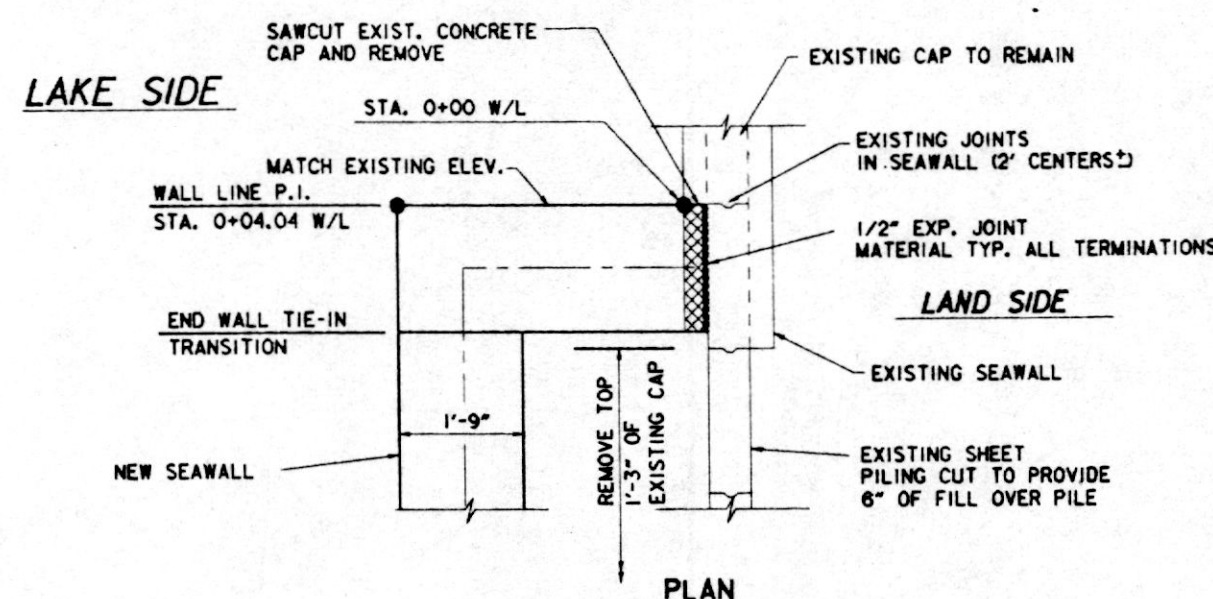
SCALE: 3/4" = 1'-0"



**SEAWALL TERMINATION DETAIL**


SCALE: 3/4" = 1'-0"

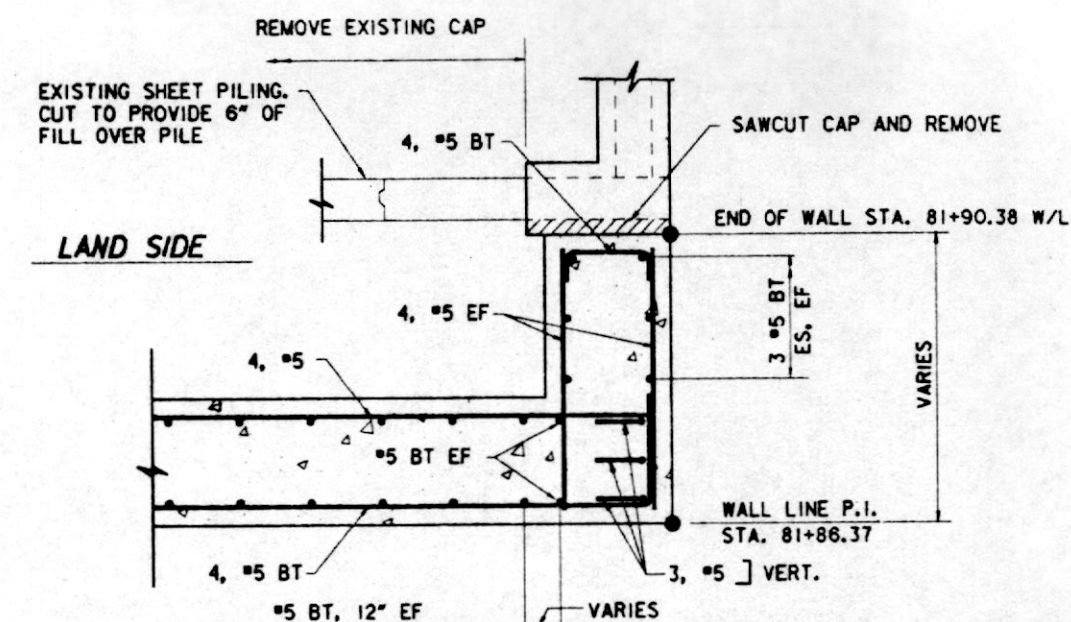**NOTE:**  
TERMINATIONS AT W/L STATIONS 81+90.38, 82+37.79, AND 83+25.09 SIMILAR. CONTRACTOR TO FIELD VERIFY LOCATIONS OF WALL TERMINATIONS SO THAT CENTERLINE OF NEW WALL IS LOCATED BETWEEN JOINTS IN EXISTING SHEET PILING AS SHOWN.



**TYPICAL REINFORCEMENT PLAN AT WALL TERMINATIONS**

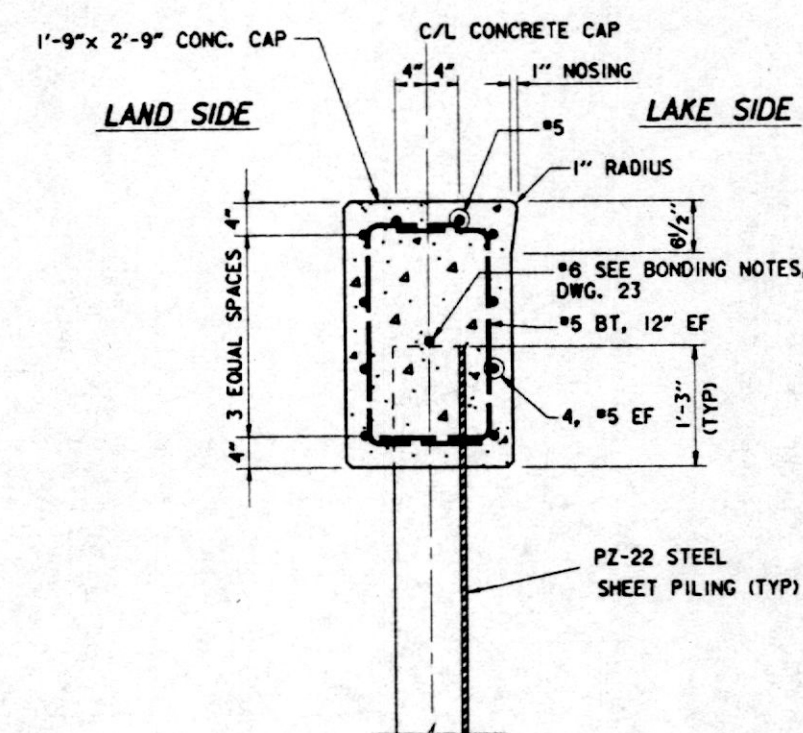
SCALE: 3/4" = 1'-0"



**TYPICAL SECTION AT STAIR**

SCALE: 1" = 1'-0"

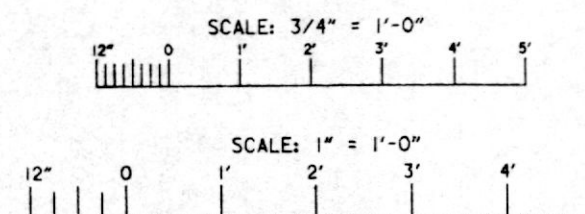THIS PLAN ACCOMPANIES  
MODIFICATION P0000  
TO CONTRACT NUMBER  
DACW29-94-C-0031









| SYMBOL                                                                                        | DESCRIPTION                                                   | DATE               | APPROVED             |
|-----------------------------------------------------------------------------------------------|---------------------------------------------------------------|--------------------|----------------------|
| △                                                                                             | GENERAL REVISIONS TO SECTIONS AND PLANS AND W/L STATIONS MOD. | 4-5-94             | W.O.B.               |
| REVISIONS                                                                                     |                                                               |                    |                      |
| U. S. ARMY ENGINEER DISTRICT, NEW ORLEANS<br>CORPS OF ENGINEERS<br>NEW ORLEANS, LOUISIANA     |                                                               |                    |                      |
| Brown Cunningham Gannuch<br>ENGINEERS - ARCHITECTS - CONSULTANTS                              |                                                               |                    |                      |
| MANDEVILLE SEAWALL, LA.<br>REPLACEMENT OF MANDEVILLE SEAWALL<br>ST. TAMMANY PARISH, LOUISIANA |                                                               |                    |                      |
| SEAWALL REINFORCEMENT<br>AND DETAILS                                                          |                                                               |                    |                      |
| DESIGNED BY: R.W.Y.                                                                           | DATE: NOV. 1993                                               | PLOT SCALE: 1/8"   | PLOT DATE: NOV. 1993 |
| DRAWN BY: J.S.B.                                                                              | CADD FILE: 40339-25.DGN                                       | FILE NO. H-4-40335 |                      |
| CHECKED BY: R.J.G.                                                                            | SOLICITATION NO. DACW29-94-0024                               | DWG. 25 OF 31      |                      |
| SUBMITTED BY: ROBERT W. YOKUM, P.E.                                                           | DESIGN ENGINEER                                               |                    |                      |

Safety is a Part  
of Your Contract



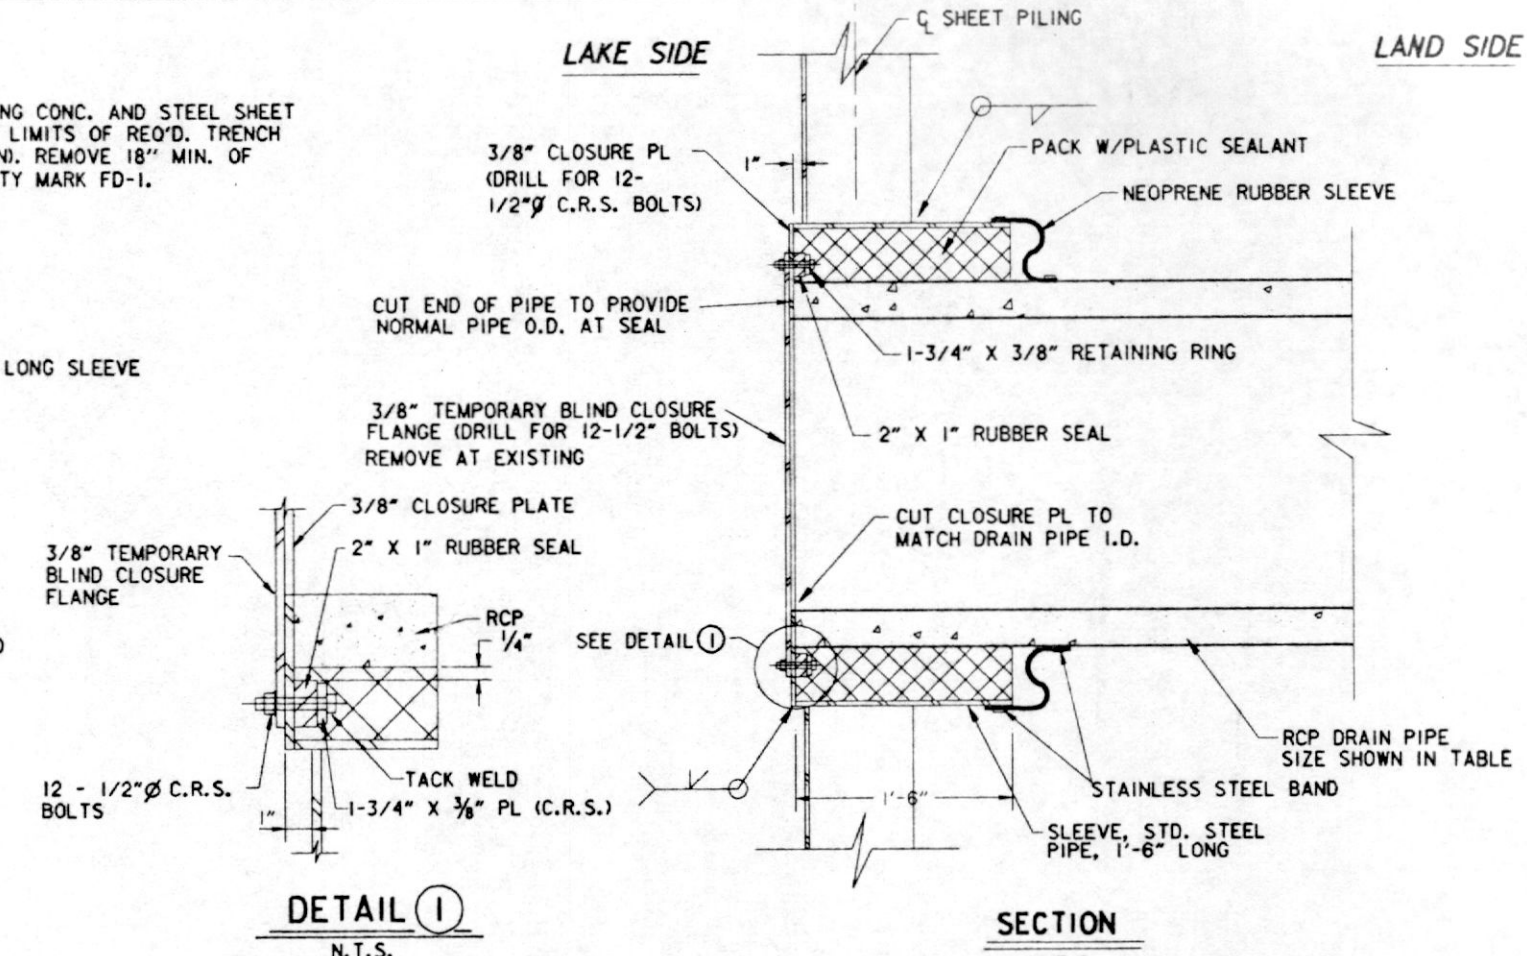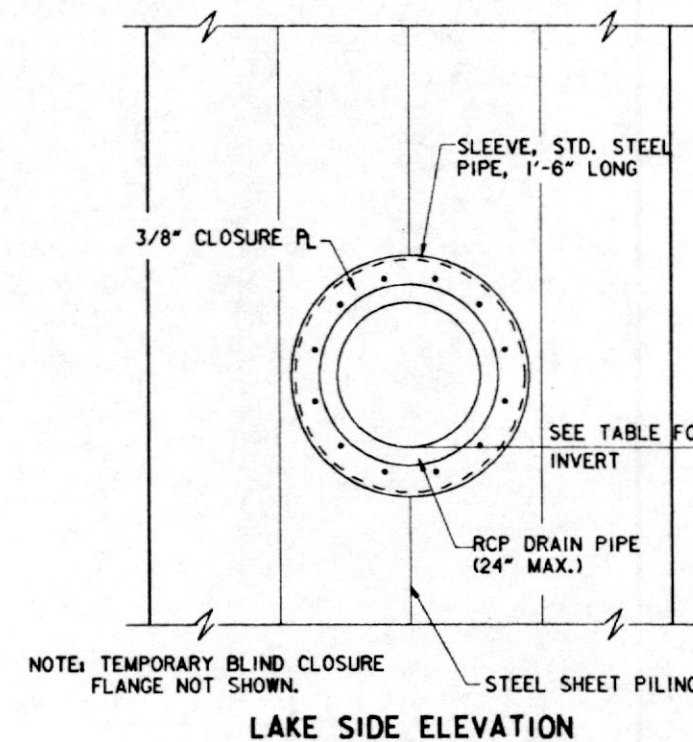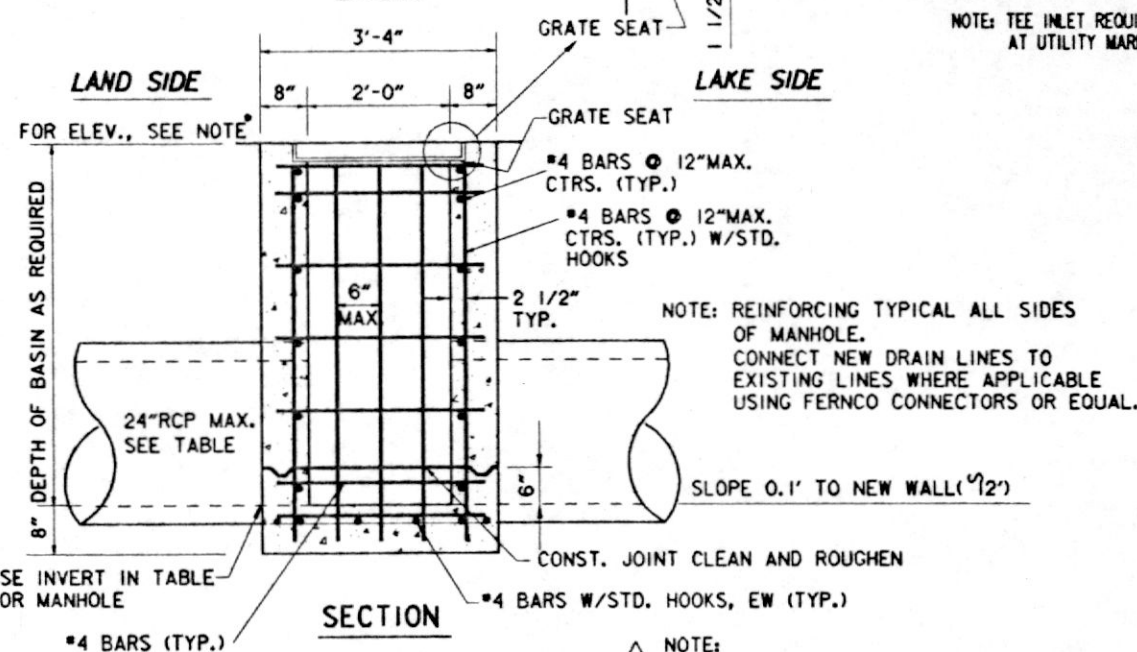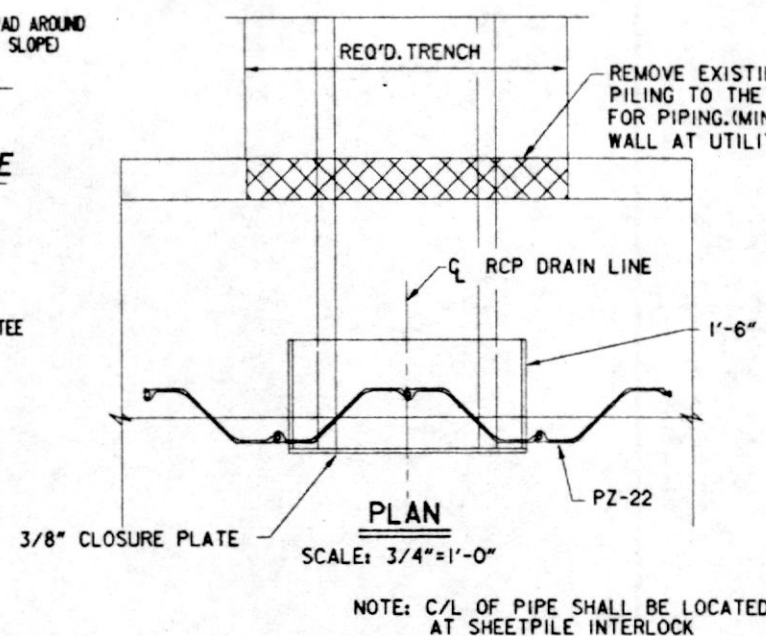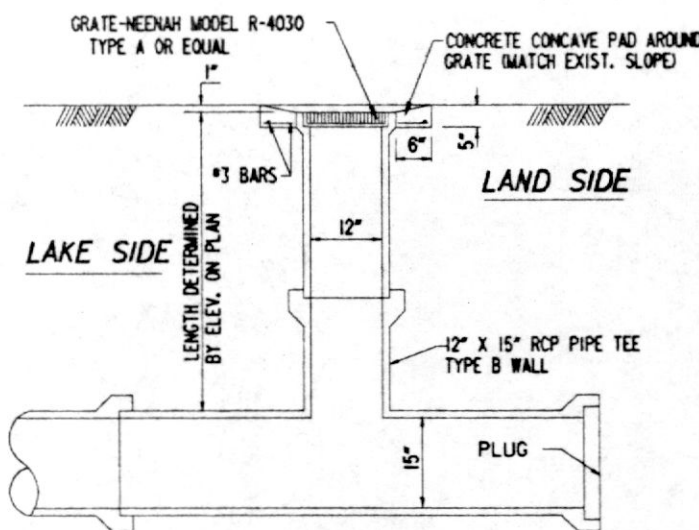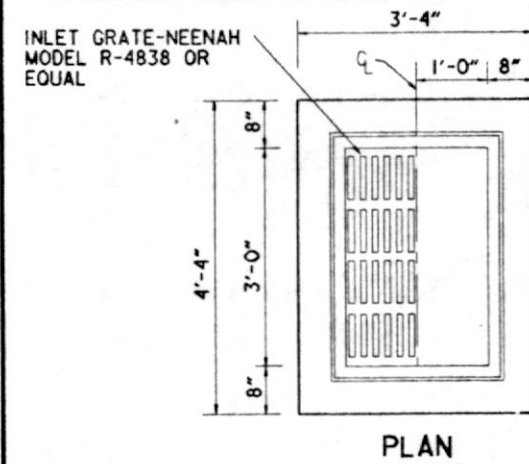**Safety is a Part  
of Your Contract**



**REQUIRED OUTSIDE DIAMETER**

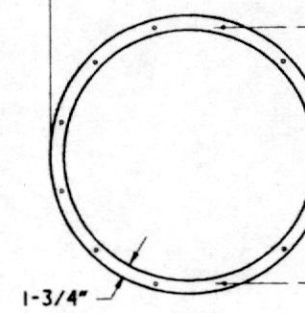
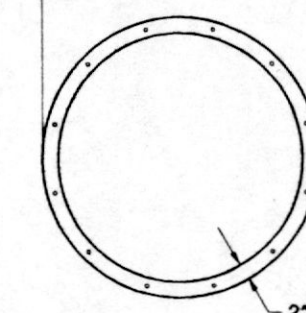
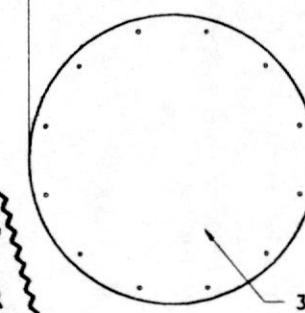
|          |         |
|----------|---------|
| 6" STEEL | 11.125" |
| 12" RCP  | 20.5"   |
| 15" RCP  | 24.0"   |
| 18" RCP  | 27.5"   |
| 24" RCP  | 34.5"   |

**REQUIRED OUTSIDE DIAMETER**

|          |         |
|----------|---------|
| 6" STEEL | 11.125" |
| 12" RCP  | 20.5"   |
| 15" RCP  | 24.0"   |
| 18" RCP  | 27.5"   |
| 24" RCP  | 34.5"   |

**REQUIRED OUTSIDE DIAMETER**

|          |         |
|----------|---------|
| 6" STEEL | 10.875" |
| 12" RCP  | 20.25"  |
| 15" RCP  | 23.75"  |
| 18" RCP  | 27.25"  |
| 24" RCP  | 34.25"  |




**TYPICAL RCP DRAIN LINE THRU STEEL SHEET PILING**

THIS PLAN ACCOMPANIES  
MODIFICATION 0000  
TO CONTRACT NUMBER  
DACW29-94-C-0031


| PIPE TABULATION AND SLEEVE TABLE |                  |                    |                |                           |               |                      |                              |             |              |               |
|----------------------------------|------------------|--------------------|----------------|---------------------------|---------------|----------------------|------------------------------|-------------|--------------|---------------|
| UTILITY MARK                     | APPROX. W/L STA. | EXISTING PIPE SIZE | EXISTING SLOPE | EXISTING INVERT ELEVATION | NEW PIPE SIZE | NEW INVERT ELEVATION | MINIMUM SLEEVE SIZE (INCHES) |             |              | UTILITY NOTES |
|                                  |                  |                    |                |                           |               |                      | NOMINAL                      | INSIDE DIA. | OUTSIDE DIA. |               |
| D - 1                            | 0 + 54.7         | 12" X 12" BOX      | -              | -                         | 15" RCP       | 1.5                  | 30                           | 29.25       | 30           | 1             |
| D - 2                            | 3 + 69.2         | -                  | -              | -                         | 15" RCP       | -0.56                | 30                           | 29.25       | 30           | 4             |
| D - 3                            | 9 + 13.0         | -                  | -              | -                         | 15" RCP       | -0.55                | 30                           | 29.25       | 30           | 4             |
| D - 4                            | 12 + 48.3        | 24" RCP            | .0085          | -1.00                     | 24" RCP       | -1.0                 | 40                           | 39.25       | 40           | 2             |
| D - 5                            | 15 + 26.0        | -                  | -              | -                         | 18" RCP       | -1.07                | 34                           | 33.25       | 34           | 4             |
| D - 6                            | 18 + 48.9        | 24" VCLAY          | .0056          | -1.22                     | 24" RCP       | -1.22                | 40                           | 39.25       | 40           | 2             |
| D - 7                            | 23 + 76.4        | -                  | -              | -                         | 24" RCP       | 1.14                 | 40                           | 39.25       | 40           | 4             |
| D - 8                            | 26 + 69.6        | -                  | -              | -                         | 18" RCP       | 1.07                 | 34                           | 33.25       | 34           | 4             |
| D - 9                            | 31 + 83.6        | -                  | -              | -                         | 12" RCP       | 0.90                 | 24                           | 23.25       | 24           | 5             |
| D - 10                           | 40 + 90.2        | -                  | -              | -                         | 12" RCP       | 0.90                 | 24                           | 23.25       | 24           | 5             |
| D - 11                           | 45 + 85.6        | 24" VCLAY          | .0105          | -0.62                     | 24" RCP       | -0.62                | 40                           | 39.25       | 40           | 2             |
| D - 12                           | 52 + 01.8        | 24" VCLAY          | .0036          | -0.44                     | 24" RCP       | -0.44                | 40                           | 39.25       | 40           | 2             |
| D - 13                           | 57 + 96.4        | 24" VCLAY          | .0024          | 0.76                      | 24" RCP       | -0.29                | 40                           | 39.25       | 40           | 3             |
| D - 14                           | 58 + 25.6        | 24" VCLAY          | .0017          | 0.35                      | 24" RCP       | 0.00                 | 40                           | 39.25       | 40           | 2             |
| D - 15                           | 60 + 18.8        | -                  | -              | -                         | 18" RCP       | -0.64                | 34                           | 33.25       | 34           | 4             |
| D - 16                           | 63 + 88.3        | 24" VCLAY          | .0052          | 0.31                      | 24" RCP       | -0.31                | 40                           | 39.25       | 40           | 3             |
| D - 17                           | 64 + 62.7        | 24" VCLAY          | .0005          | 0.11                      | 24" RCP       | -0.15                | 40                           | 39.25       | 40           | 2             |
| D - 18                           | 67 + 13.8        | -                  | -              | -                         | 15" RCP       | -0.09                | 30                           | 29.25       | 30           | 4             |
| D - 19                           | 70 + 29.7        | 18" VCLAY          | .0111          | 0.14                      | 24" RCP       | -0.23                | 40                           | 39.25       | 40           | 3             |
| D - 20                           | 74 + 50.6        | -                  | -              | -                         | 15" RCP       | -0.08                | 30                           | 29.25       | 30           | 4             |
| D - 21                           | 76 + 83.2        | -                  | -              | -                         | 18" RCP       | -0.13                | 34                           | 33.25       | 34           | 4             |
| D - 22                           | 80 + 07.3        | -                  | -              | -                         | 15" RCP       | -0.52                | 30                           | 29.25       | 30           | 4             |
| FD - 1                           | 42 + 82.0        | 6" STEEL*          | -              | 2.1*                      | 6" STEEL*     | 2.0*                 | 12                           | 12.00       | 12.75        | 6             |

\* FIELD VERIFY

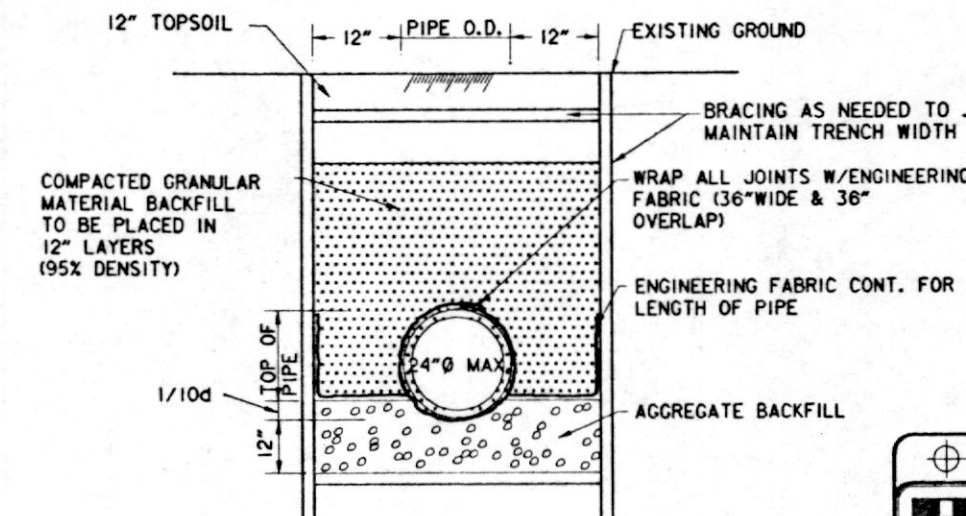1. MANHOLE NOT REQUIRED, USE TEE INLET.
2. PROVIDE MANHOLE. TIE TO EXISTING DRAIN LINE (3X MAXIMUM SLOPE) USING NEW PIPE SIZE.
3. PROVIDE MANHOLE. TIE EXISTING DRAIN LINE INTO MANHOLE AT EXISTING SLOPE.
4. PROVIDE MANHOLE. PROVIDE ONE (1) 6' LENGTH RCP AT 0.12% SLOPE. PLUG END.
5. PROVIDE MANHOLE. MANHOLE FOR DROP INLET ONLY.
6. NO MANHOLE REQUIRED.



**TYPICAL BEDDING DETAIL**



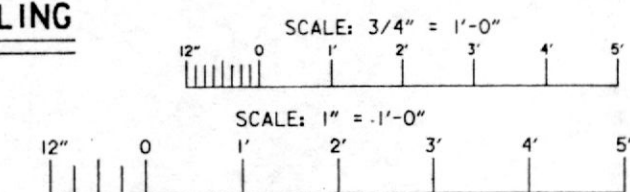


|                                                                                                                                                                                                                                                                                                                             |                                     |                                   |                      |
|-----------------------------------------------------------------------------------------------------------------------------------------------------------------------------------------------------------------------------------------------------------------------------------------------------------------------------|-------------------------------------|-----------------------------------|----------------------|
| REVISOR                                                                                                                                                                                                                                                                                                                     | DATE                                | DESCRIPTION                       | APPROVED             |
| 4-5-94                                                                                                                                                                                                                                                                                                                      | W.O.B.                              |                                   |                      |
| <b>U. S. ARMY ENGINEER DISTRICT, NEW ORLEANS</b><br>CORPS OF ENGINEERS<br>NEW ORLEANS, LOUISIANA<br><b>Brown Cunningham Gannuch</b><br>ENGINEERS - ARCHITECTS - CONSULTANTS<br>MANDEVILLE SEAWALL, LA.<br><b>REPLACEMENT OF MANDEVILLE SEAWALL</b><br>ST. TAMMANY PARISH, LOUISIANA<br><b>DRAINAGE MODIFICATION DETAILS</b> |                                     |                                   |                      |
| DESIGNED BY: M.J.P.                                                                                                                                                                                                                                                                                                         | DATE: NOV. 1993                     | PLOT SCALE: 16                    | PLOT DATE: NOV. 1993 |
| DRAWN BY: J.S.B.                                                                                                                                                                                                                                                                                                            | CADD FILE: 40335-26.DGN             | FILE NO: H-4-40335                |                      |
| CHECKED BY: R.W.Y.                                                                                                                                                                                                                                                                                                          | SUBMITTED BY: ROBERT W. YOKUM, P.E. | SOLICITATION NO: DACW29-94-B-0024 | DWG. 26 OF 31        |
| DESIGN ENGINEER                                                                                                                                                                                                                                                                                                             |                                     |                                   |                      |







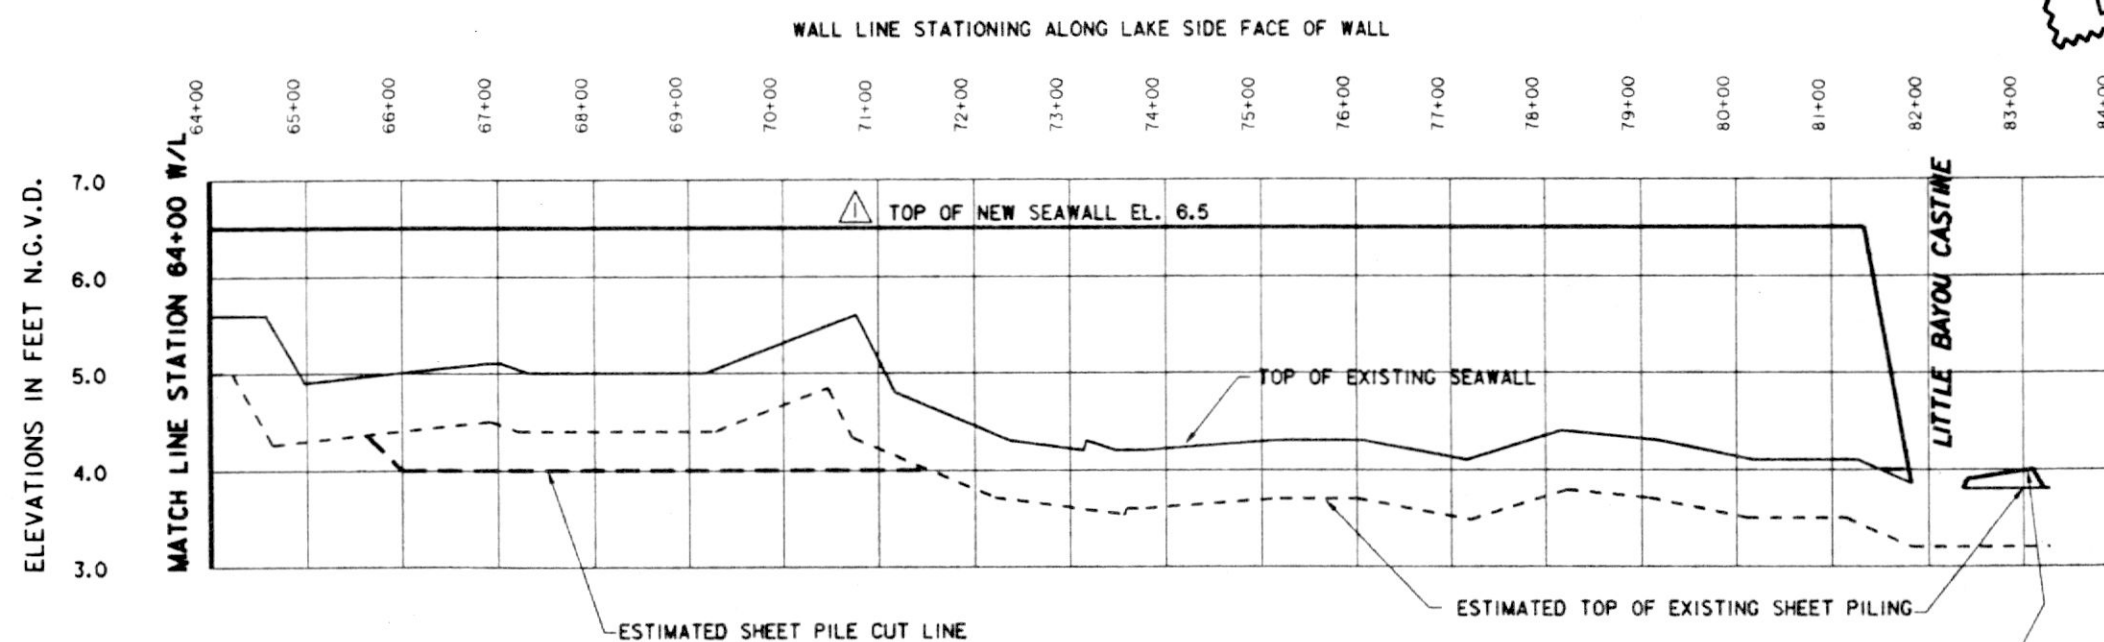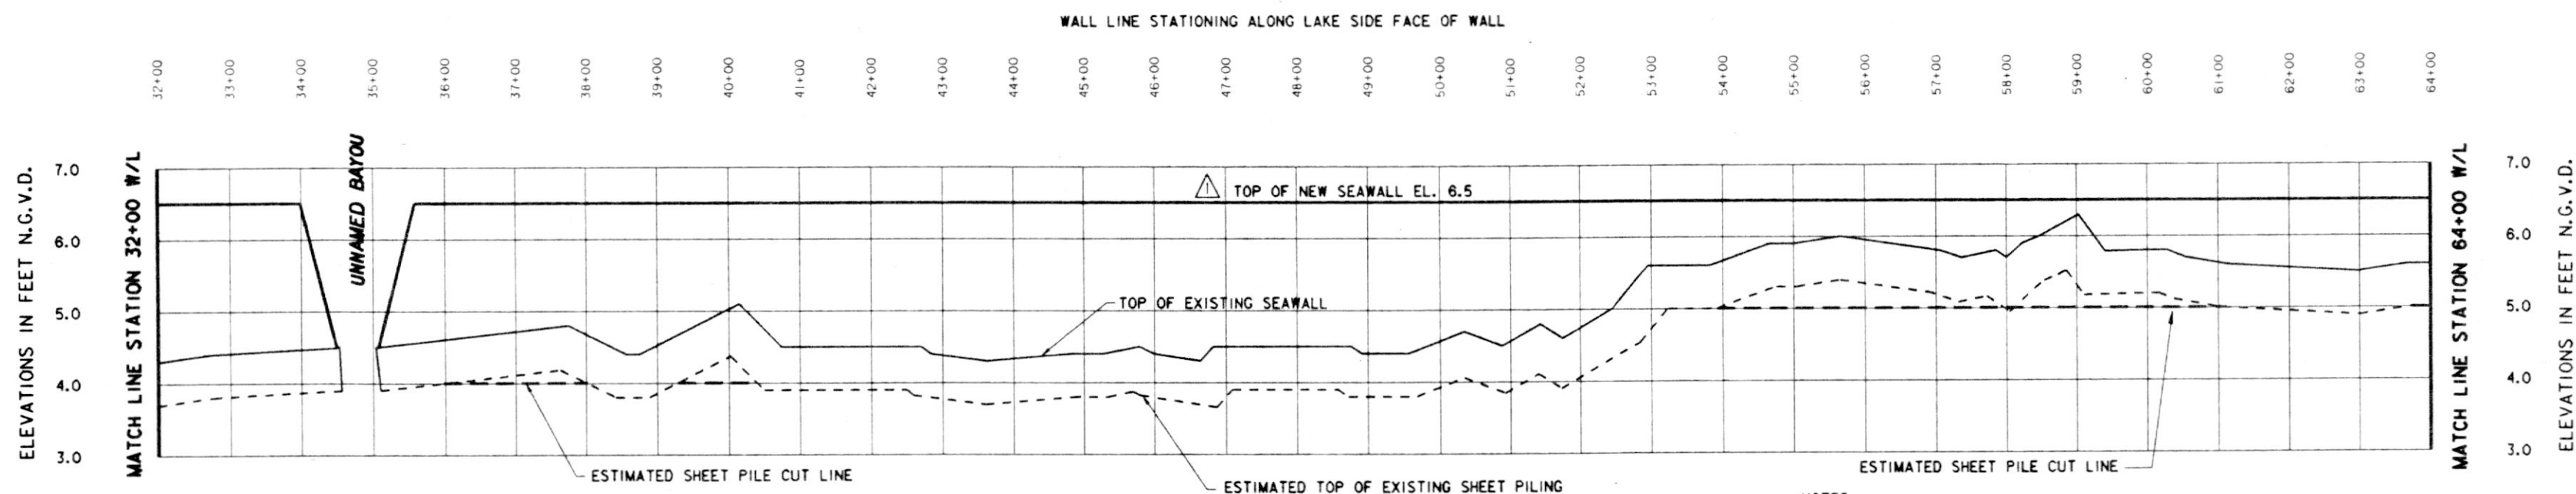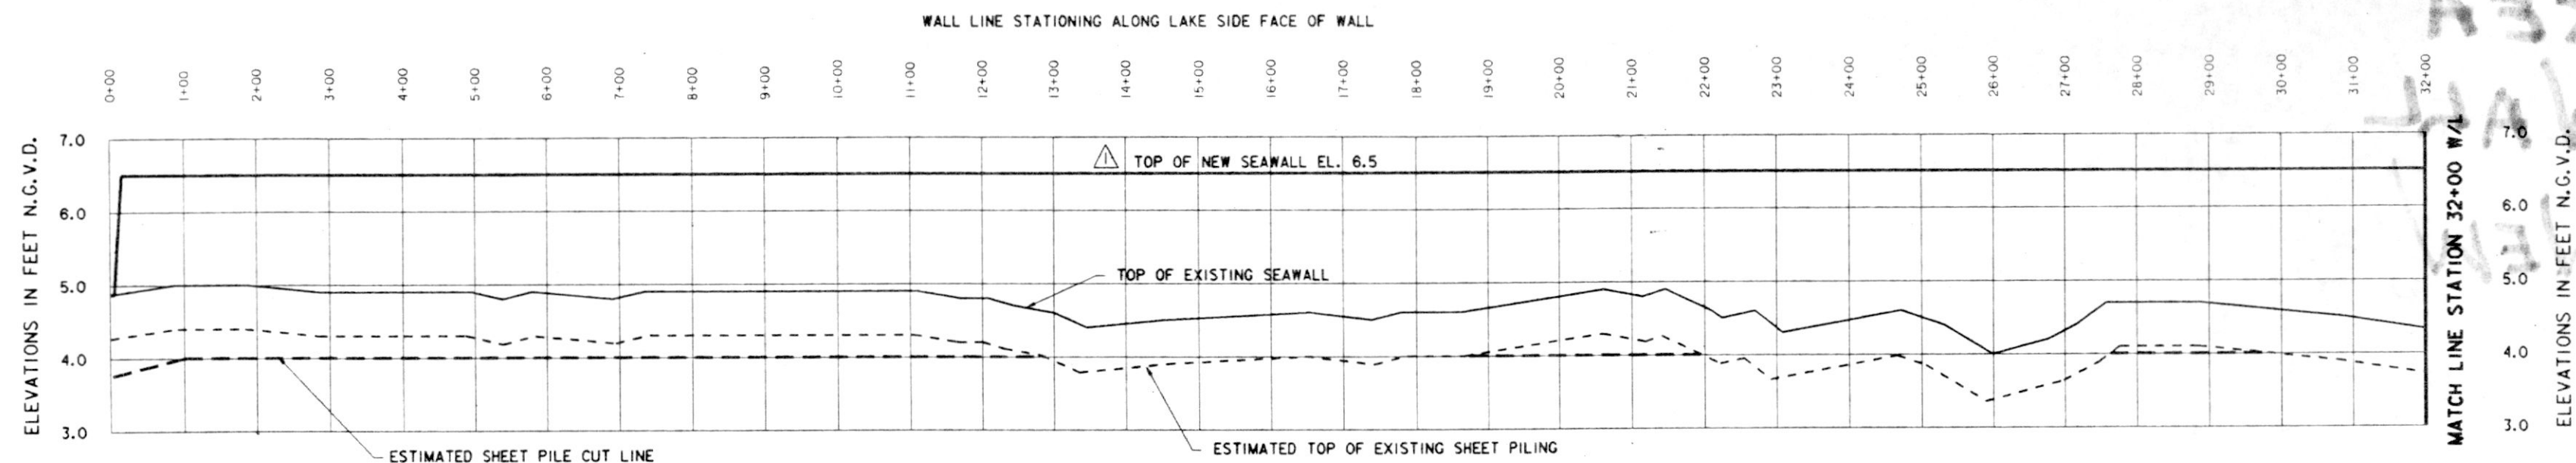


THIS PLAN ACCOMPANIES  
MODIFICATION P0000  
TO CONTRACT NUMBER  
DACW29-94-C-0031

NOTES:

1. THE TOP OF THE EXISTING SHEET PILING IS ESTIMATED TO BE APPROXIMATELY 6" BELOW THE TOP OF THE EXISTING WALL BUT MAY VARY. FIELD VERIFY.
2. THE ESTIMATED SHEET PILE CUT LINE IS BASED ON PROVIDING A MINIMUM OF 6" OF FILL COVER BELOW FINISHED GRADES AND A FILL SLOPE OF 1V ON 12H FOR DRAINAGE.
3. IN LOCALIZED AREAS AND AT WALL TERMINATIONS ADDITIONAL SHEETPILE REMOVAL MAY BE REQUIRED TO PROVIDE 6" OF FILL COVER.
4. WALL REMOVAL SHALL BE ACCOMPLISHED IN A CONTROLLED MANNER.

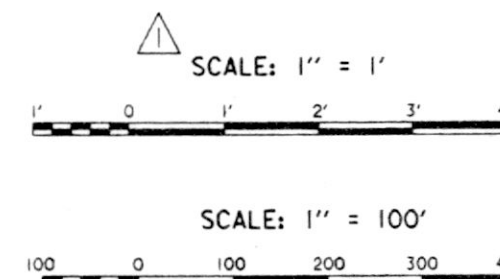ELEVATIONS IN FEET N.G.V.D.



Safety is a Part  
of Your Contract

|                                                                                                                                                                   |                                                                                  |
|-------------------------------------------------------------------------------------------------------------------------------------------------------------------|----------------------------------------------------------------------------------|
| REVISIONS<br>SYMBOL DESCRIPTION DATE APPROVED                                                                                                                     |                                                                                  |
| U. S. ARMY ENGINEER DISTRICT, NEW ORLEANS<br>CORPS OF ENGINEERS<br>NEW ORLEANS, LOUISIANA                                                                         |                                                                                  |
| Brown Cunningham Gannuch<br>ENGINEERS - ARCHITECTS - CONSULTANTS<br>MANDEVILLE SEAWALL, LA.<br>REPLACEMENT OF MANDEVILLE SEAWALL<br>ST. TAMMANY PARISH, LOUISIANA |                                                                                  |
| EXISTING WALL PROFILE                                                                                                                                             |                                                                                  |
| DESIGNED BY: R.W.Y.<br>DRAWN BY: J.S.B.<br>CHECKED BY: T.P.H.                                                                                                     | DATE: NOV. 1993<br>CADD FILE: 40335-28.DGN<br>SOLICITATION NO.: DACW29-94-B-0024 |
| PLOT SCALE: 1200<br>FILE NO.: H-4-40335<br>DWG. 28 OF 31                                                                                                          | PLOT DATE: NOV. 1993                                                             |